

A PROPOSED

HAMPTON INN

MONROE, LOUISIANA

DESIGN CONSORTIUM

MEMPHIS, TENNESSEE

LIST OF DRAWINGS

CIVIL

- C-1 SITE PLAN
- C-2 SITE DETAILS
- C-3 GRADING PLAN
- C-4 UTILITY SITE PLAN

ARCHITECTURAL

- A-1 GROUND FLOOR PLAN
- A-2 SECOND FLOOR PLAN
- A-3 ROOF PLAN and EXTERIOR ELEVATIONS
- A-4 COMMERCIAL / SERVICE AREA FLOOR PLANS
- A-5 TYPICAL GUEST ROOMS
- A-6 TYPICAL BATH ROOMS
- A-7 BUILDING SECTIONS AND DETAILS
- A-8 SCHEDULES

STRUCTURAL

- S-1 FOUNDATION AND GROUND FLOOR SLAB
- S-2 SECOND FLOOR SLAB
- S-3 ROOF FRAMING PLAN
- S-4 MISC. STRUCTURAL DETAILS

PLUMBING

- P-1 GROUND FLOOR PLUMBING PLAN
- P-2 SECOND FLOOR PLUMBING PLAN
- P-3 COMMERCIAL / SERVICE AREA FLOOR PLANS
- P-4 PLUMBING RISERS AND DETAILS
- P-5 PLUMBING SCHEDULES AND DETAILS

MECHANICAL




- M-1 GROUND FLOOR MECHANICAL PLAN
- M-2 SECOND FLOOR MECHANICAL PLAN
- M-3 COMMERCIAL / SERVICE AREA FLOOR PLANS

ELECTRICAL





- E-1 GROUND FLOOR LIGHTING PLAN
- E-2 GROUND FLOOR POWER PLAN
- E-3 SECOND FLOOR ELECTRICAL PLAN
- E-4 COMMERCIAL / SERVICE AREA FLOOR LIGHTING PLAN
- E-5 COMMERCIAL / SERVICE AREA FLOOR POWER PLAN
- E-6 TYPICAL GUEST ROOMS
- E-7 NOTES, SCHEDULES AND PANEL DIAGRAM

Hampton
Inn


Hampton
Inn

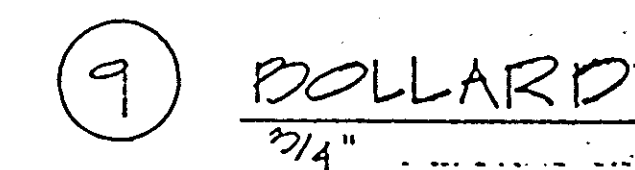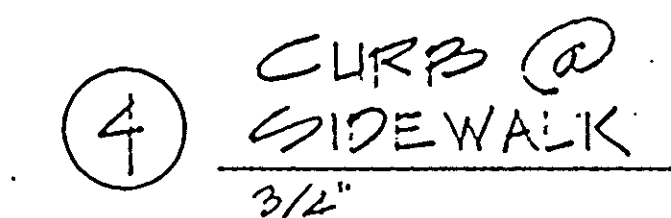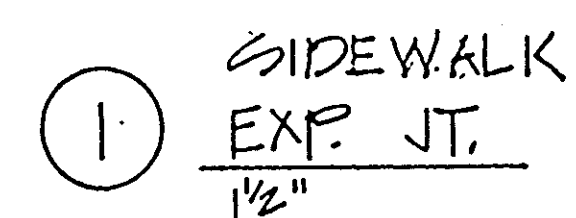

- # KEYNOTES
- ① 424 x 1/4" ATL. TUBE JAMPS
SECURE TO CONC. BLK. W/3
EXP. ANCHORS
 - ② 3/4" P HINGE BOLT WELD TO
ATL. TUBE JAMB
 - ③ 2" x 4" x 3/16" ATL. TUBE GATE F
 - ④ 3" x 3/8" HINGE PIPE WELD TO
GATE FRAME
 - ⑤ 1/8" x 1" P WASHER WELD TO
HINGE BOLT
 - ⑥ 1" x 8" STRAP BEHIND WELD
TO GATE FRAME
 - ⑦ 1/4" D LG SCREW ATL. FROM
BEHIND - 3" PER BOARD
 - ⑧ 3/4" P x 3/4" BOLT KEEPER
 - ⑨ 1" P x 1" KEEPER PIPE WELD
TO GATE FRAME
 - ⑩ 1/2" P BURIED PIPE TO KEEPER
KEEPER
 - ⑪ 1/2" x 2" CLIP WELD TO GATE FR
 - 12 2" x 4" MAG. C AND BTR
CEAR BOARDS - PEN. W/ 3/16"
 - 13 LOCKER HASP
 - 14 HINGE - 3" PER JAMB

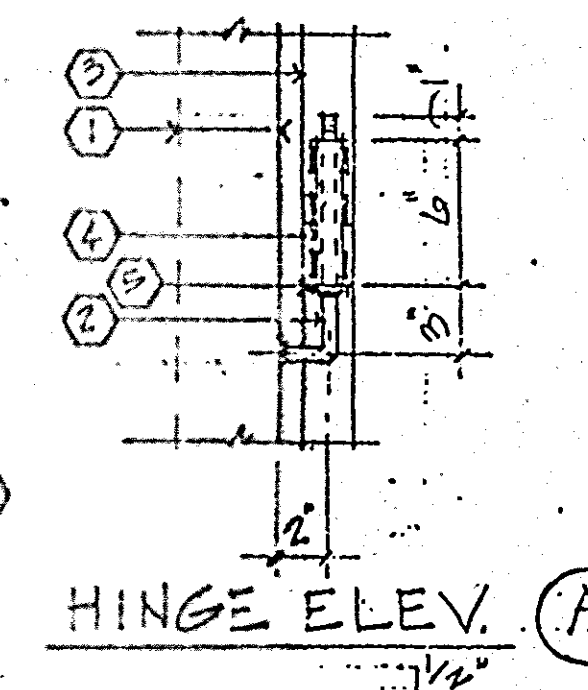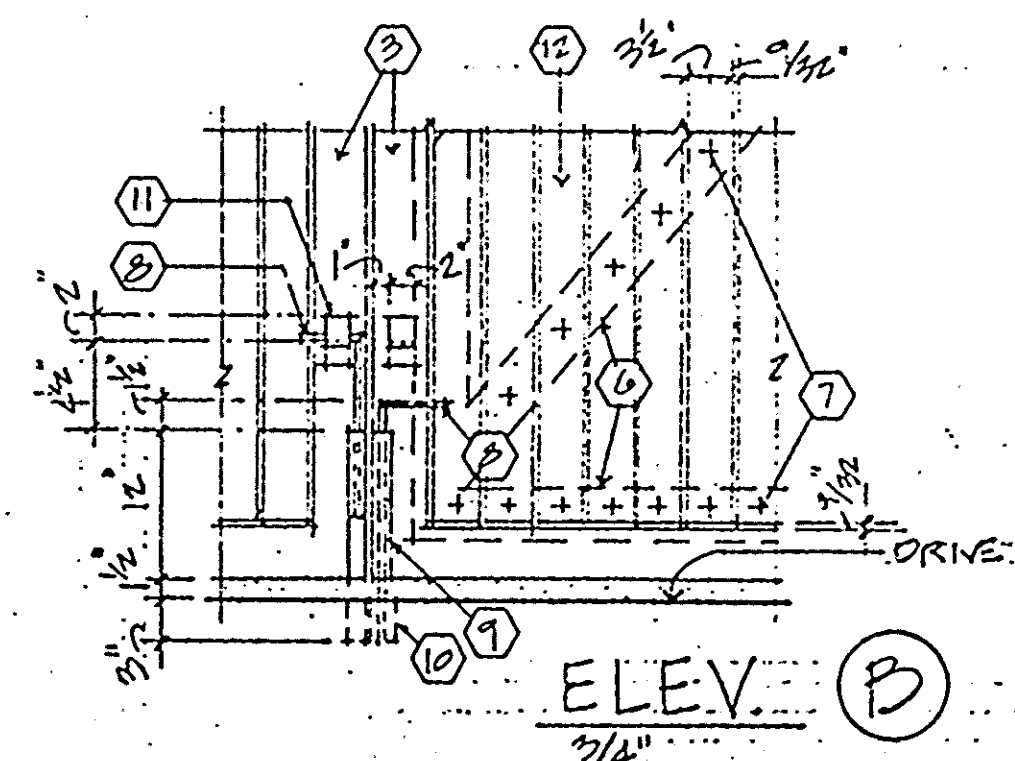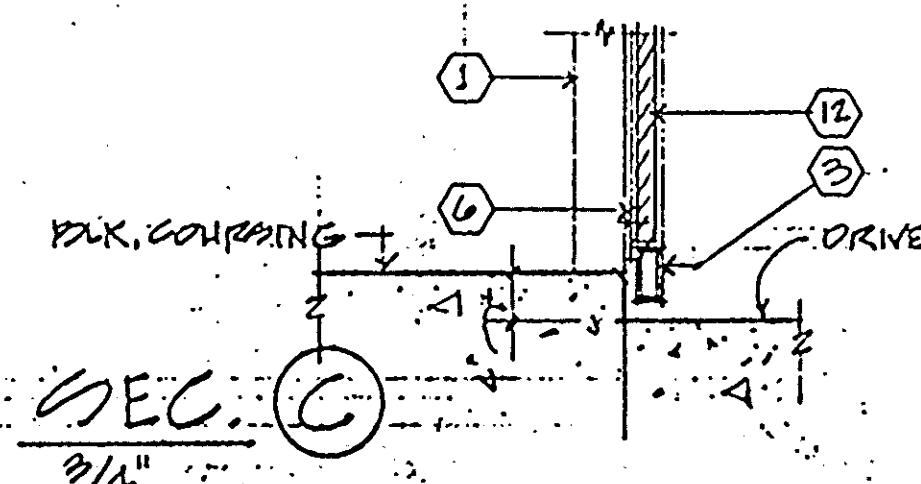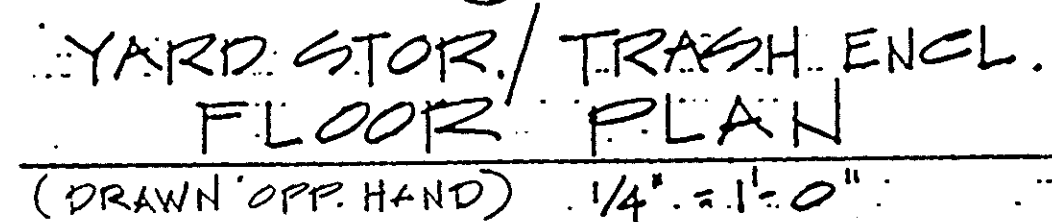

HAMPTON INN MONROE, LA	DESIGN CONSORTIUM HOTEL CONSULTANTS MEMPHIS, TENNESSEE		
SITE DETAILS	DATE 8-1-83	SCALE JOB NO	C-2

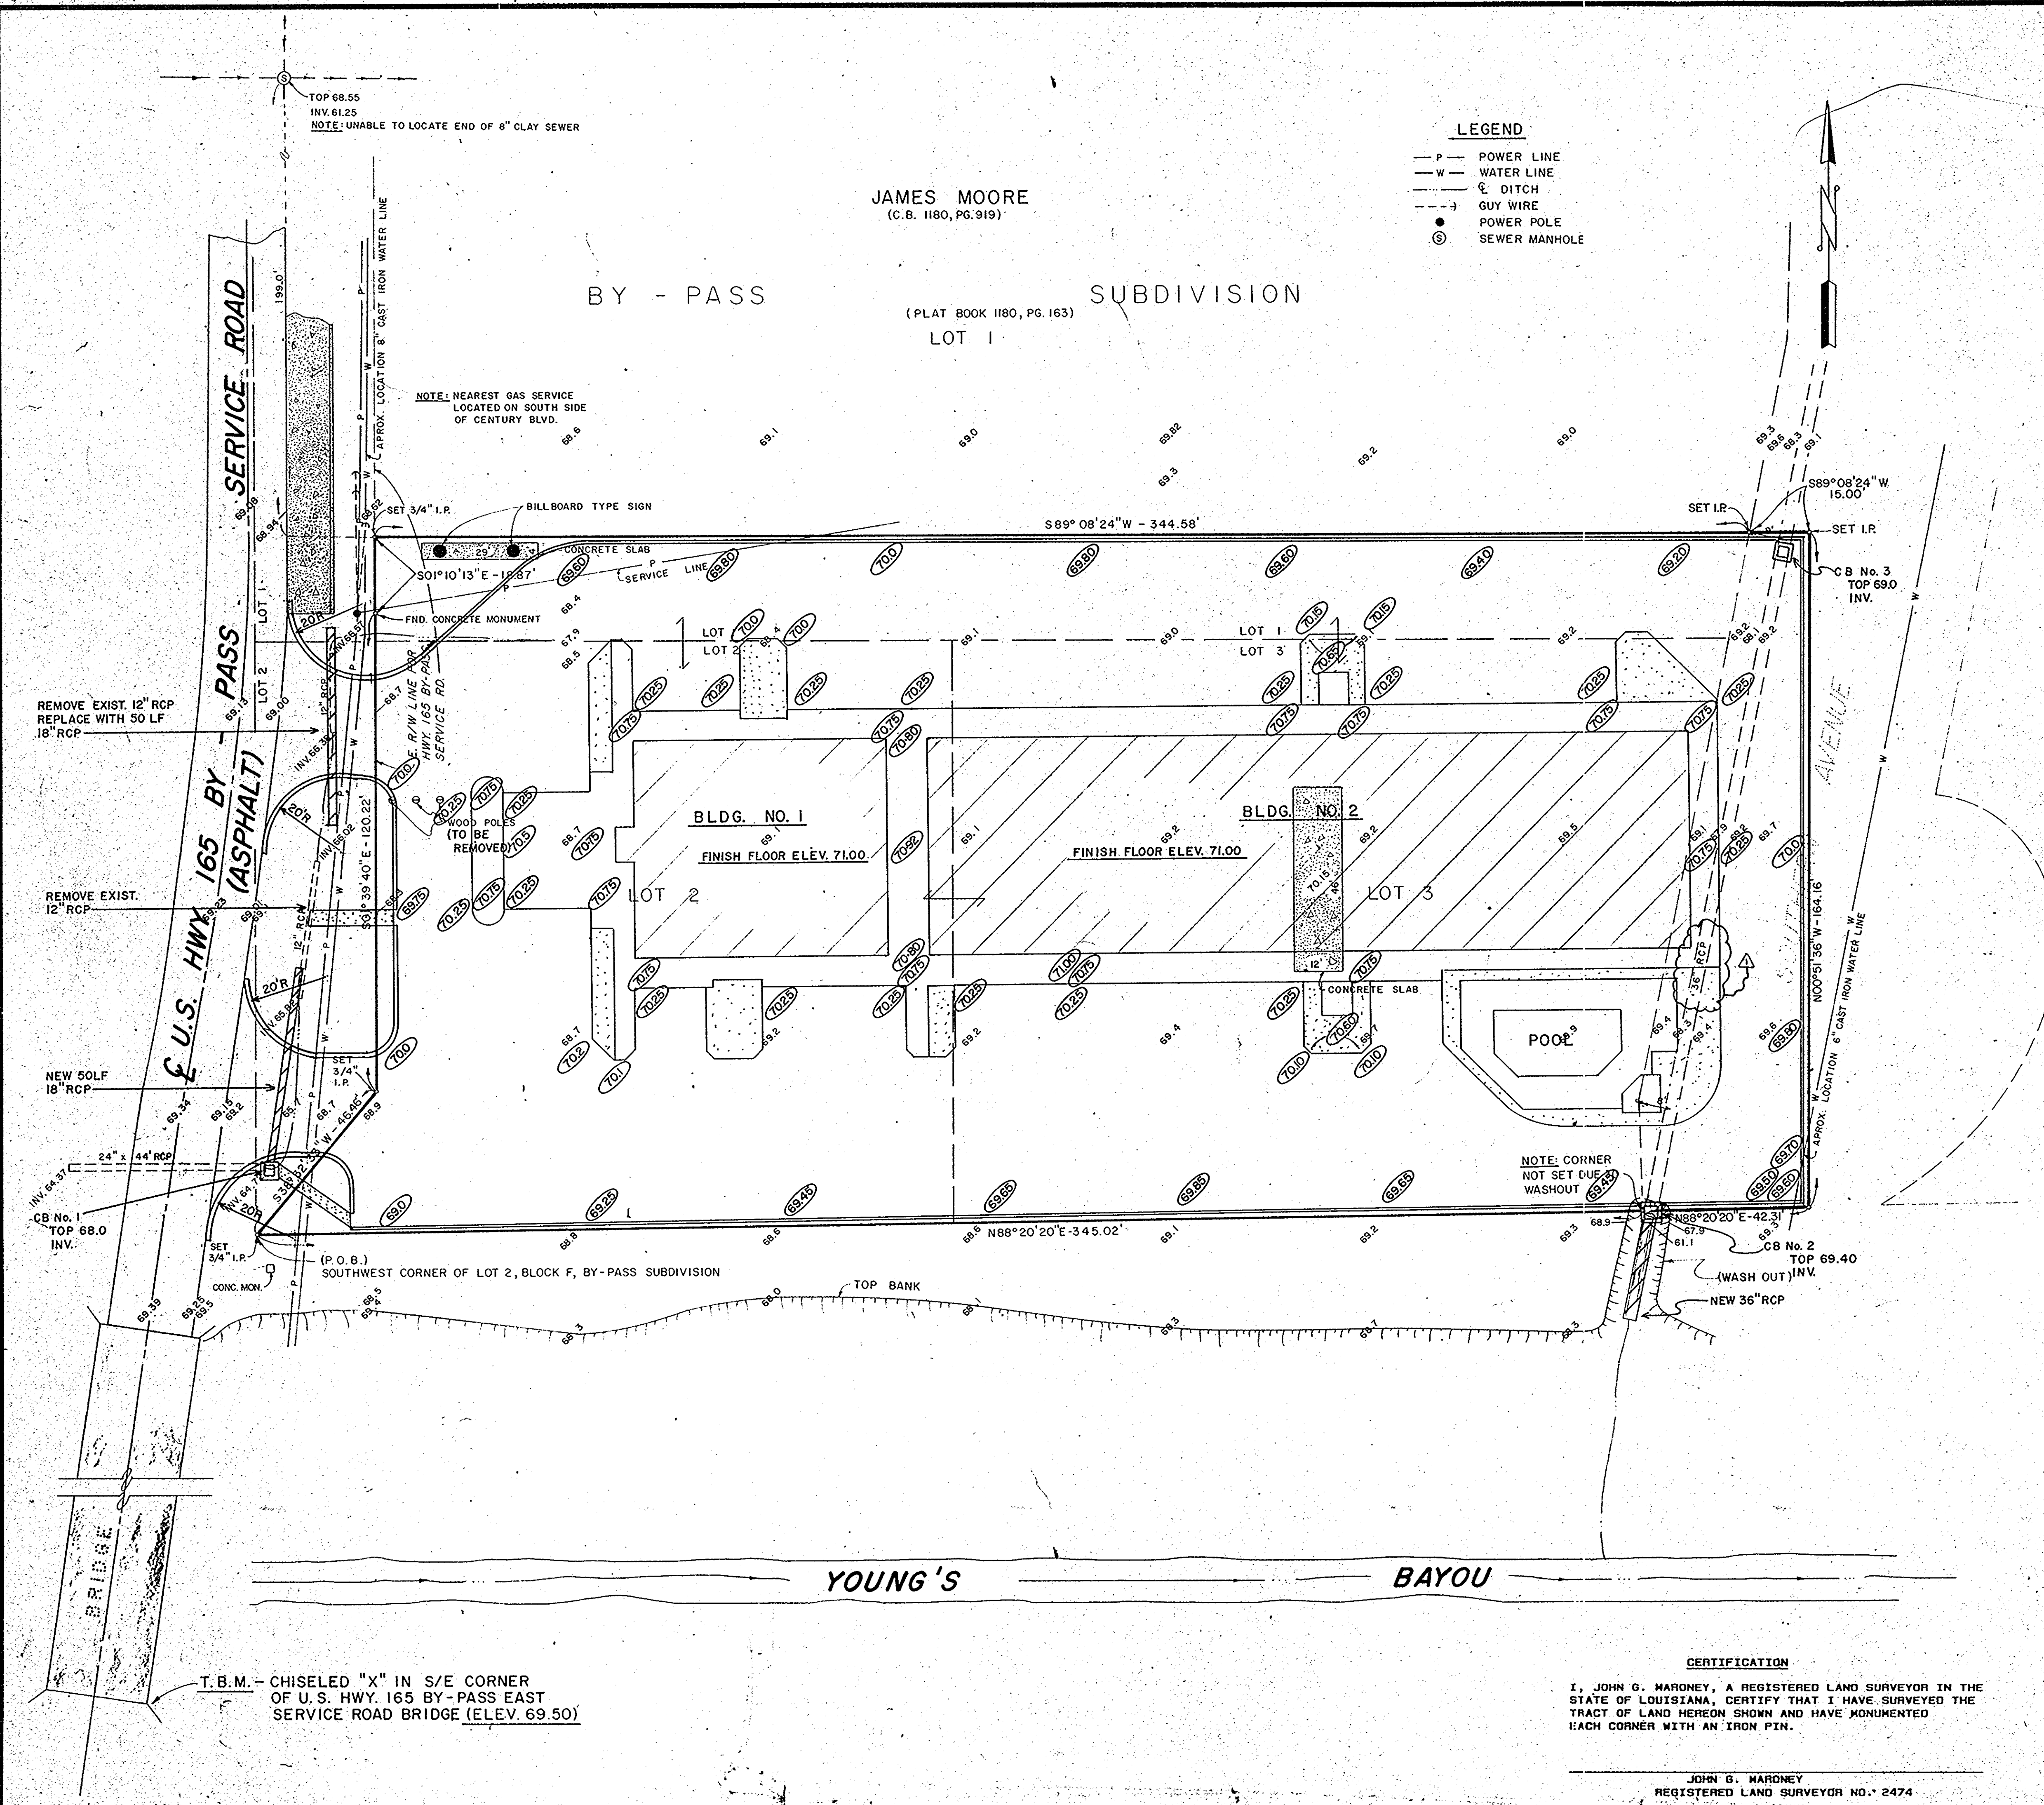

LEGAL DESCRIPTION

A certain tract or parcel of land being Lot 1, 2, and 3, Block "F", By-Pass Subdivision, Parish of Ouachita, Louisiana, and being more particularly described as follows:

Commence at the Southwest corner of Lot 1, Block "F", By-Pass Subdivision (Recorded in Plat Book 11, page 183, recorded in the Parish of Ouachita, Louisiana), Monroe, Ouachita Parish, Louisiana, the POINT OF BEGINNING; thence proceed North 88 degrees 20 minutes 20 seconds East along the South line of Lot 1, a distance of 145.31 feet; thence proceed South 89 degrees 08 minutes 24 seconds West along a line parallel to the South line of Lot number 1, a distance of 344.58 feet to a point on the East right of way line of U.S. Highway 165 By-Pass; thence run the following courses along said East right of way line: South 01 degree 10 minutes 13 seconds East, a distance of 18.87 feet; thence South 01 degree 39 minutes 40 seconds East, a distance of 120.22 feet; thence South 38 degrees 32 minutes 33 seconds West, a distance of 46.46 feet to the POINT OF BEGINNING, containing 1.31 acres, more or less, and being subject to all rights of ways, easements and servitudes of record or of use.

NOTE:

1) INTERMEDIATE REGION FLOOD CREST ELEV. 68.5
2) MINIMUM FLOOR ELEV. 70.2 M.S.L.

LEGEND

75.0 - EXIST. GRADE
70.0 - FINISH GRADE

CERTIFICATION

I, JOHN G. MARONEY, A REGISTERED LAND SURVEYOR IN THE STATE OF LOUISIANA, CERTIFY THAT I HAVE SURVEYED THE TRACT OF LAND HEREON SHOWN AND HAVE MONUMENTED EACH CORNER WITH AN IRON PIN.

JOHN G. MARONEY
REGISTERED LAND SURVEYOR NO. 2474


REV. 11/16/92 ADDED 36" RCP

TOPOGRAPHIC SURVEY FOR
ROY PATEL
IN LOTS 1, 2, & 3-BLK. F, BY-PASS SUBD.
OUACHITA PARISH, LOUISIANA

JOHN G. MARONEY
CONSULTING ENGINEERS, INC.
REGISTERED LAND SURVEYORS
208 LOUISVILLE AVENUE P.O. 2473
MONROE, LOUISIANA 71201
PHONE (504) 388-1151 FAX (504) 388-1401

SCALE 1"=20'
DATE 10/24/92
DRAWN BY NOLAN

6-3
23/25

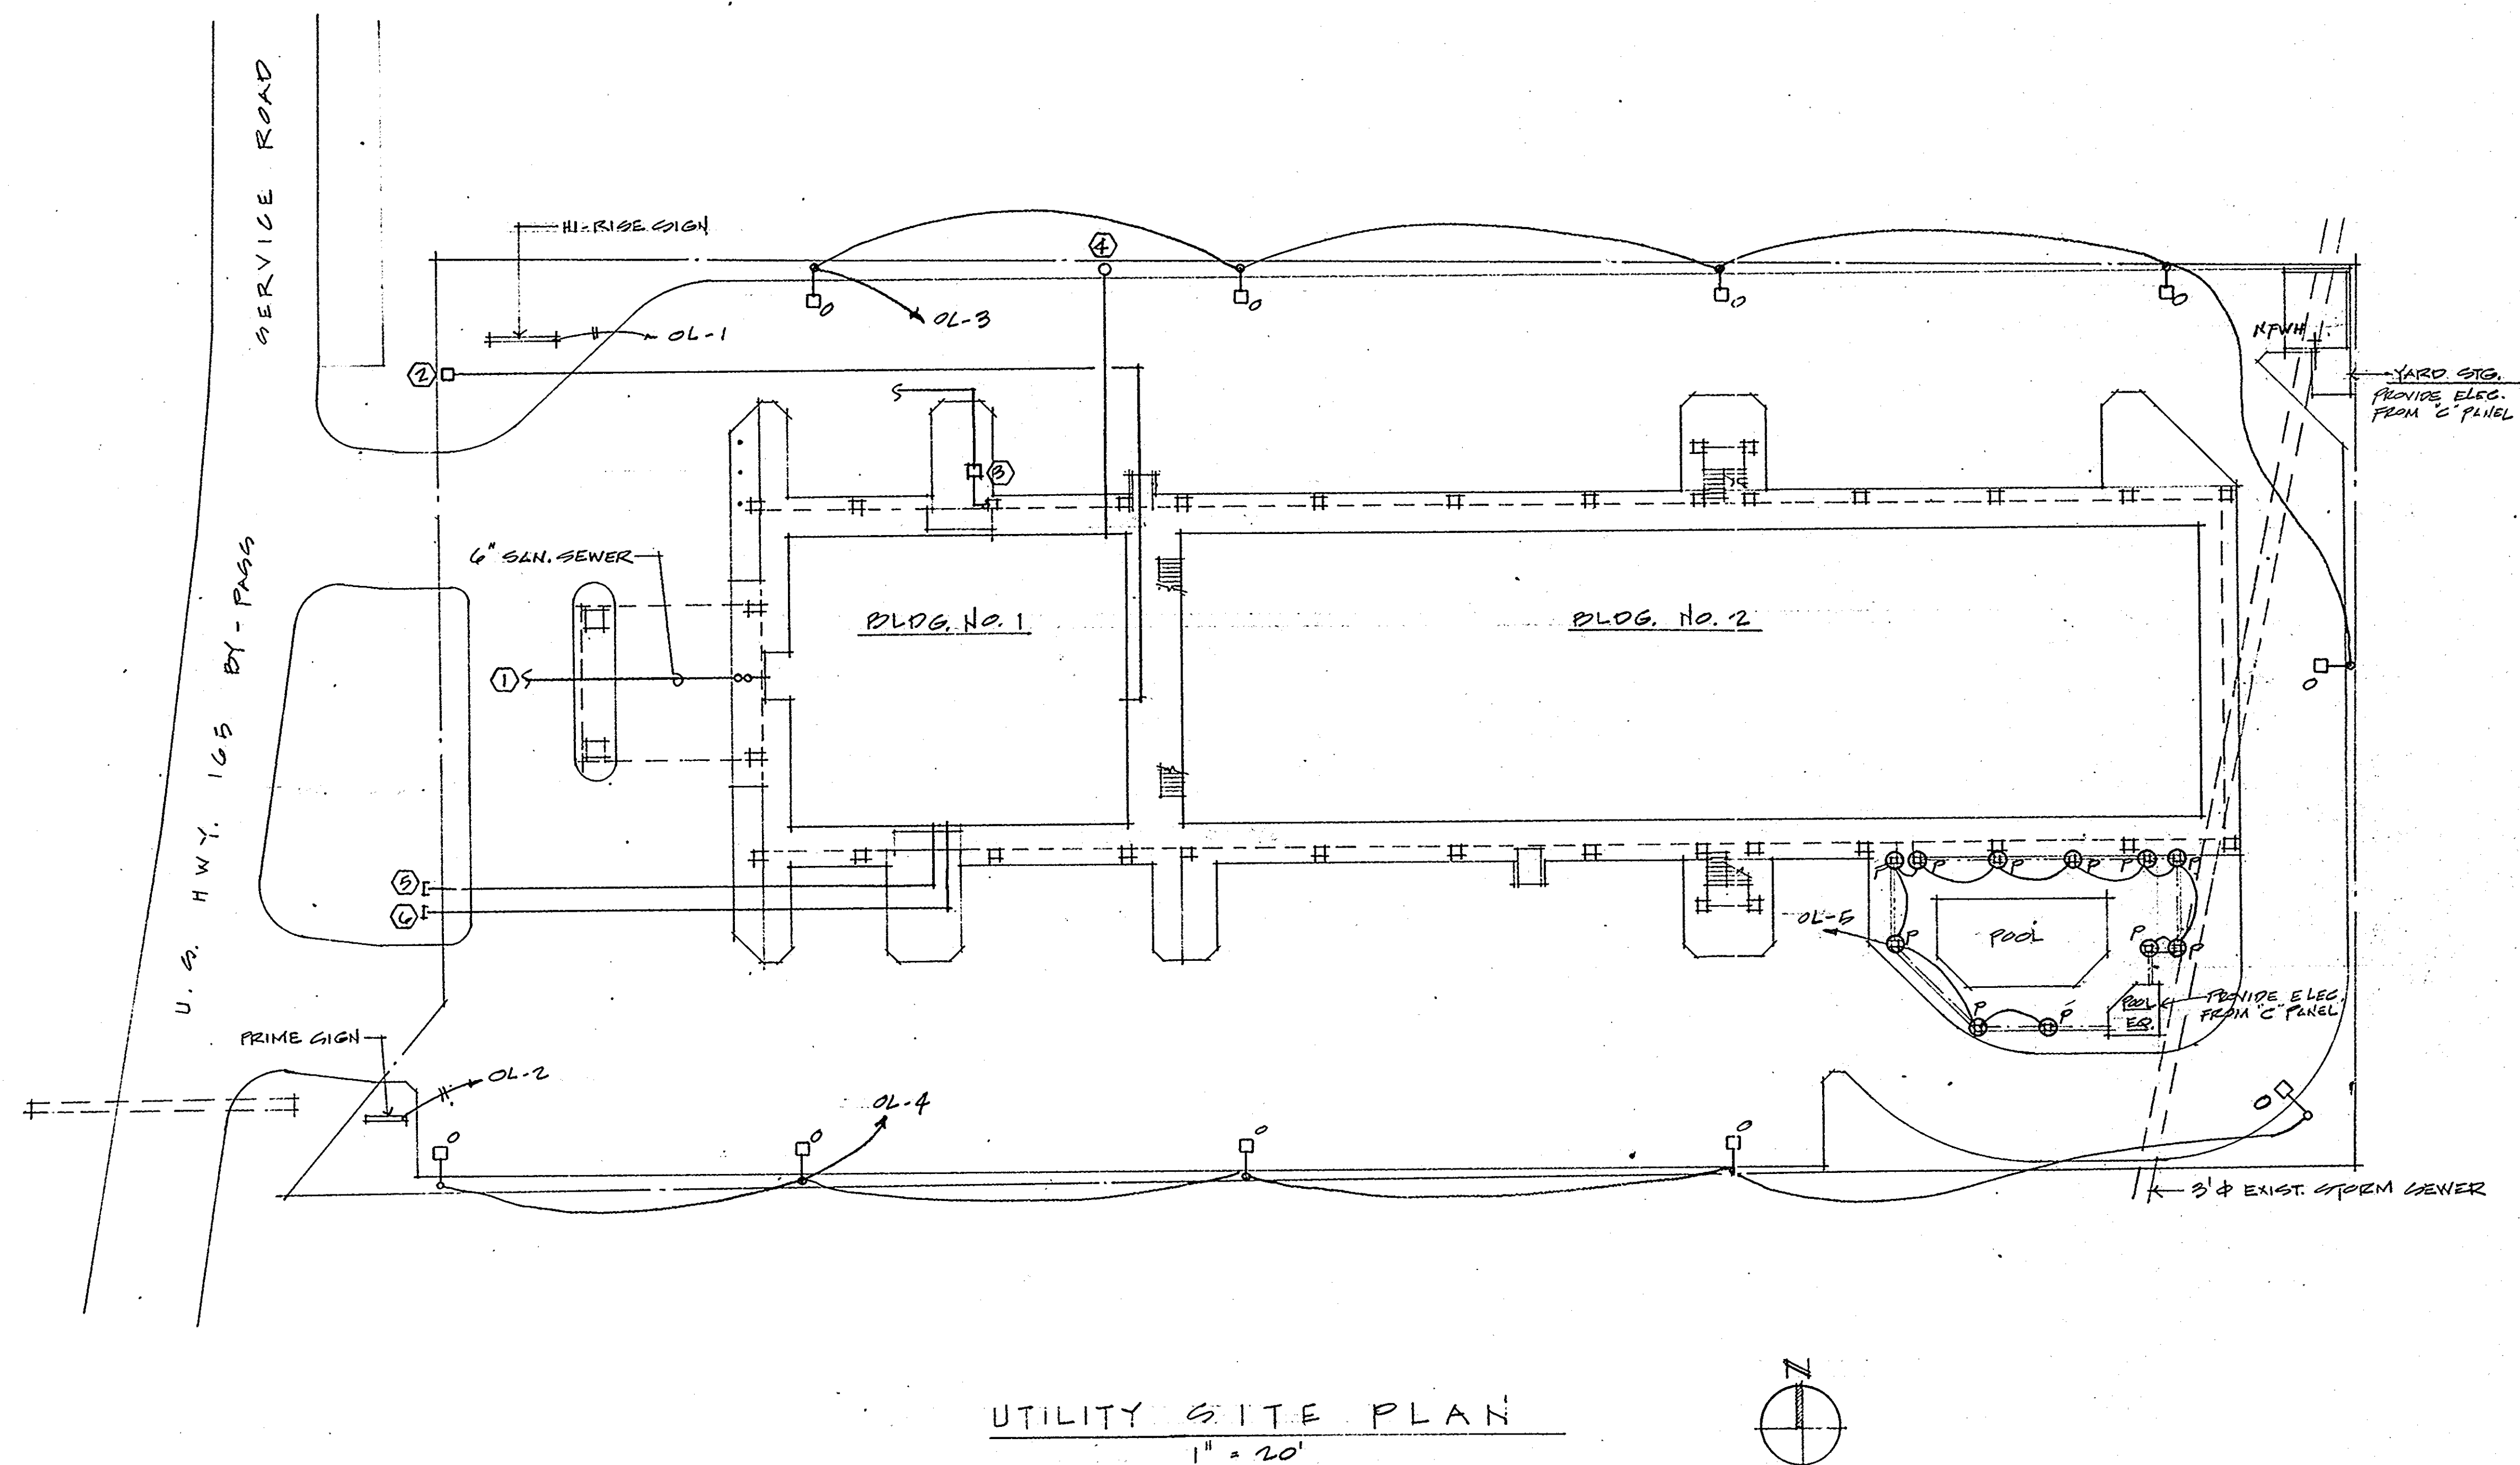


KEYNOTES

- ① COORDINATE W/LOCAL UTILITY SUPPLIER FOR EXTENSION AND TAP TO MAIN FOR NEW 6" SANITARY SEWER, AND PAY ALL COSTS.
- ② COORDINATE W/LOCAL UTILITY SUPPLIER FOR SETTING OF WATER METER & FOR EXTENSION TO MAIN, AND PAY ALL COSTS.
- ③ COORDINATE W/LOCAL UTILITY SUPPLIER FOR SETTING OF GAS METER & EXTENSION SERVICE, AND PAY ALL COSTS.
- ④ POLE MOUNTED TRANSFORMER. COORDINATE W/LOCAL UTILITY SUPPLIER FOR EXTENSION OF ELEC SERVICE & INSTALLATION OF TRANSFORMER, AND PAY ALL COSTS.
- ⑤ CONDUIT FOR T.V. SERVICE. VERIFY W/ CABLE CO.
- ⑥ 3" CONDUIT FOR PHONE SERVICE.


REV. 3-27-93

HAMPTON INN MONROE, LA		DESIGN CONSORTIUM HOTEL CONSULTANTS MEMPHIS, TENNESSEE	
UTILITY SITE PLAN	DATE	3-10-93	C-4
	SCALE		
	JOB NO.		

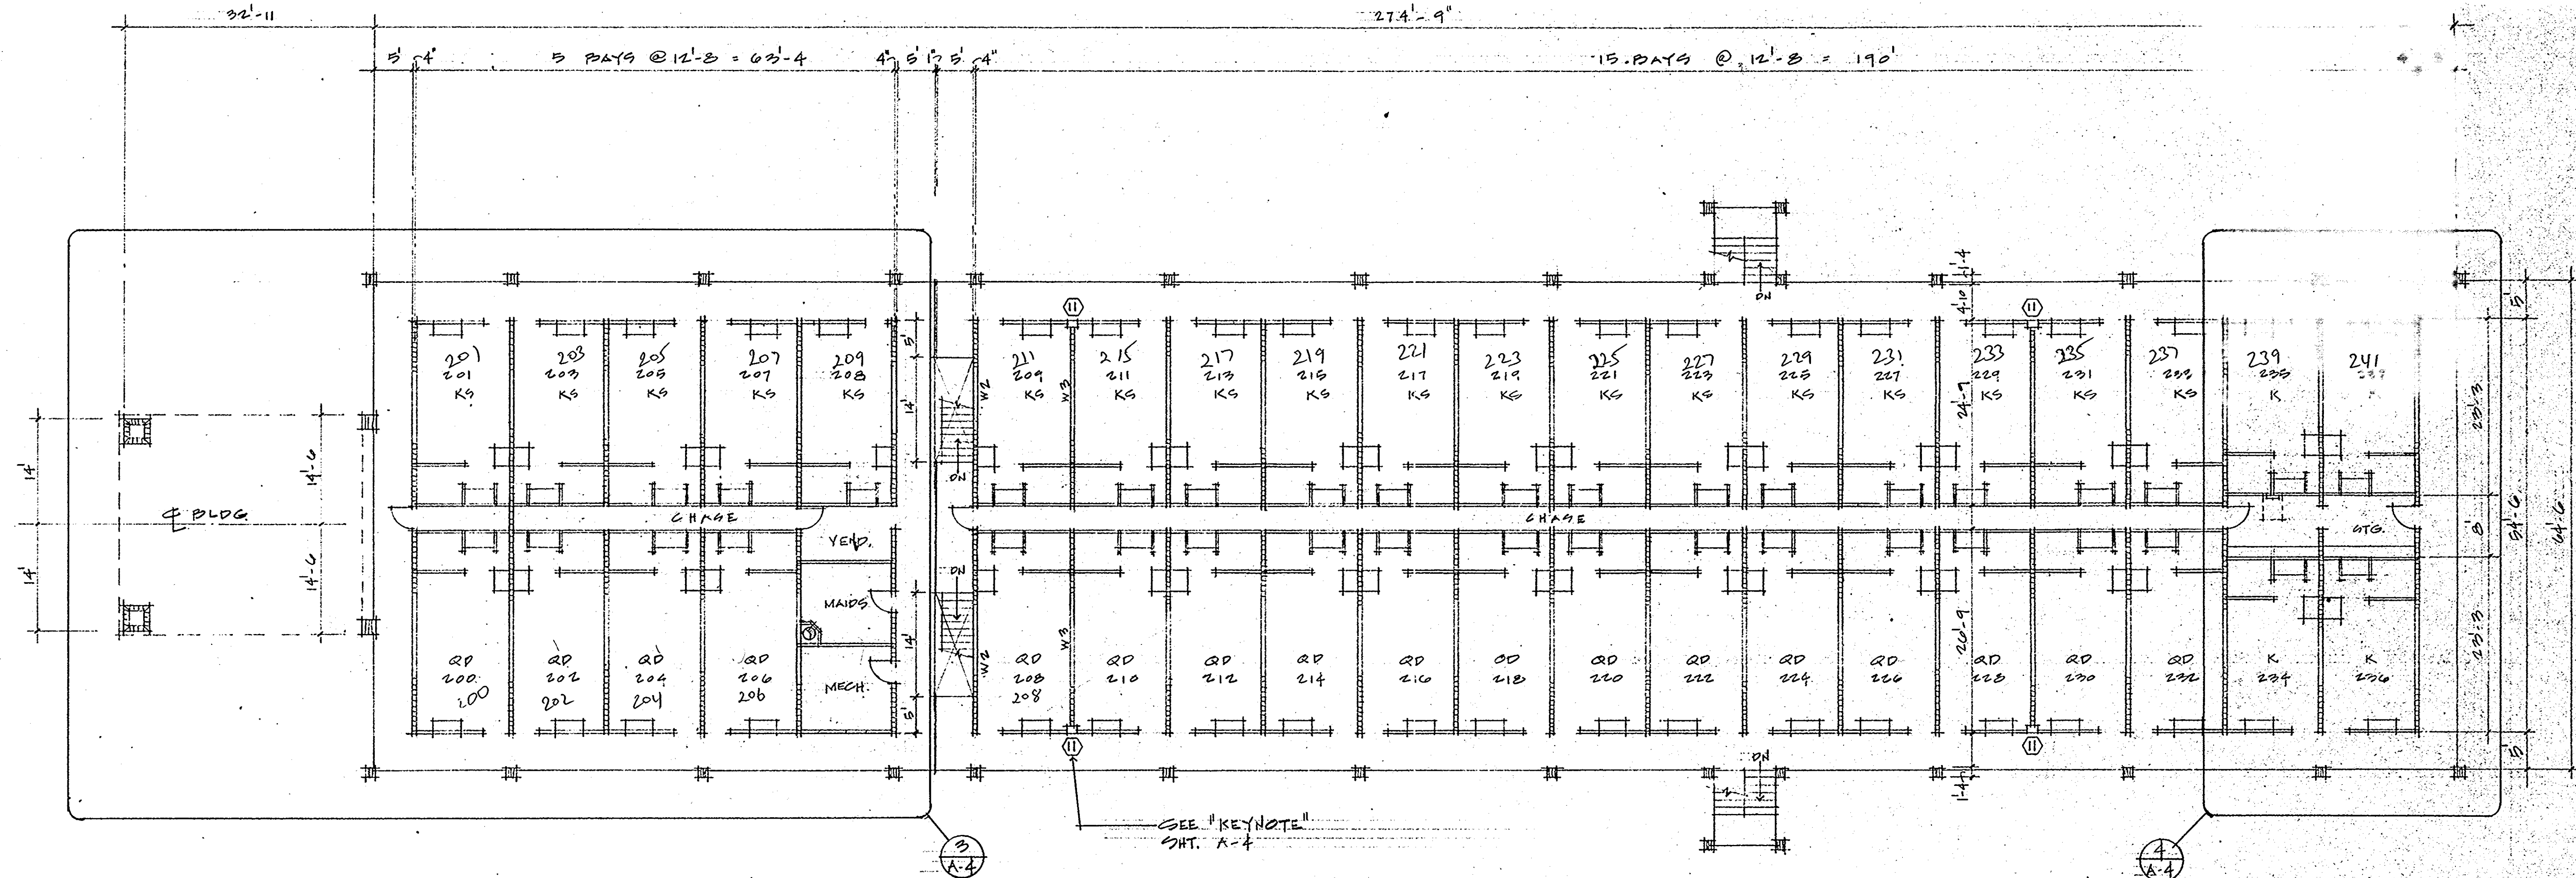




2ND FLOOR PLAN
3/32" = 1'-0"

HAMPTON INN MONROE, LA		DESIGN CONSORTIUM HOTEL CONSULTANTS MEMPHIS, TENNESSEE	
SECOND FLOOR PLAN	DATE	3-10-93	A-2
	SCALE		
	JOB NO.		

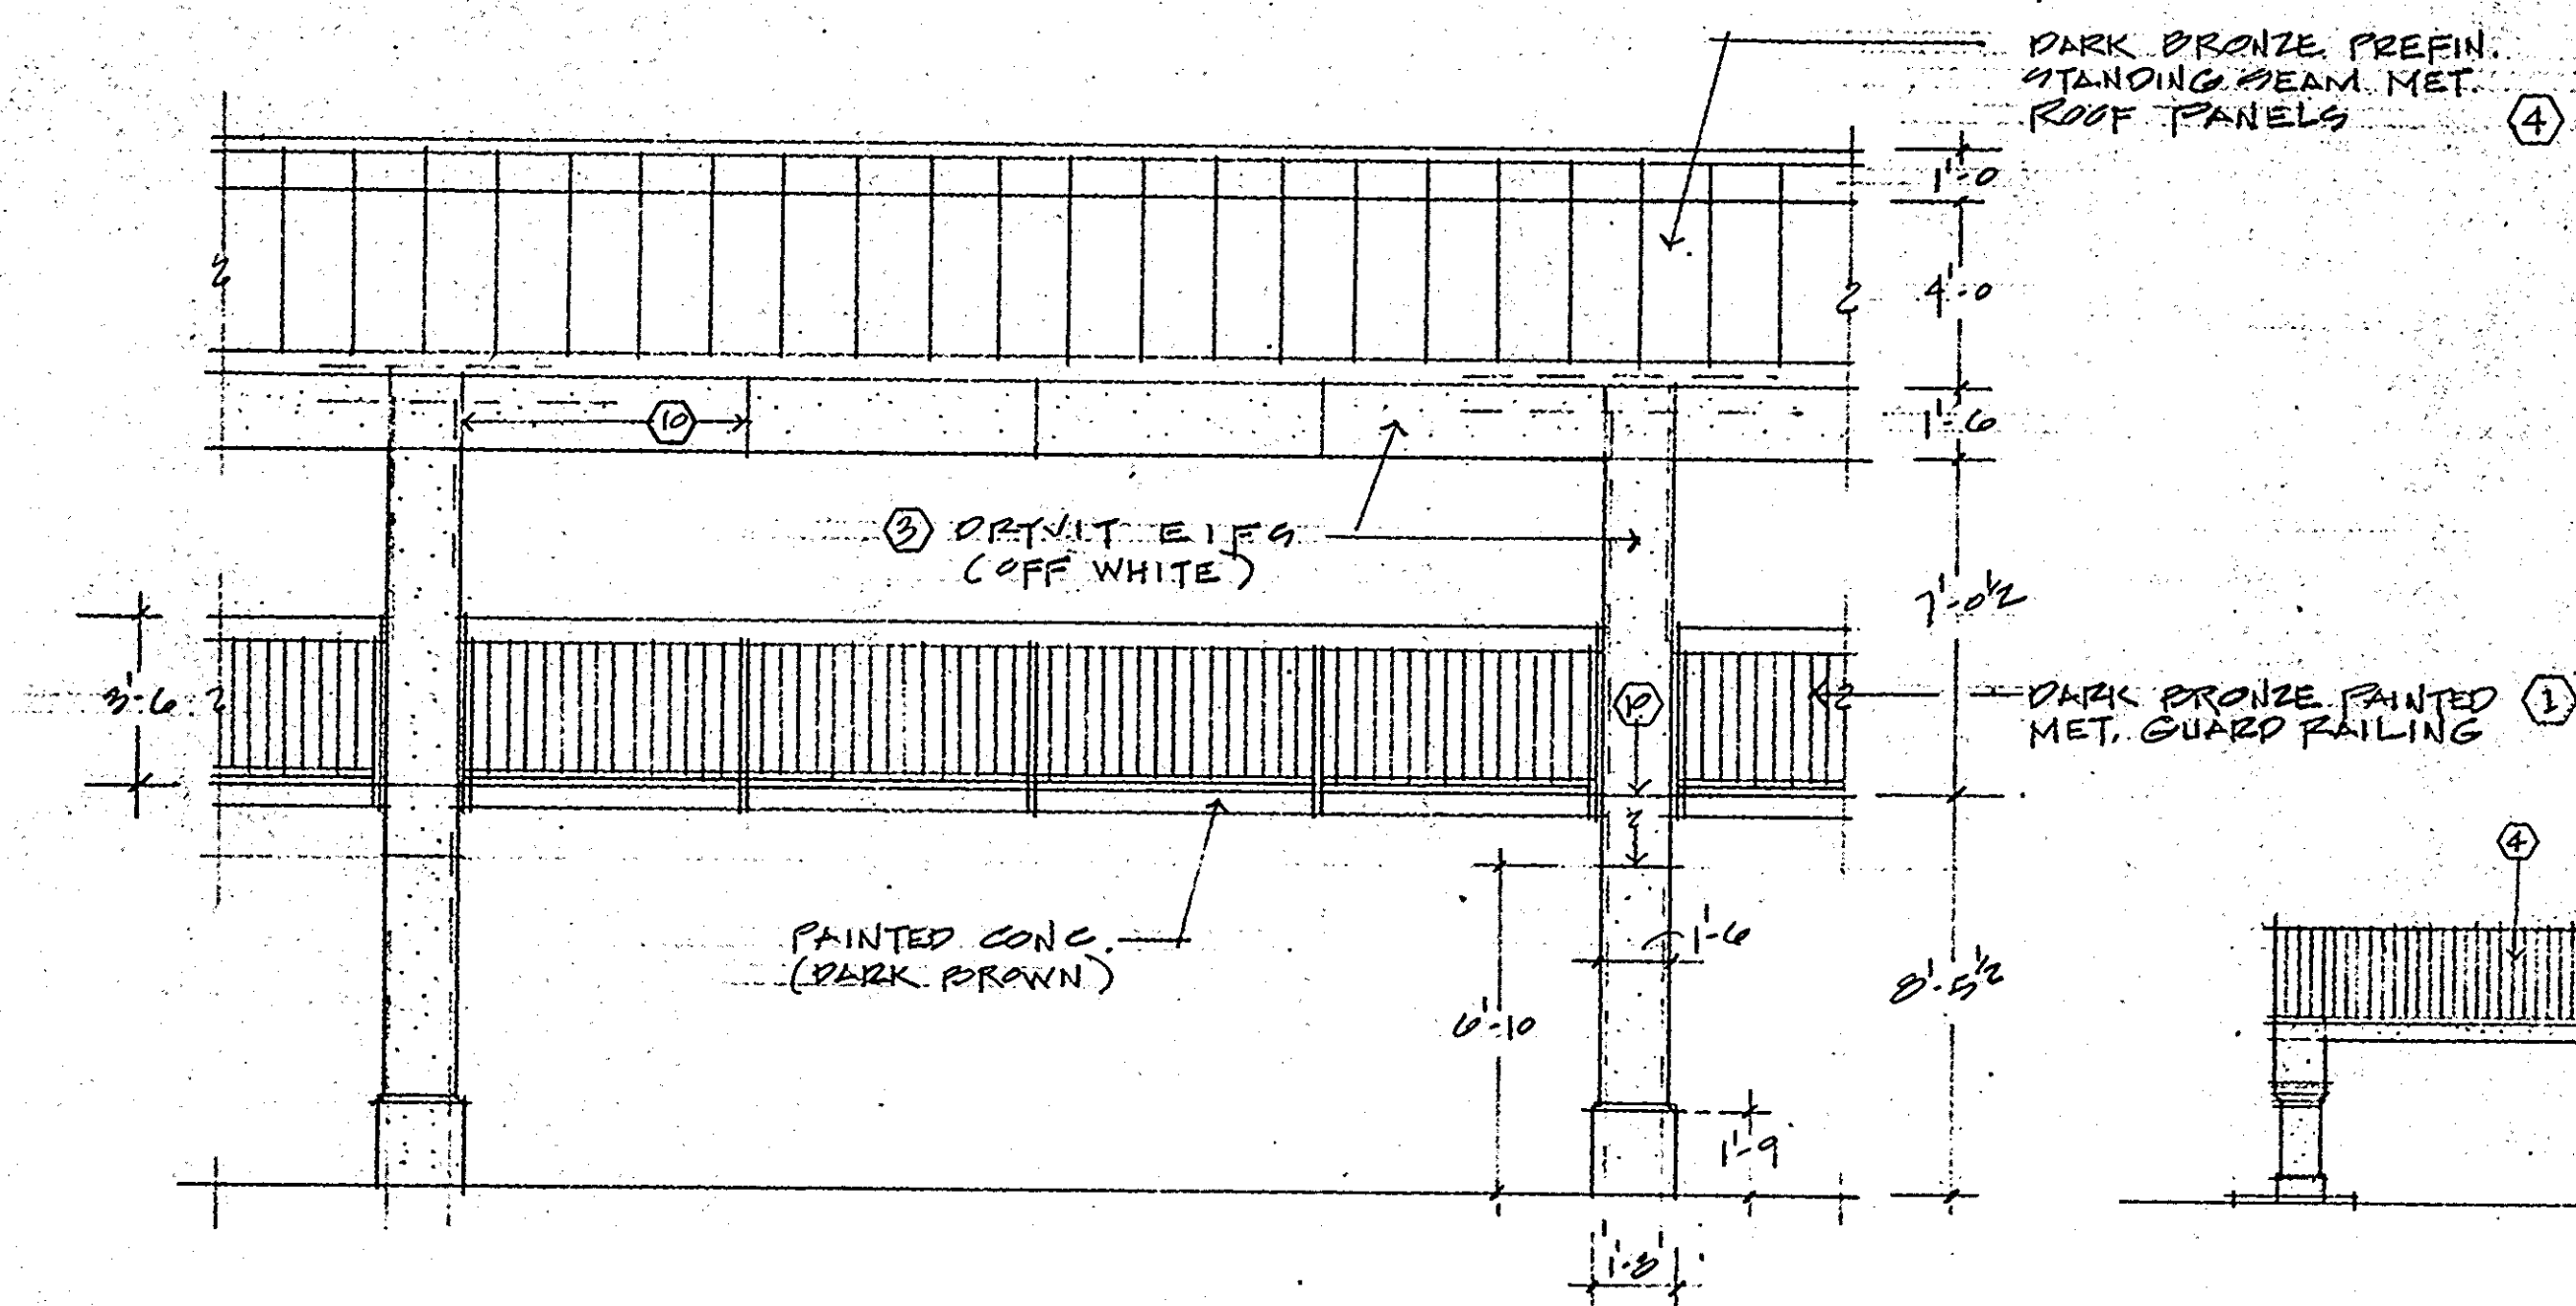

PARTIAL ELEVATION

1/4" = 1'-0"

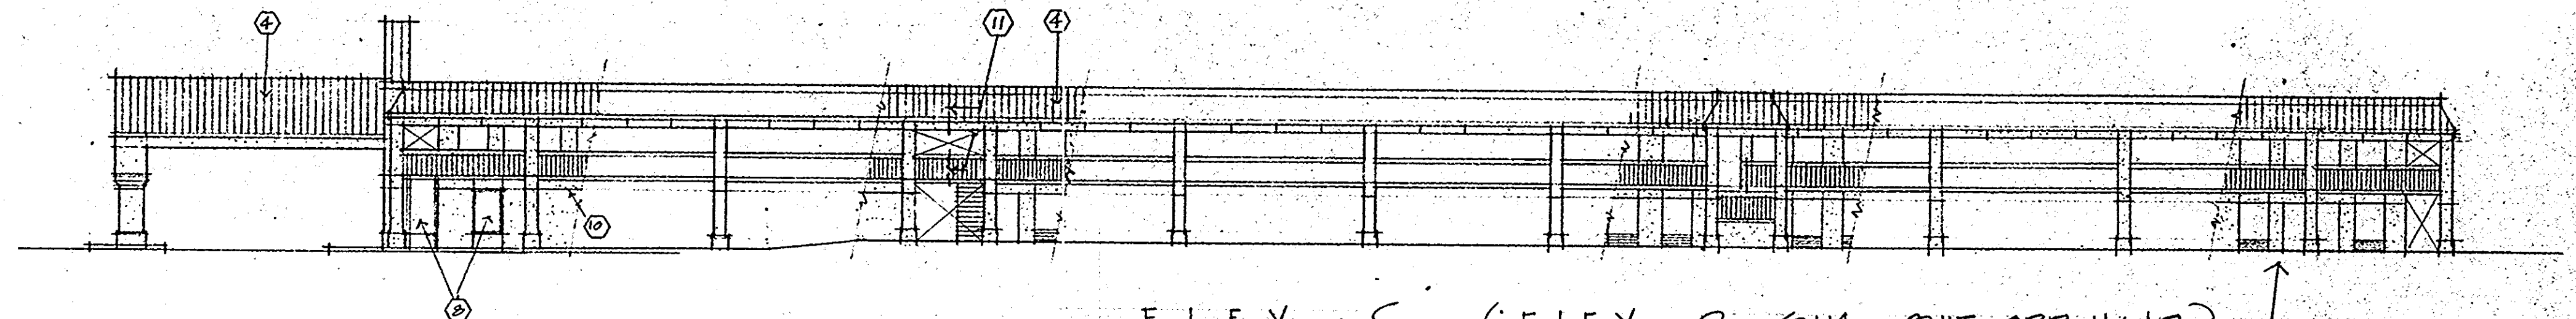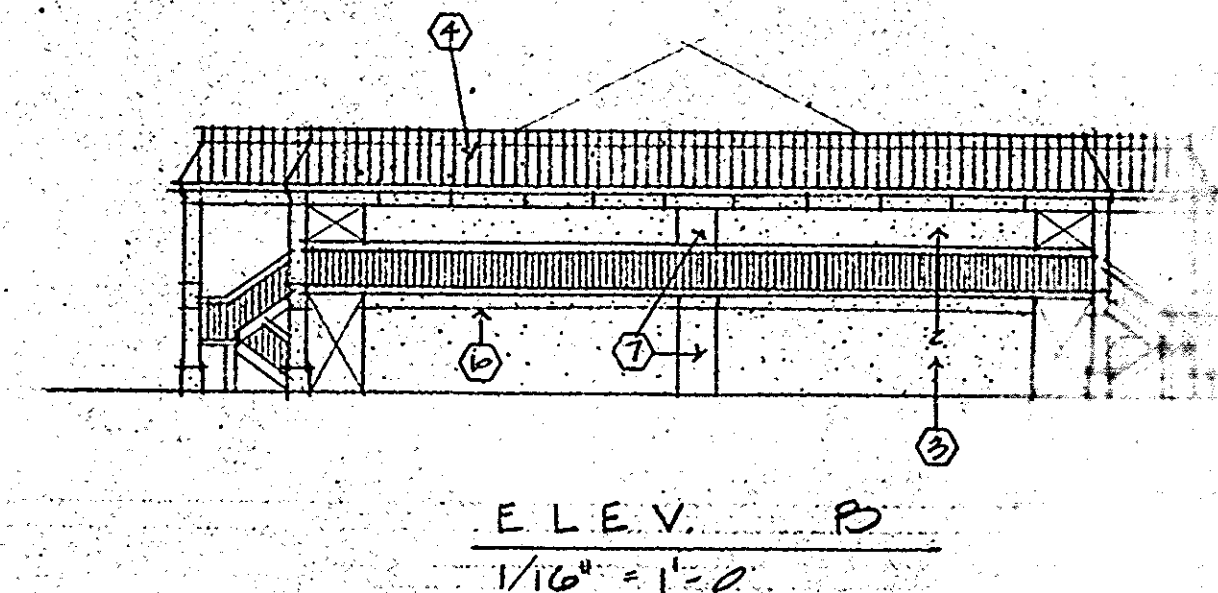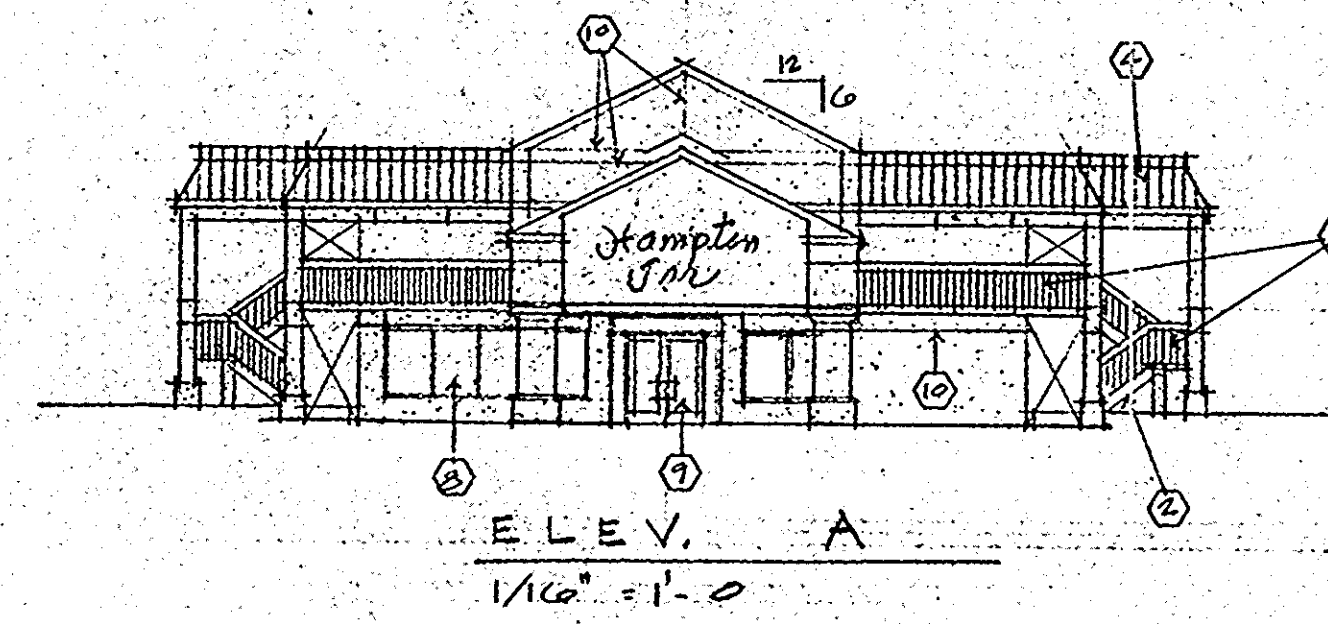


ELEV. C (ELEV. D SIM., BUT OPP. HAND)

1/16" = 1'-0"


KEYNOTES:

- 1 MET. RAILING, PAINTED (DARK BRONZE PER HAMPTON INN STDs)
- 2 STL. STAIR SYSTEM, PAINTED (DARK BROWN)
- 3 EXT INSUL. FINISH SYSTEM (OFF WHITE)
- 4 PREFIN. STANDING SEAM MET. ROOF PANELS (DARK BRONZE)
- 5 CONCEALED GUTTER & DOWNSPOUTS
- 6 SINGLE PLY. E.P.D.M. ROOFING
- 7 MET. DOOR, PAINTED
- 8 ALUM. STOREFRONT
- 9 ALUM. ENTRANCE
- 10 RUSTICATION 'V' JOINT
- 11 1" EXP. JT.

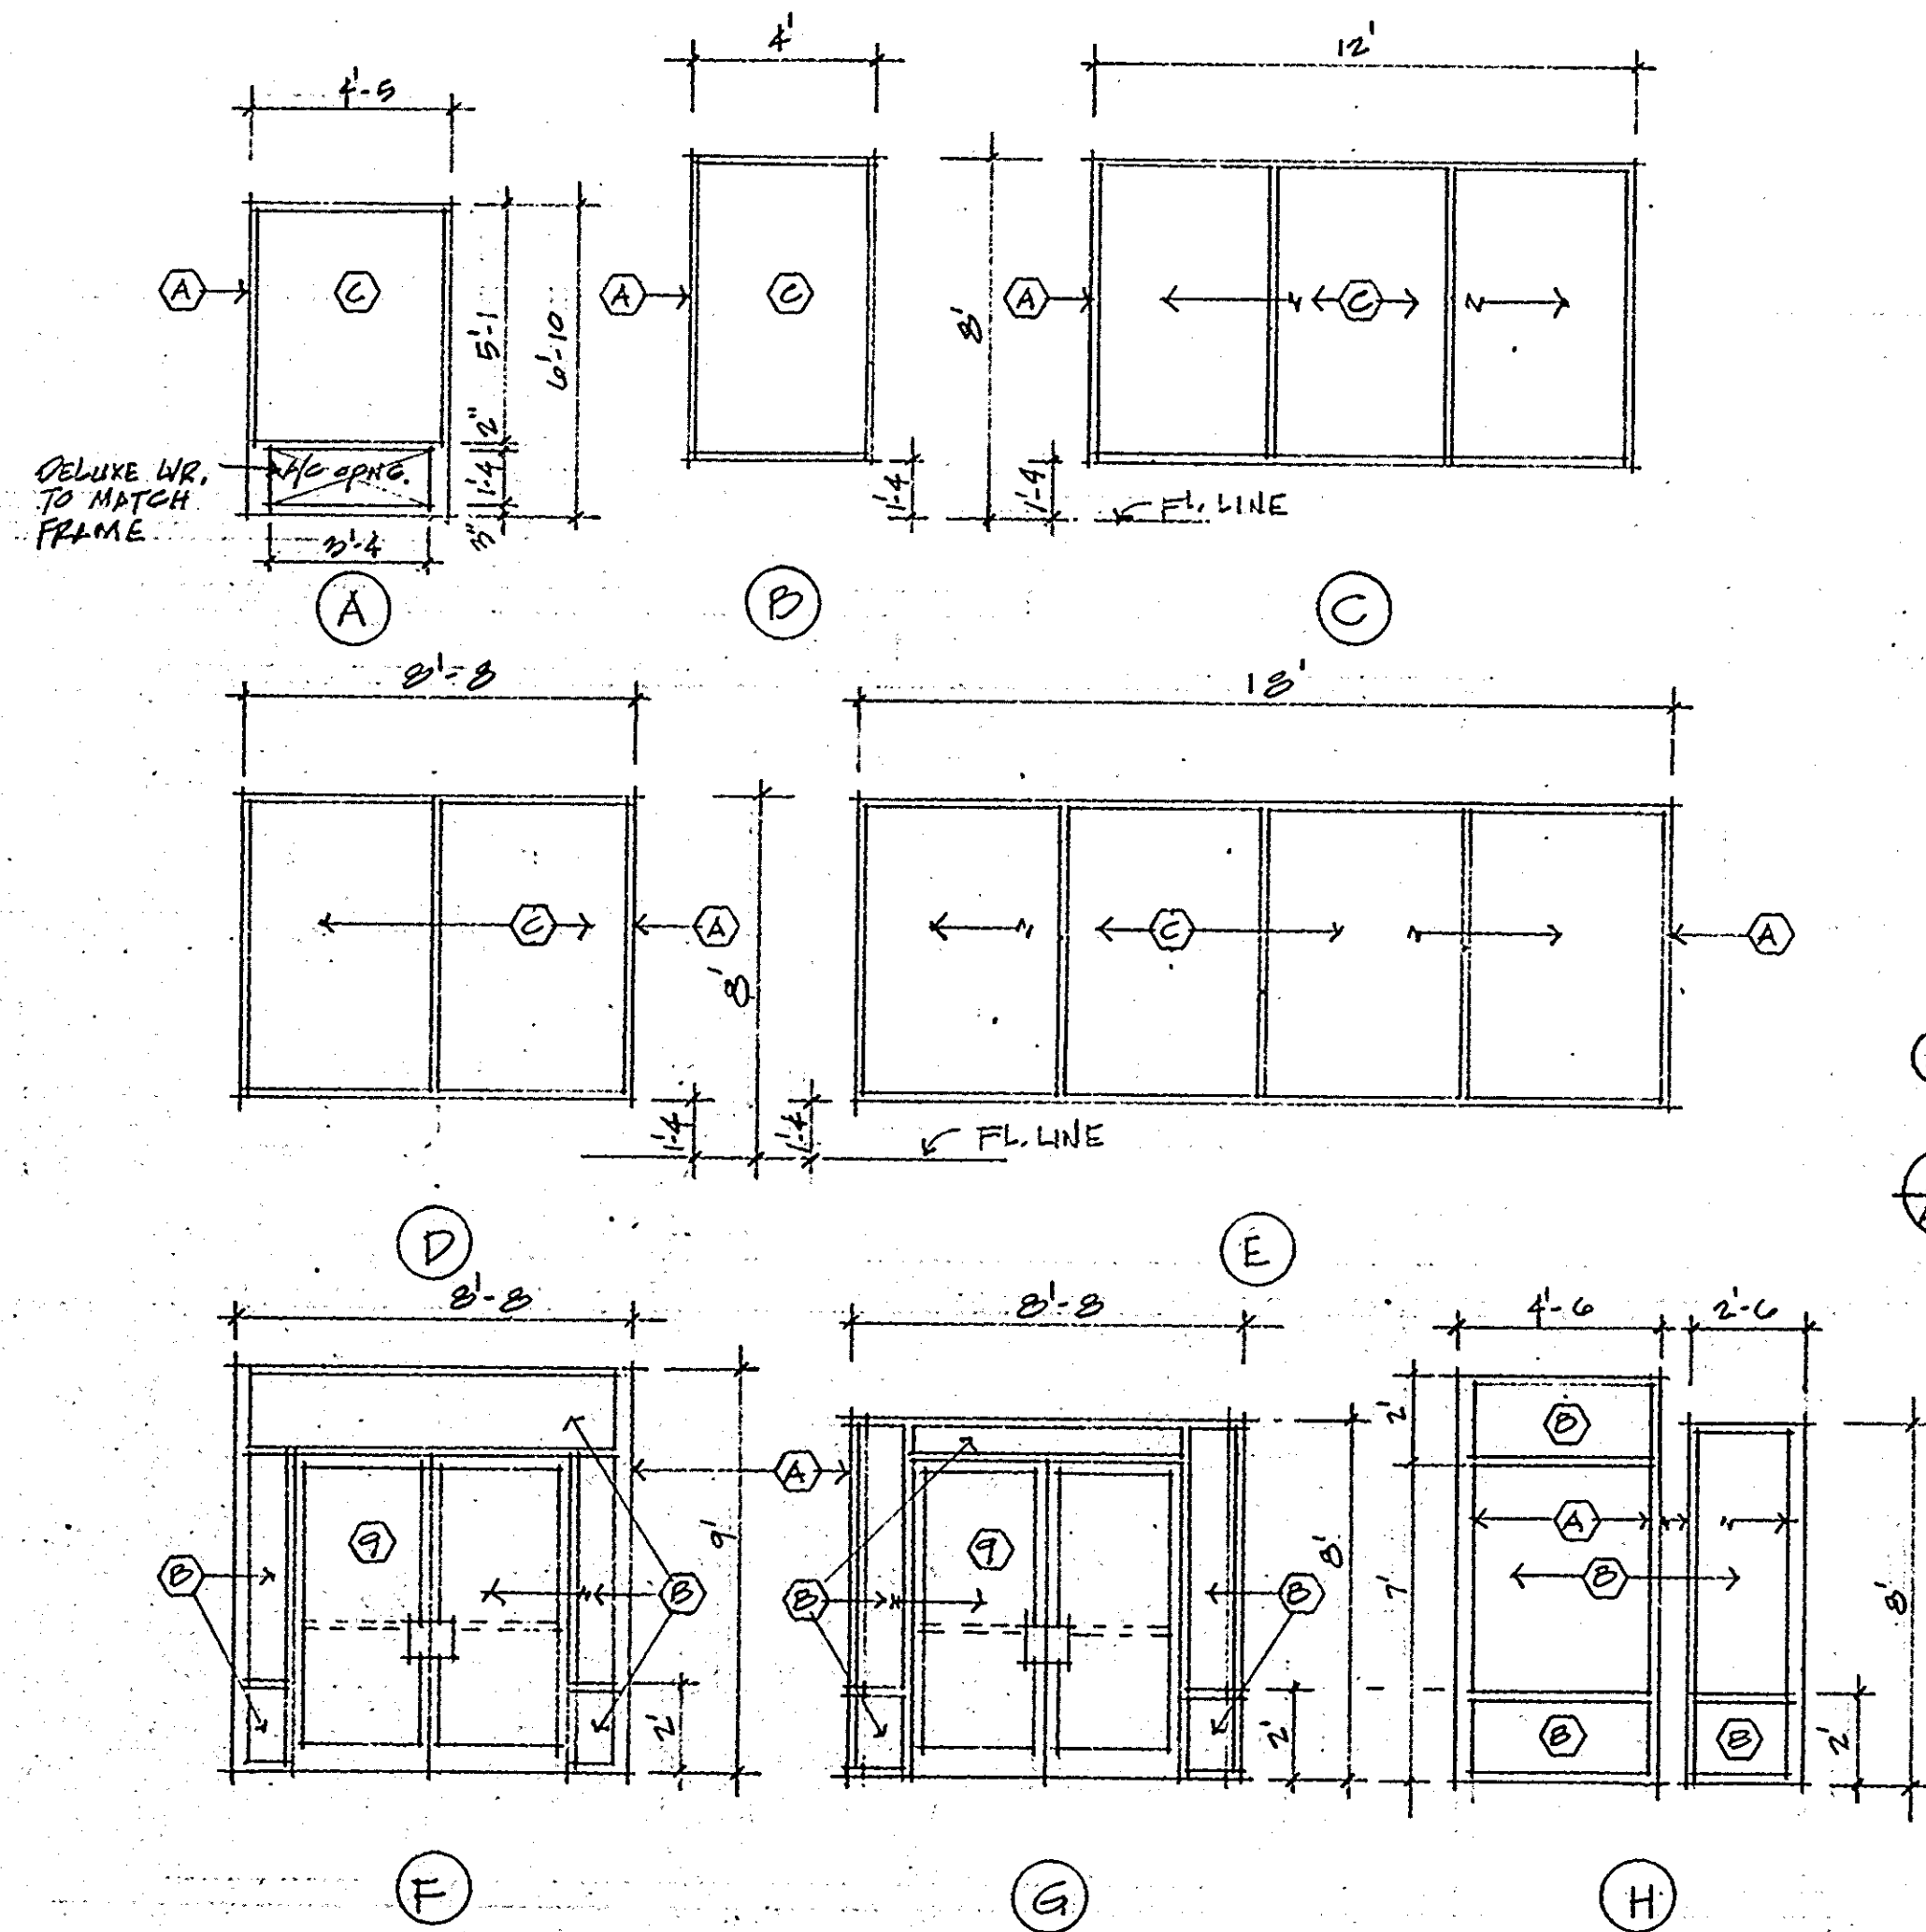

ALUM. STOREFRONT SCHEDULE

- A EXTRUDED ALUM. TUBULAR FRAME W/ FACTORY DARK BRONZE FINISH.
 - B BRONZE TINTED GLASS
 - C 5/8" INSULATING GLASS
INNER PANE CLEAR
OUTER PANE BRONZE TINTED.
- NOTE: TEMPER GLASS WHERE REQ'D PER GOVERNING ORDINANCE

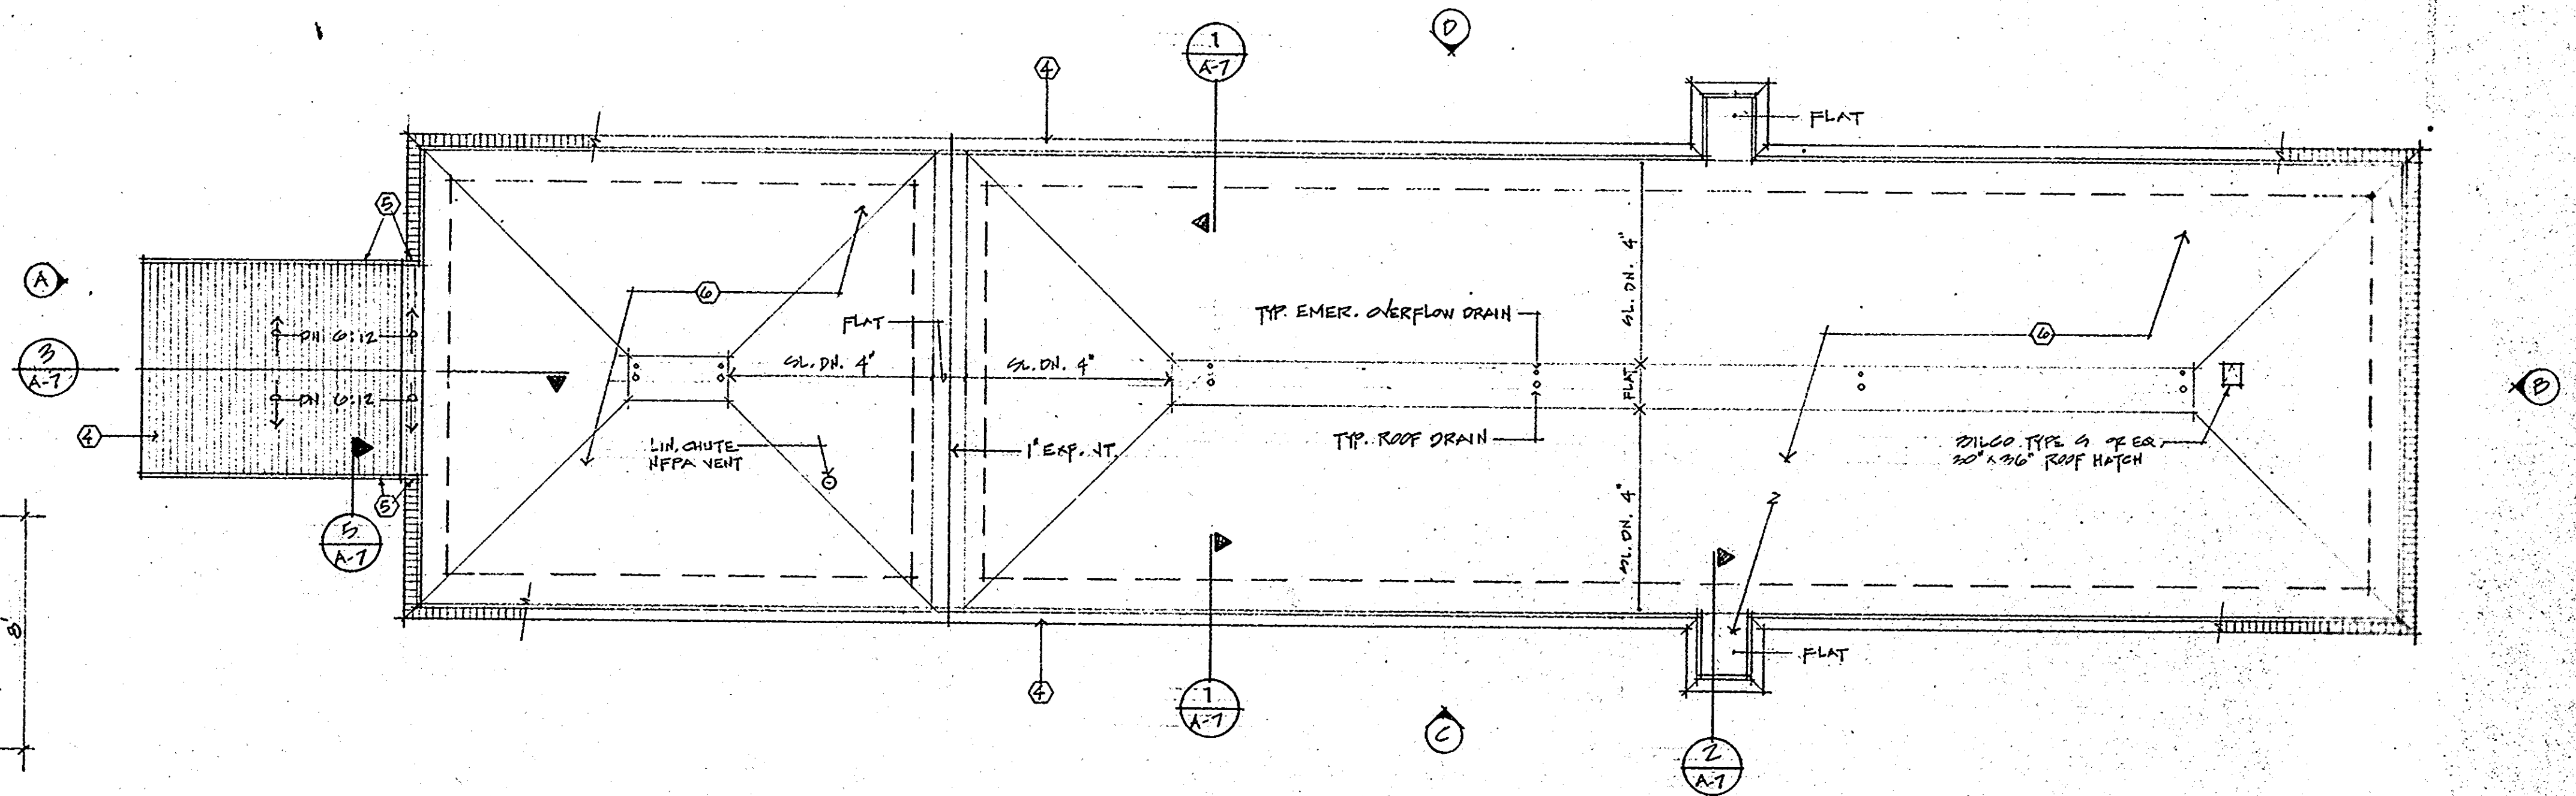

ROOF PLAN


1/16" = 1'-0"

REV. 3-27-93

HAMPTON INN MONROE, LA		DESIGN CONSORTIUM HOTEL CONSULTANTS MEMPHIS, TENNESSEE	
ROOF PLAN AND EXTERIOR ELEVATIONS		DATE	3-10-93
		SCALE	A-3
		JOB NO.	


KEYNOTES:

- FINISH CARPENTRY:**
1. 4-PLY SHELVES (4" x 8" x 8') W/ HARDWOOD NOSING, PAINTED
 2. 4-PLY SHELVES (4" x 8" x 8') W/ HARDWOOD NOSING, PAINTED W/ 1/2" RAIL STANDARDS
 3. TABLE, CONSTRUCTED W/ 2" x 4" NO. 2 S.C. DOOR OR 2X FRAME # 1888
- CABINETS - PLASTIC LAMINATE CLAD, AWT CUSTOM GRADE W/ APPROVED W/ OWNER FURNISHED INTERIOR DESIGN DOCUMENTS:**
4. BASE CABINETS W/ COUNTER & BACKSPLASH
 5. REGIST. DESK CASE (CONTR. LAYOUT SHIT E-5) SHOP SINGS. TO BE APPROVED BY HAMPTON INNS, INC.
 7. PHONE SHELF W/ 1" STATION & 1" NG ACCESSIBLE STATION
 8. PROCEDURE RACK, WALL MOUNTED
 9. BASE CABINETS W/ COUNTER & BACKSPLASH, & WALL CABINETS ABOVE
 - 10.
- SPECIALTIES AS SELECTED BY OWNER:**
11. TYPE 2A FIRE EXTINGUISHER & APPROPRIATE RECESSED CABINET
 12. LINEN CHUTE, 22" DIA., WILKINSON OR EQUAL
 - 13.
- EQUIPMENT (OWNER FURNISHED, CONTR. INSTALLED):**
14. COMP. FREEZER-REF.
 15. VENDING MACHINE
 16. ICE MACHINE
 17. COMMERCIAL WASHER/EXTRACTOR
 18. COMMERCIAL DRYER
- TOILET ACCESSORIES AS SELECTED BY OWNER:**
19. 1/2" DIA. ST. STL. GRAB BAR
 20. RECESSED OBL. ROLL TLT. PAPER HOLDER, CHROME PLATED
 21. SEMI-RECESSED PAPER TOWEL DISPENSER & WASTE RECEPTACLE EQ. TO BOBRICK
 22. CHROME PL. OBL. COAT HOOK, 2 REQ'D ON TLT. SIDE OF DOOR, MOUNT 1 @ 5'-11" AFF & 1 BELOW @ 3'-4" AFF.

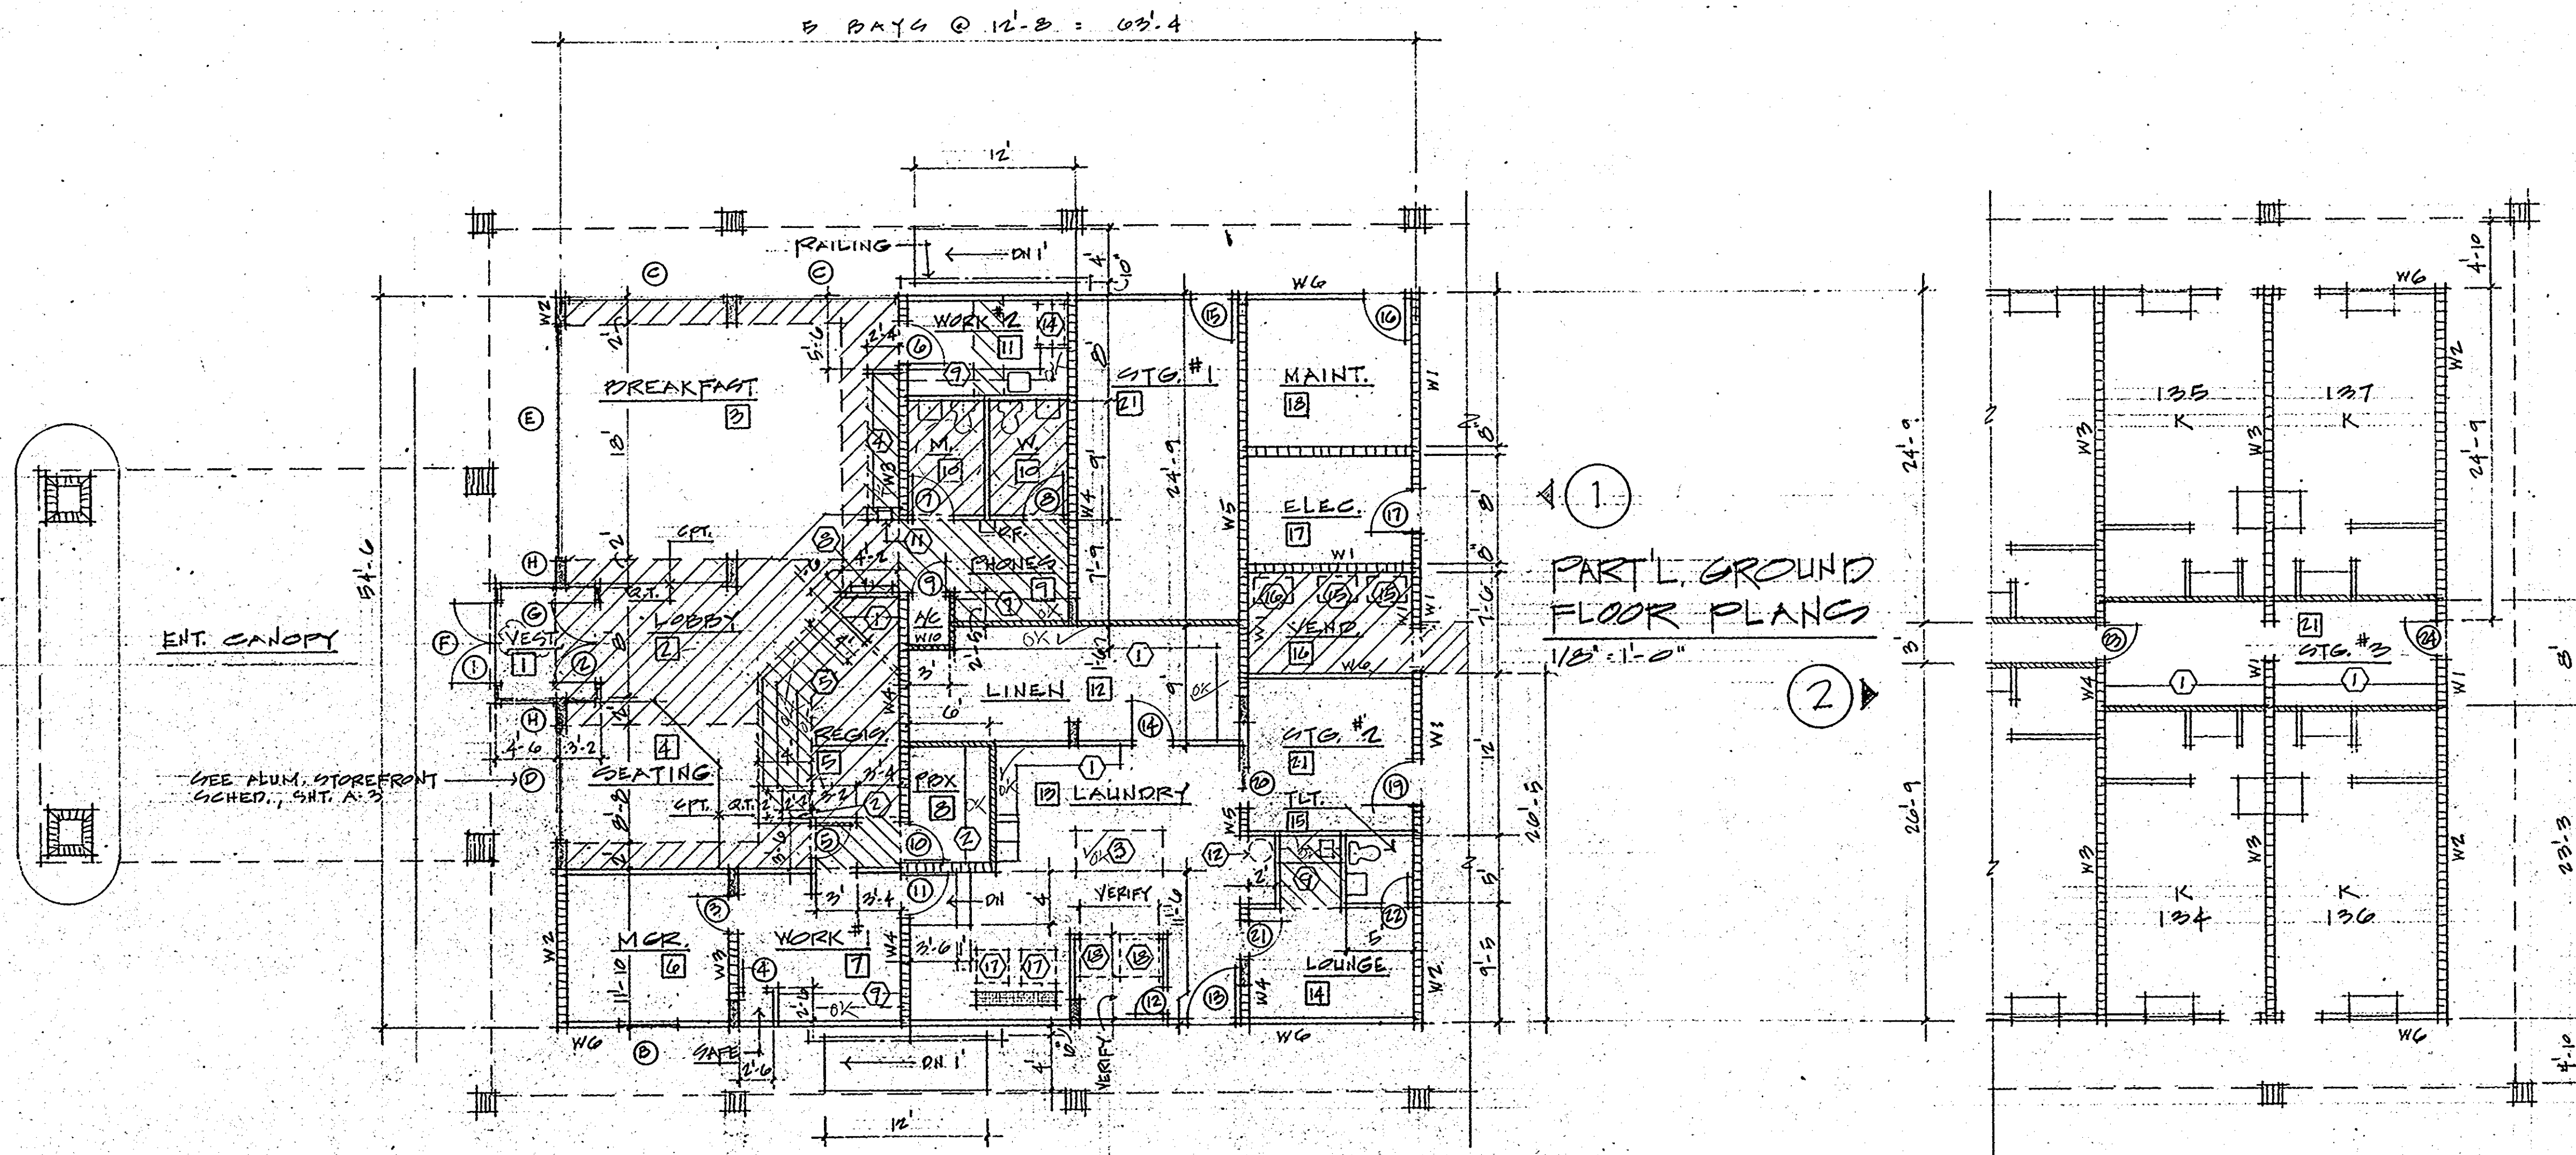



LEGEND

- 8" MIN. CONC. BLK.
- STUD PART'N. - 1 HR (WB UNLESS NOTED)
- STUD PART'N. (WT UNLESS NOTED)
- STUD PART'N. - 2 HR (WIO)
- FURRED CLG. 7' AFF (WIO FRAMED ABOVE REGIST. DESK)
- FURRED CLG. 8' AFF.

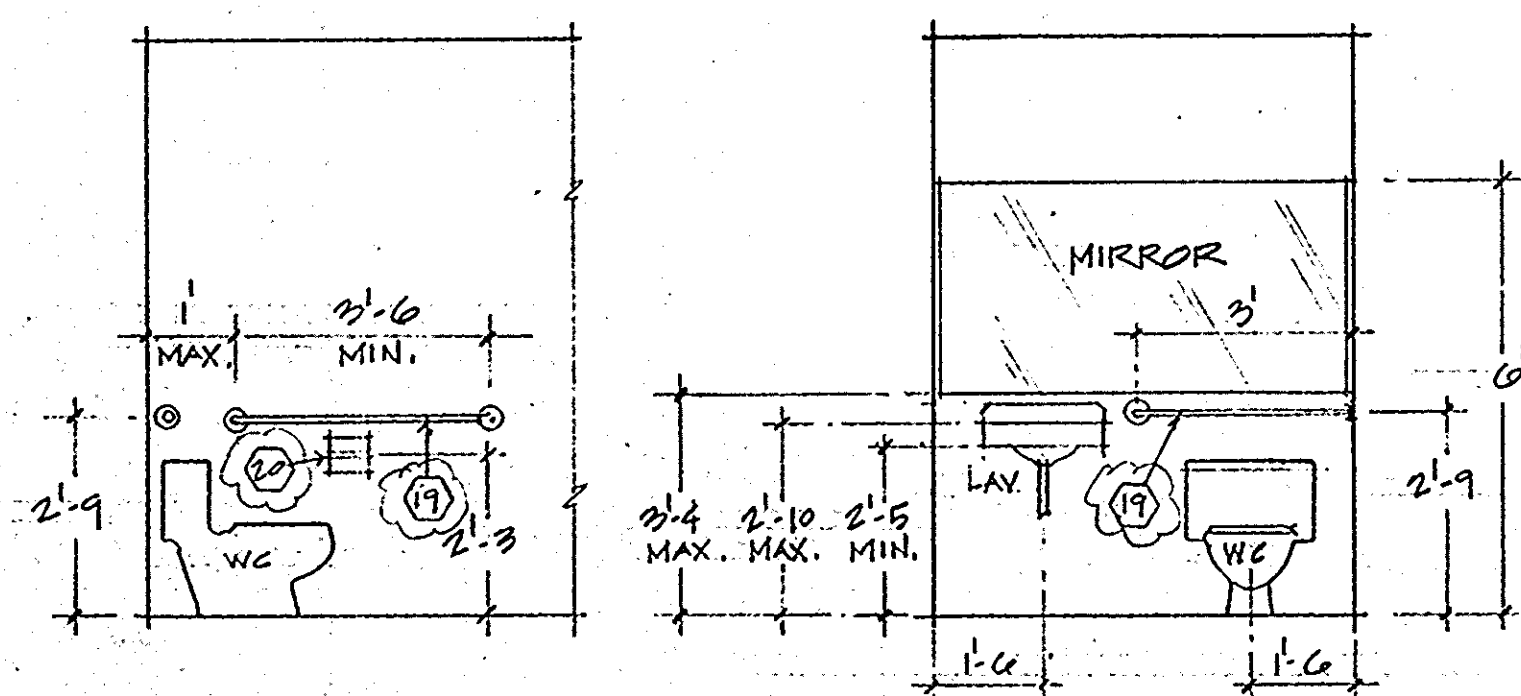

TLT. NO. 10 ELEVATIONS

1. THIS
1. OPP. HAND

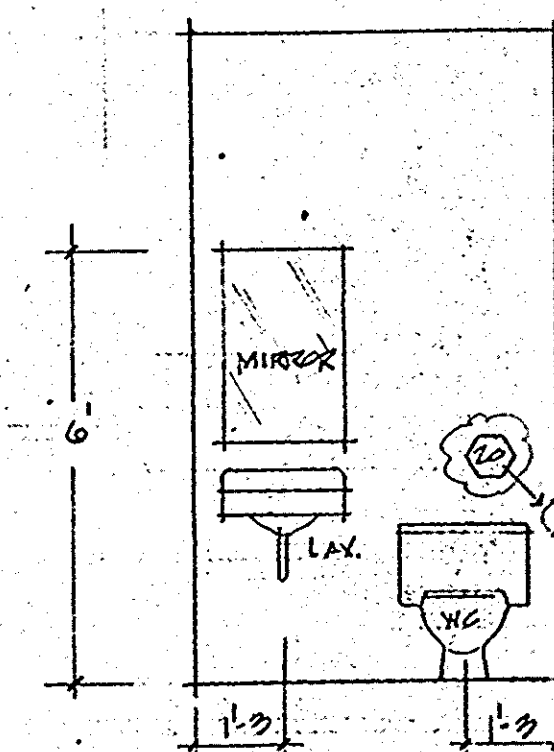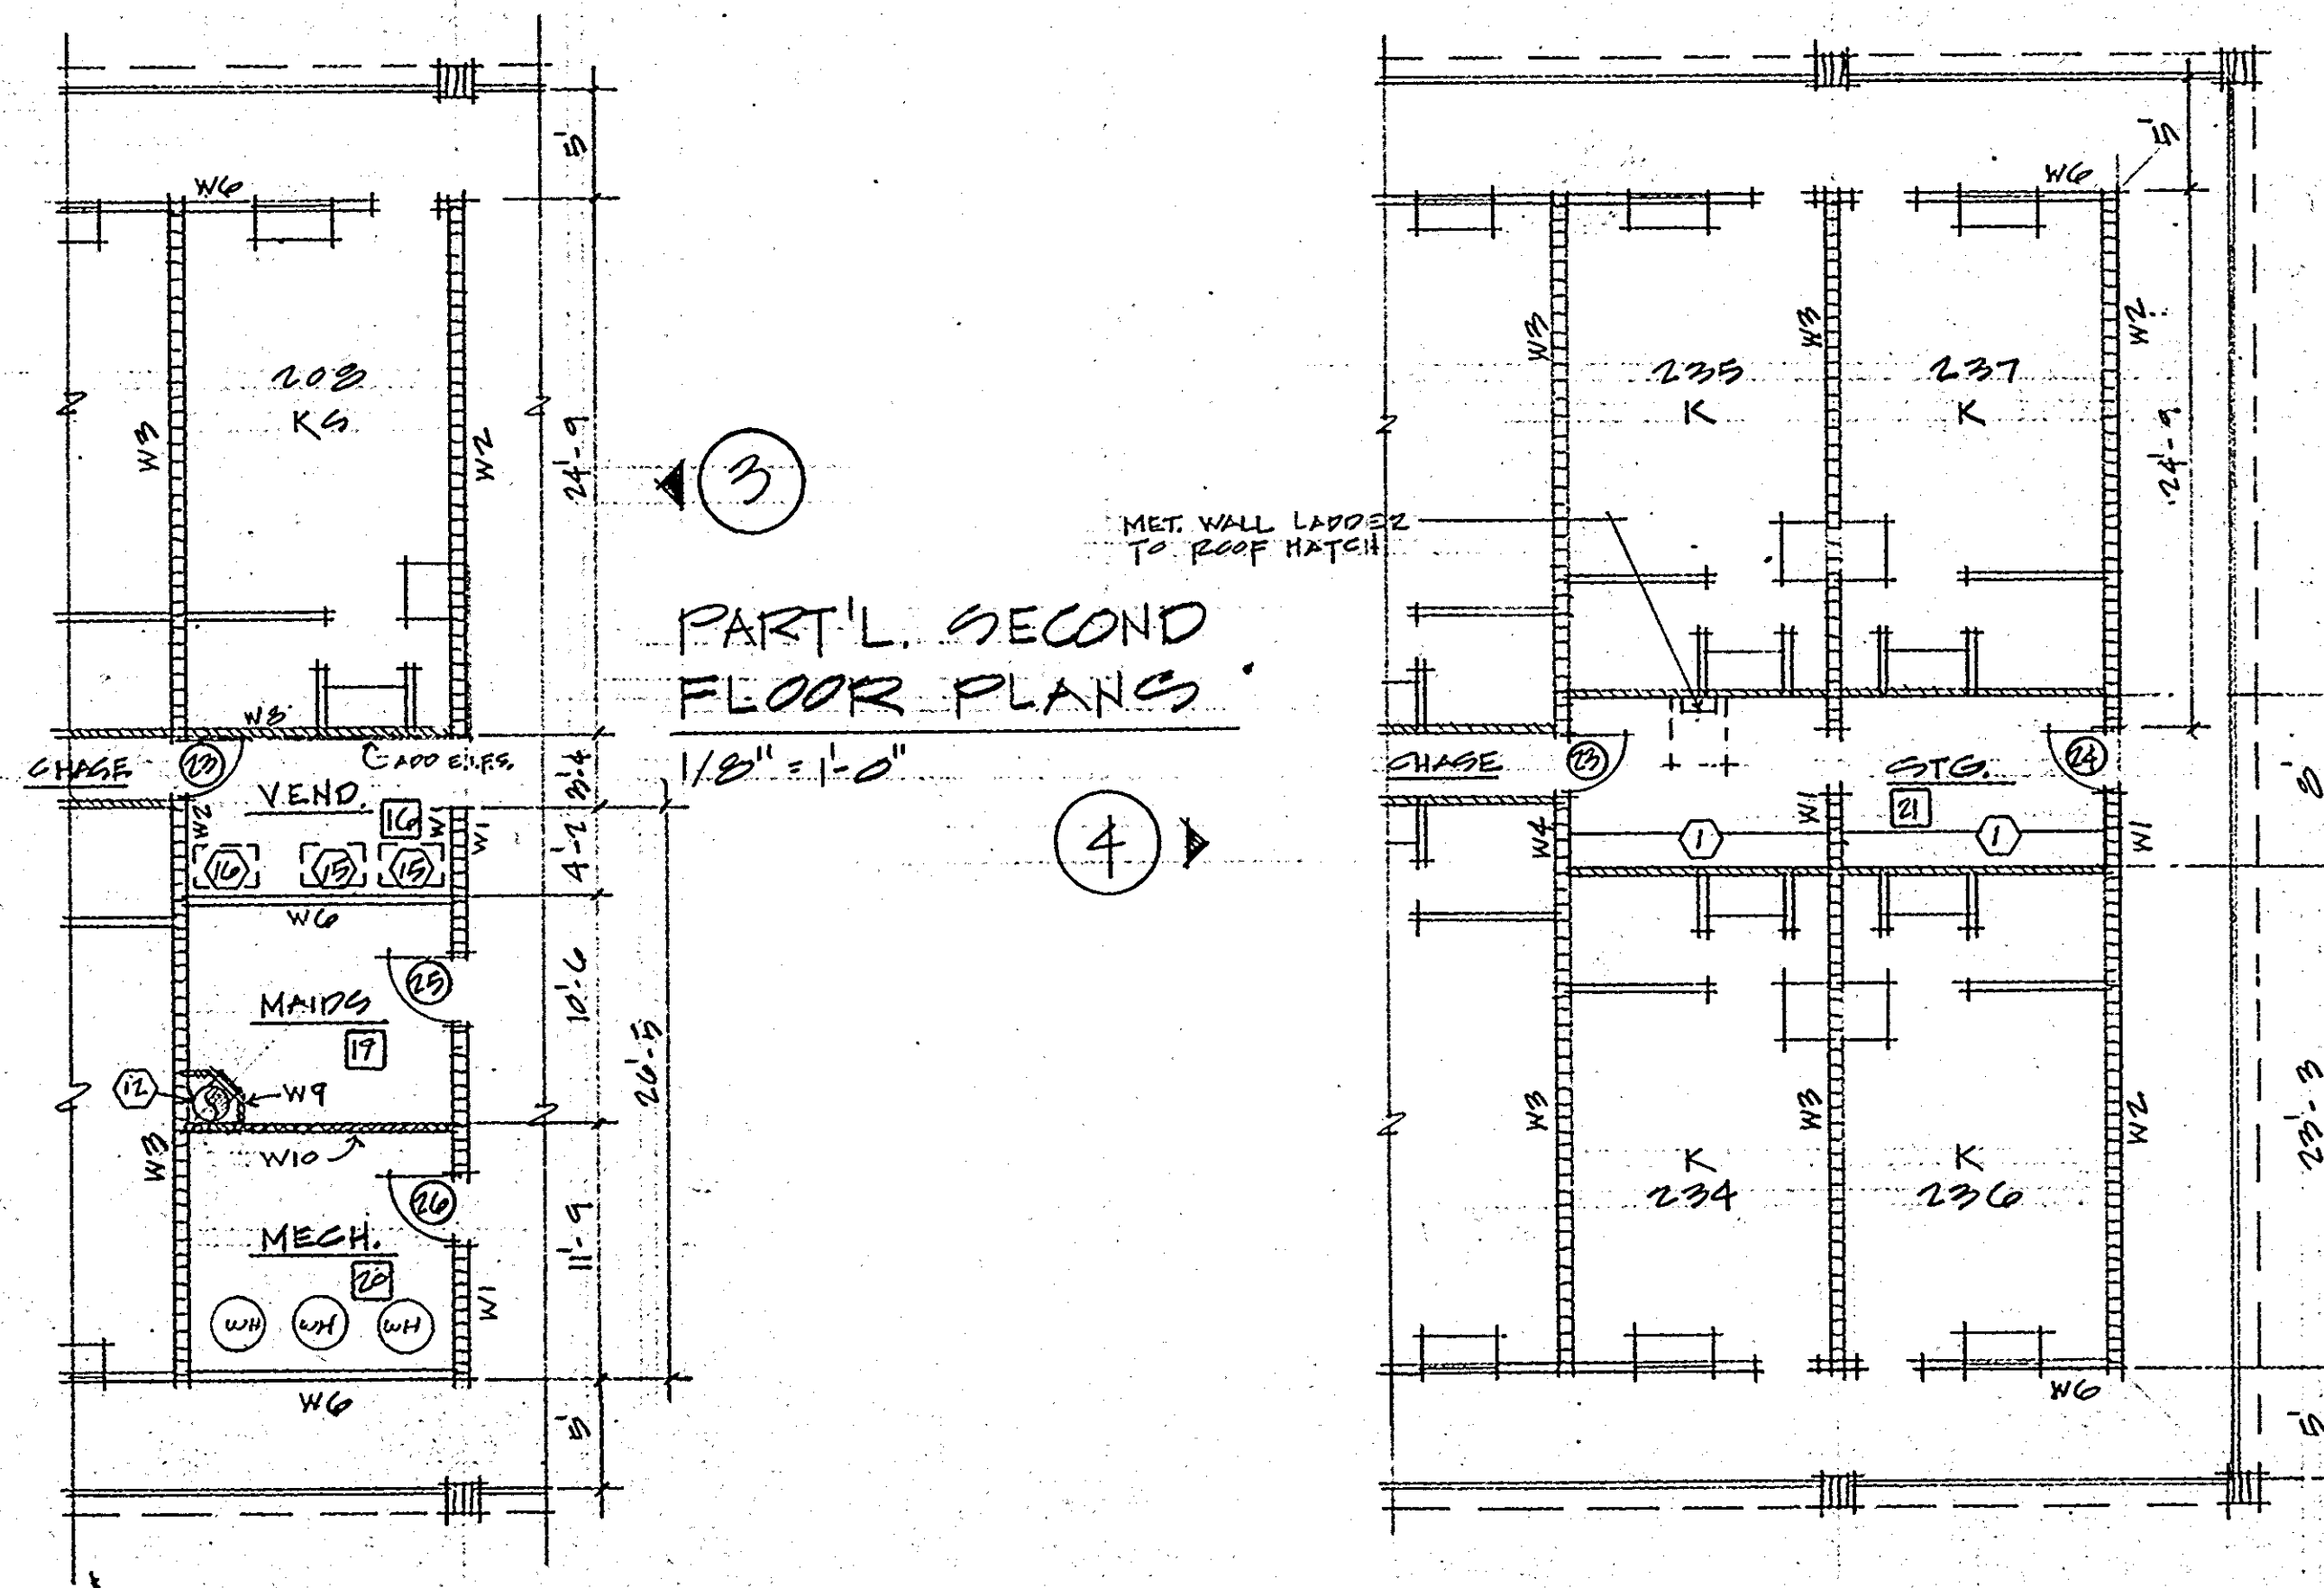


TLT. NO. 15 ELEV.

1/8" = 1'-0"


4-24-93
REV. 3-27-93

COMMERCIAL / SERVICE AREA FLOOR PLANS	DESIGN CONSORTIUM HOTEL CONSULTANTS MEMPHIS, TENNESSEE	
	DATE	3-10-93
	SCALE	A-4
JOB NO.		

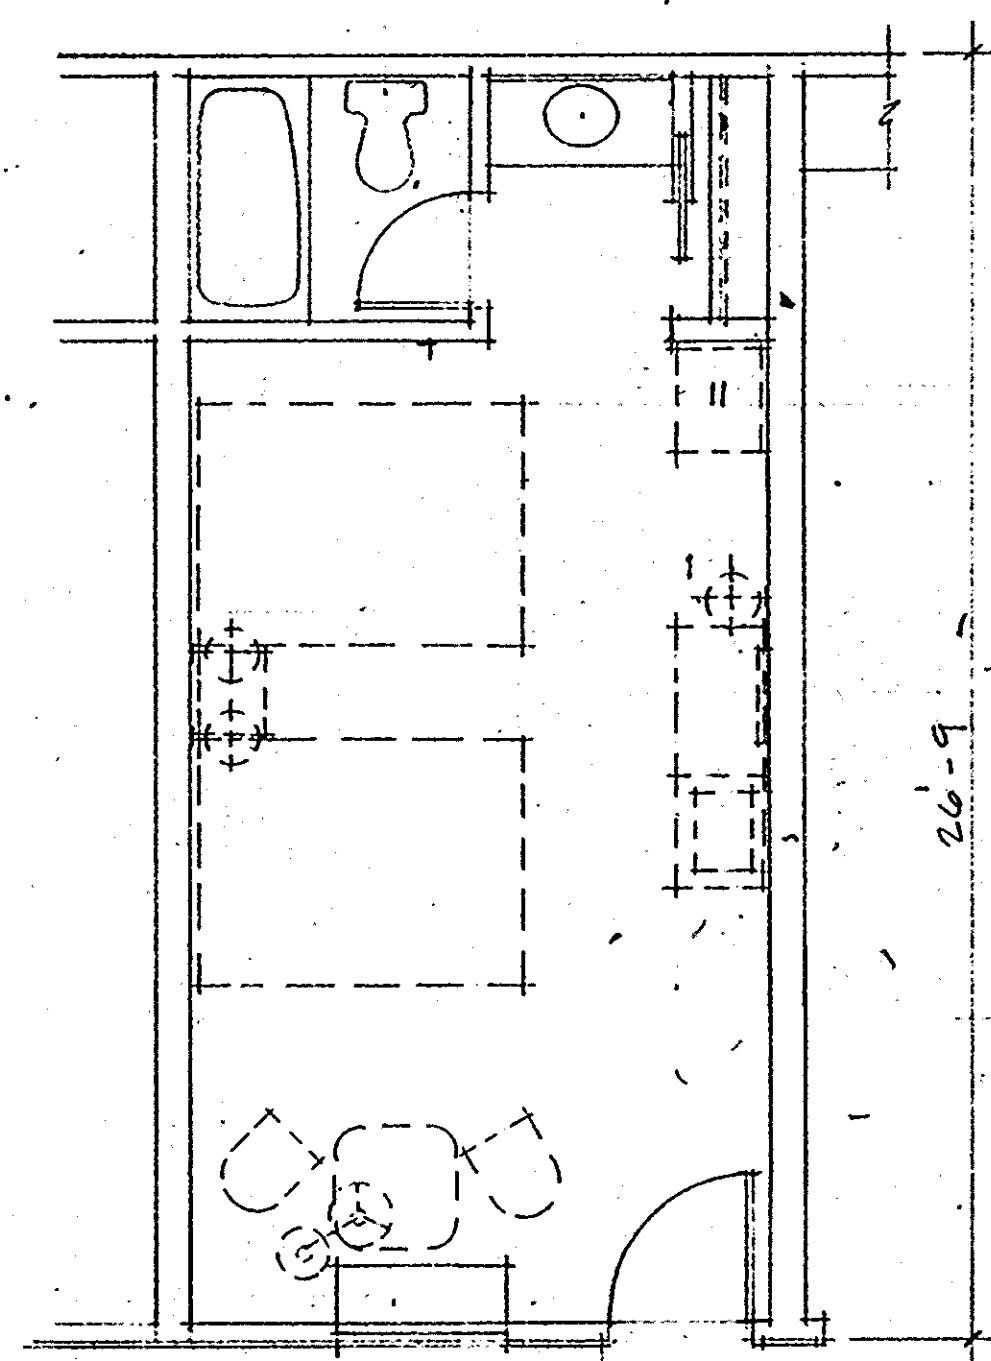


TYP. QUEEN - DBL. RM. (QD)

1/4" = 1'-0"

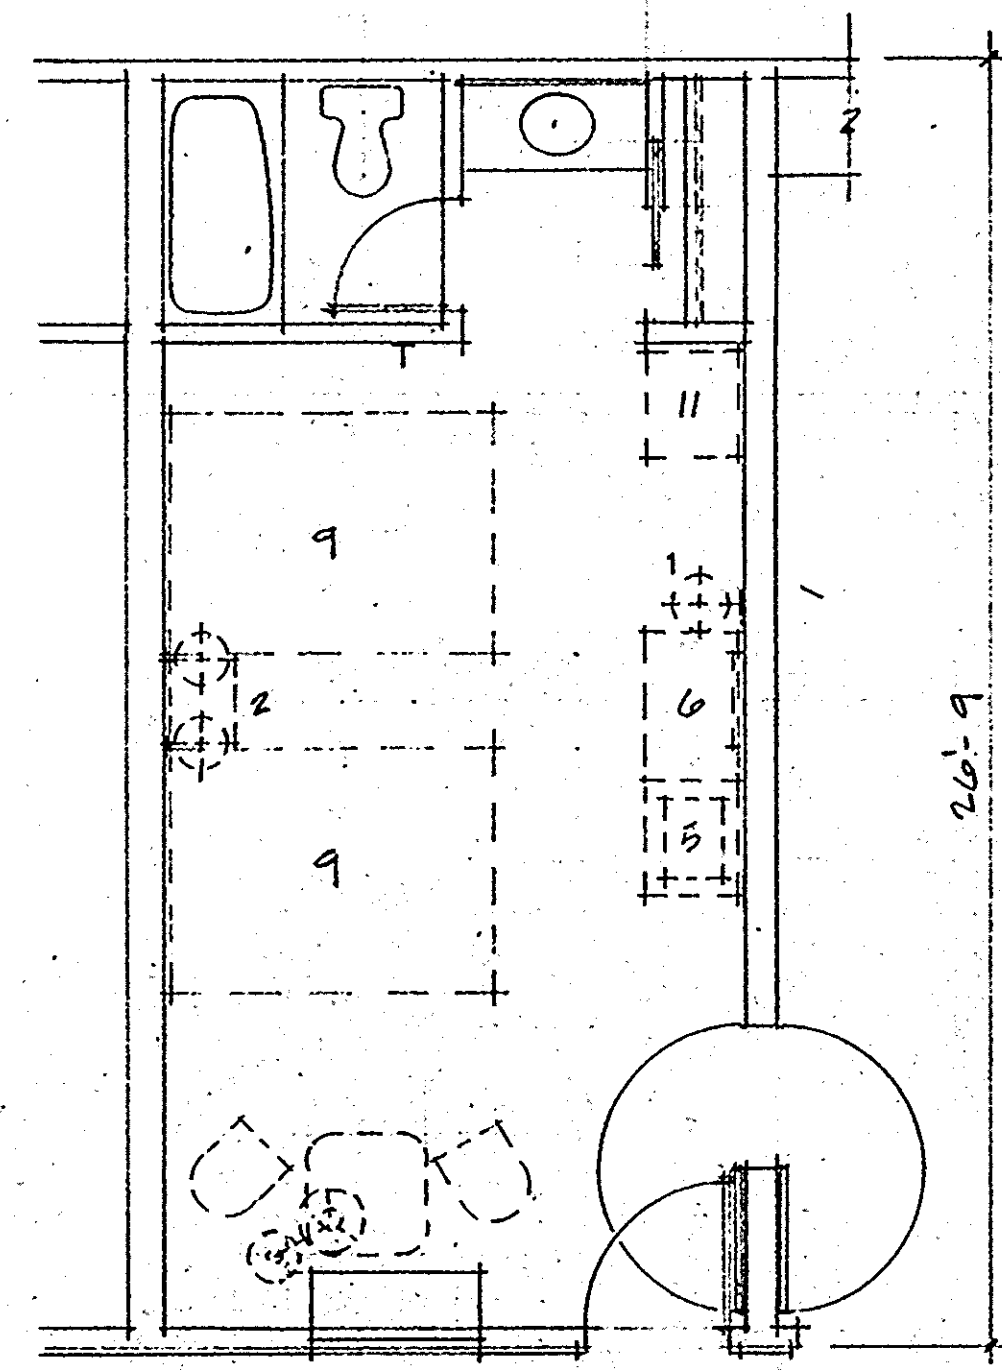


QUEEN - DBL. RM. (QD)

1/4" = 1'-0" W/ CLO. DOOR

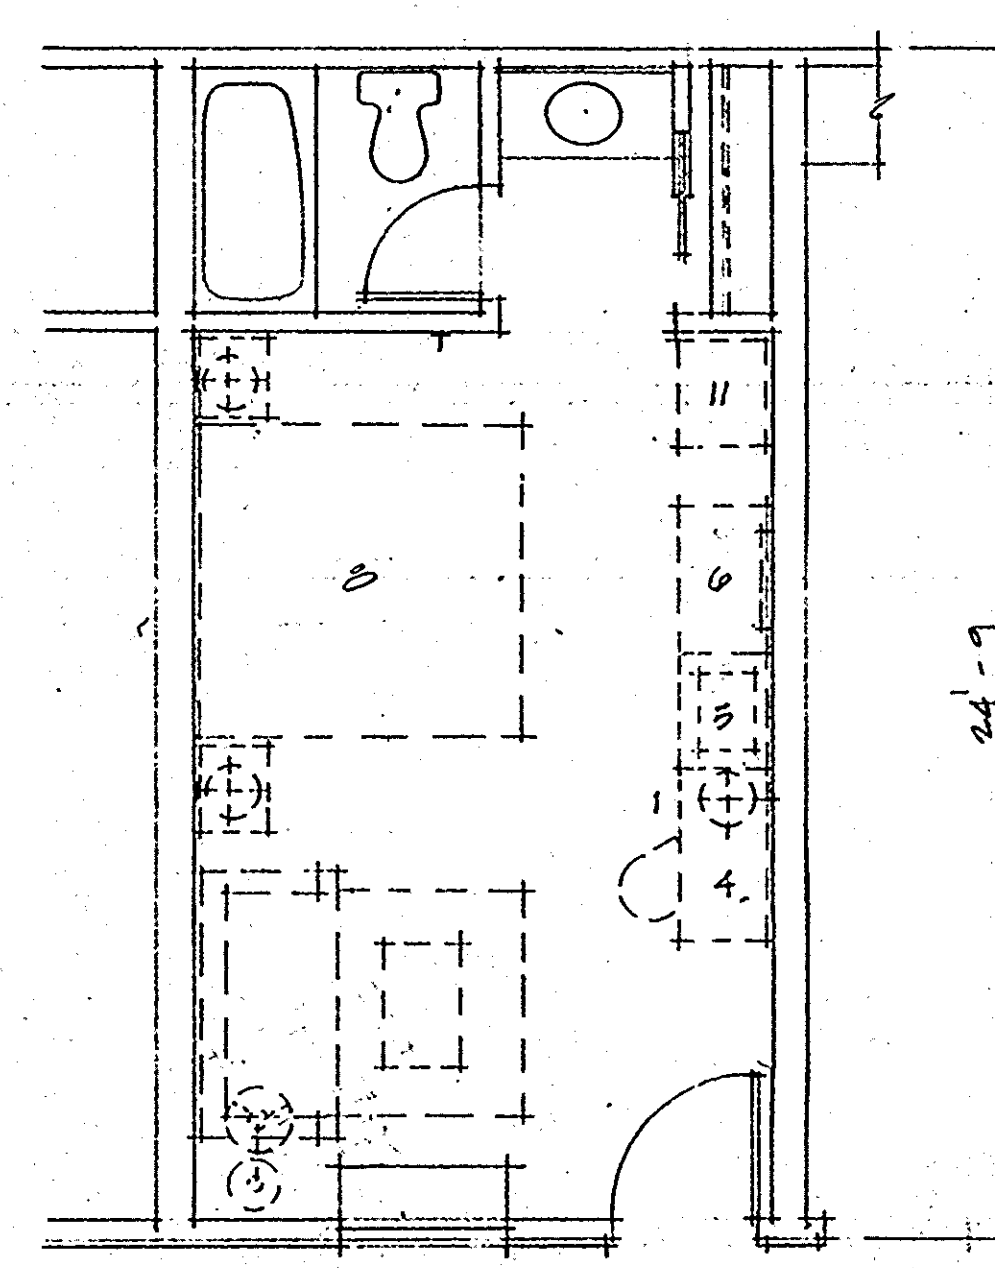

TYP. KING - SOFA RM. (KS)


1/4" = 1'-0"

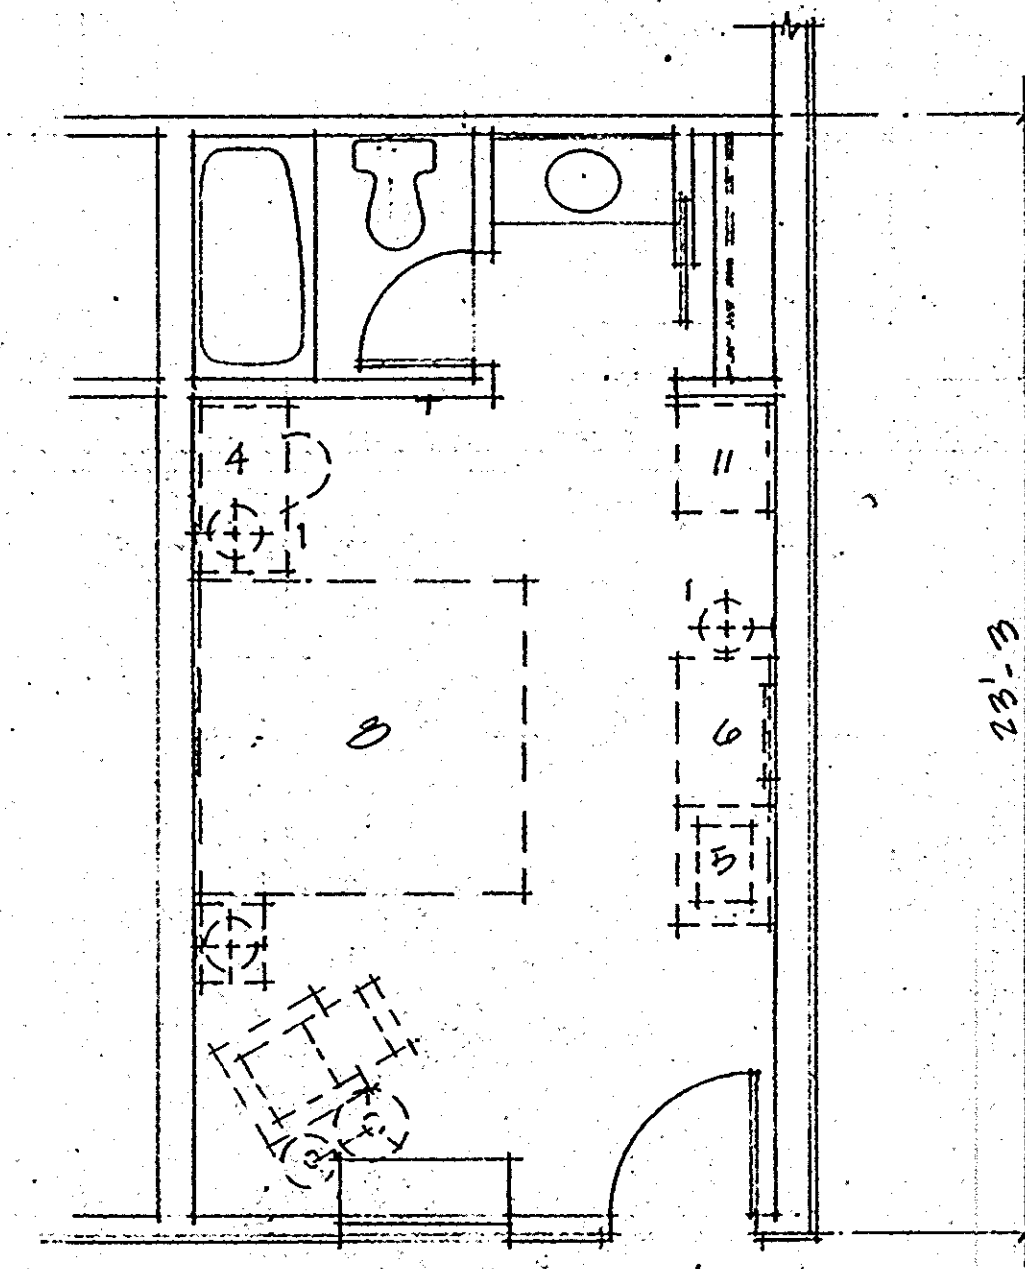

TYP. KING RM. (K)


1/4" = 1'-0"

MAX. ROOM AREA = 12' x 20' = 240 SF
MIN. GLASS AREA = (24' x 10') = 240 SF

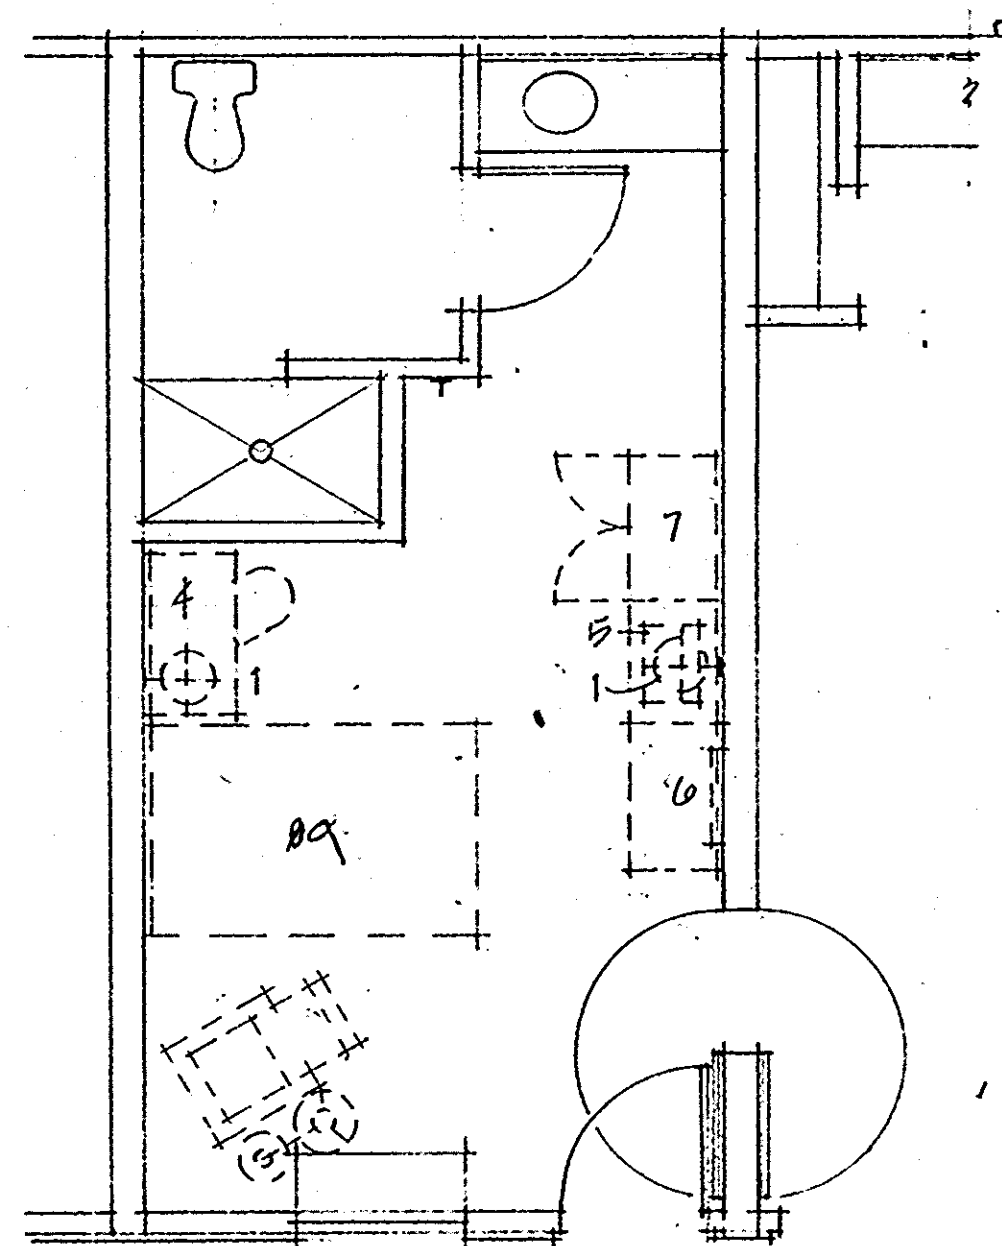

TYP. HANDICAP RM.
TYPE 1 (HC-1)

1/4" = 1'-0"

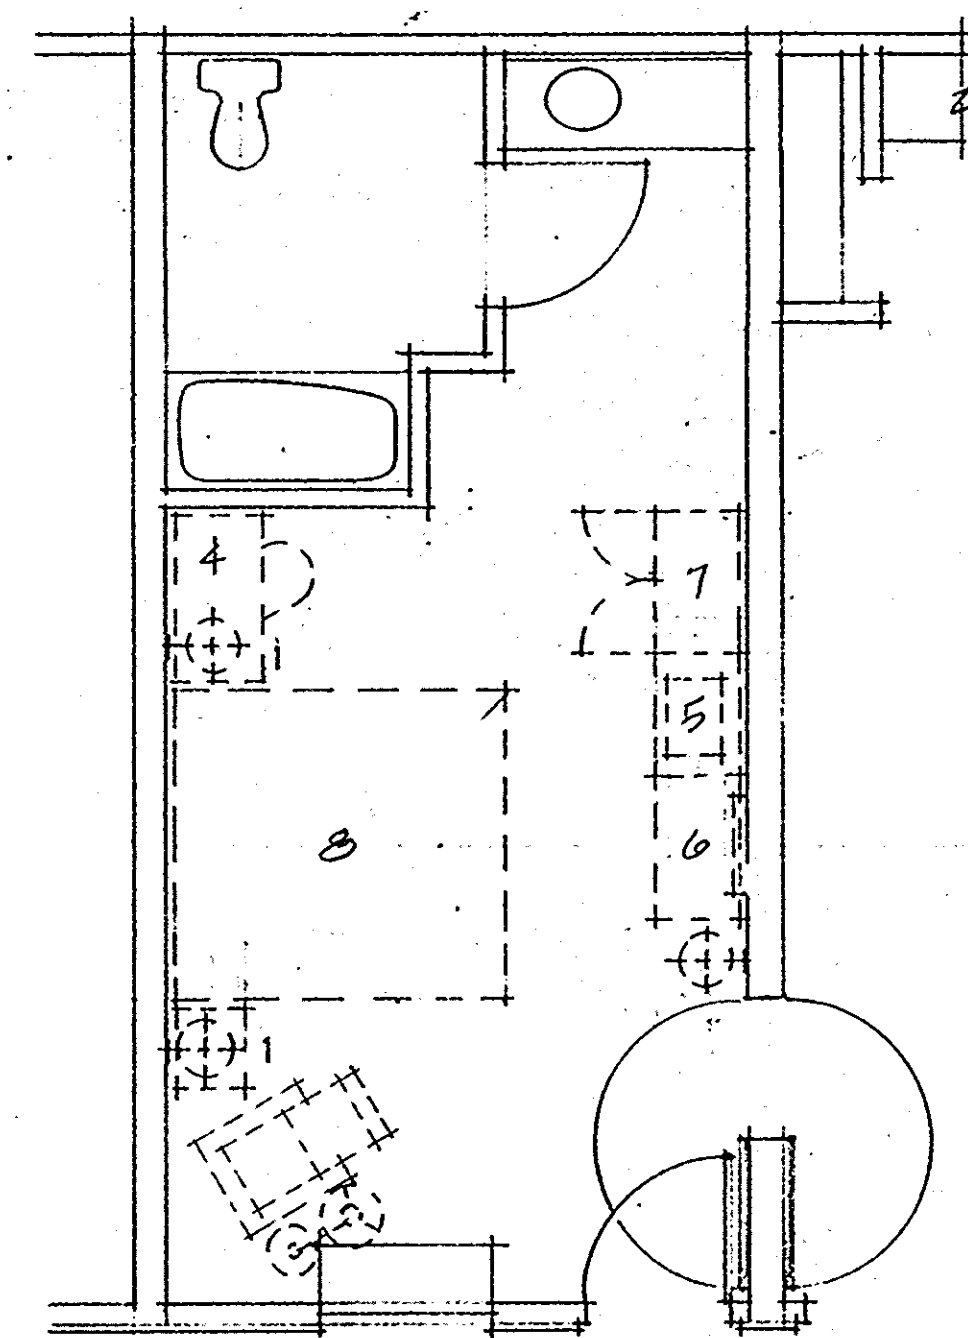

TYP. HANDICAP RM.
TYPE 2 (HC-2)






1/4" = 1'-0"

LEGEND

- 1. WALL MTD. SINGLE LAMP
- 2. WALL MTD. DOUBLE LAMP
- 3. DESK LAMP
- 4. DESK
- 5. CHEST W/ TV ON TOP
- 6. LUGGAGE BENCH & WALL MIRROR
- 7. WARDROBE
- 8. KING BED
- 9. QUEEN BED
- 10. DOUBLE BED
- 11. CAB. FOR MICROWAVE OVEN ABOVE REFRIGERATOR

REV. 3-27-93

HAMPTON INN MONROE, LA		DESIGN CONSORTIUM HOTEL CONSULTANTS MEMPHIS, TENNESSEE	
TYPICAL GUEST ROOMS		DATE 3-10-93	A-5
		SCALE	
		JOB NO.	

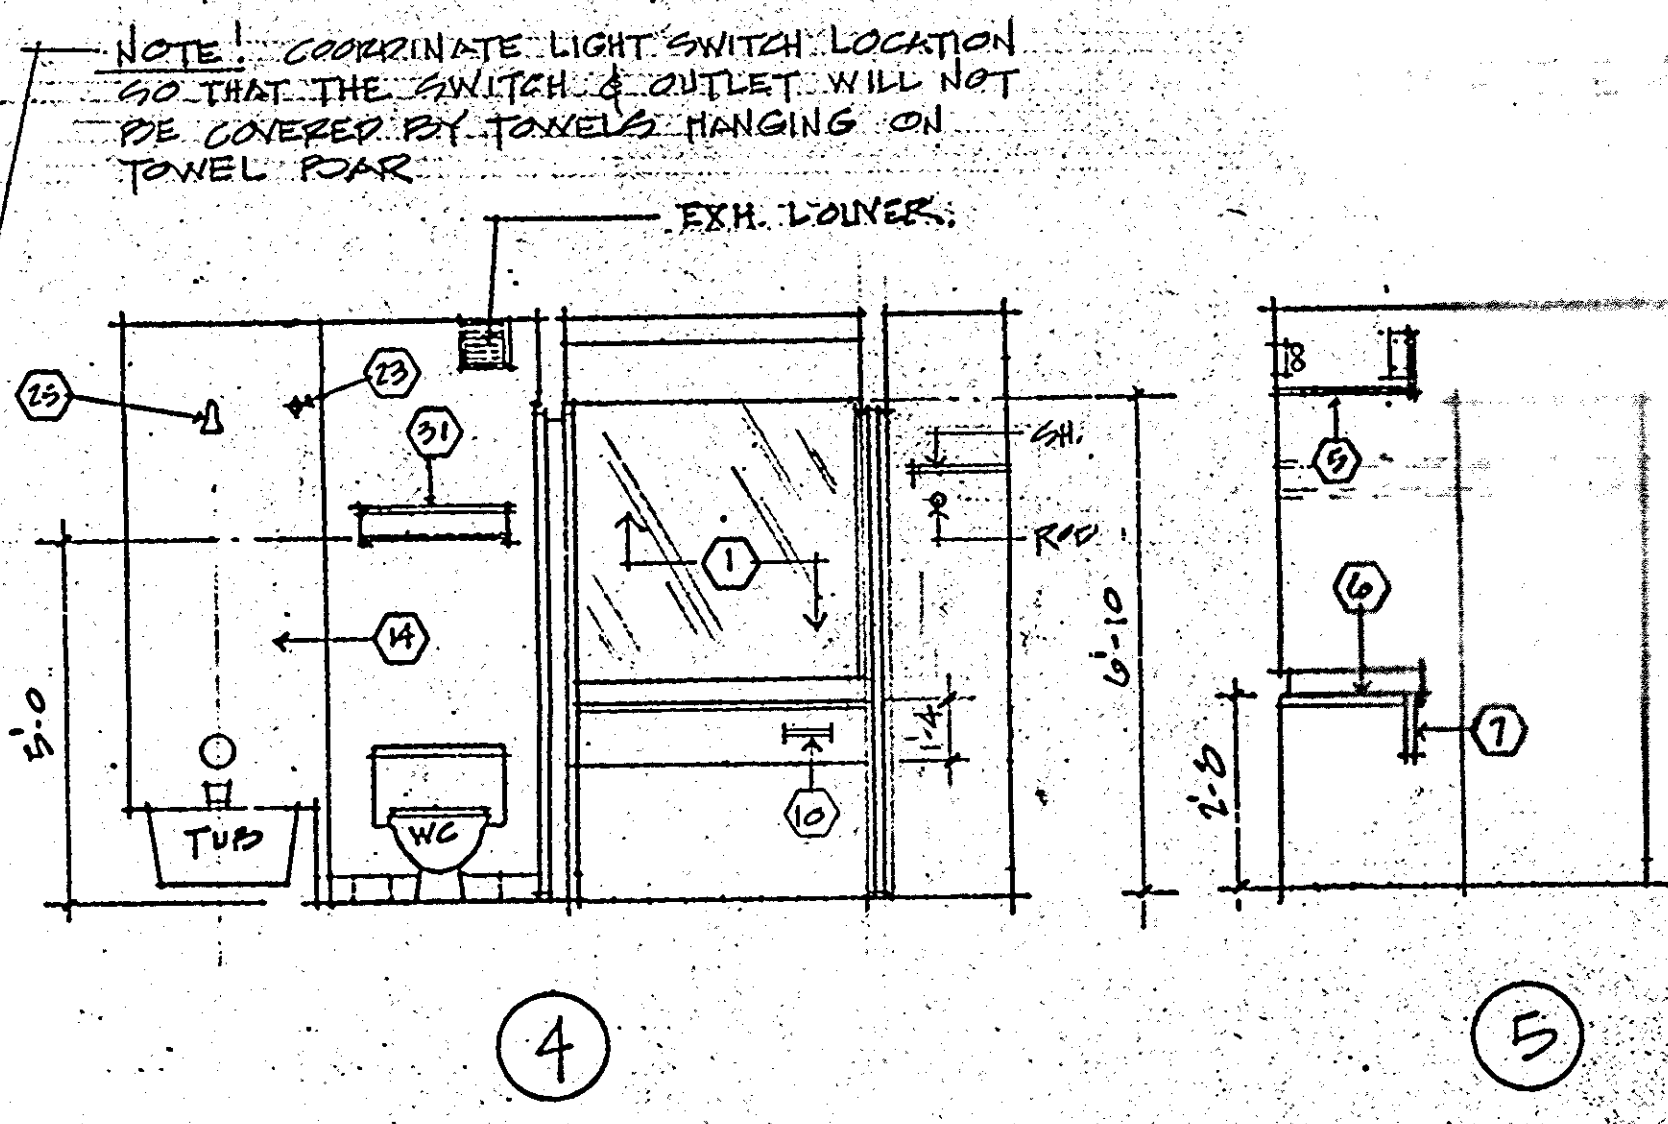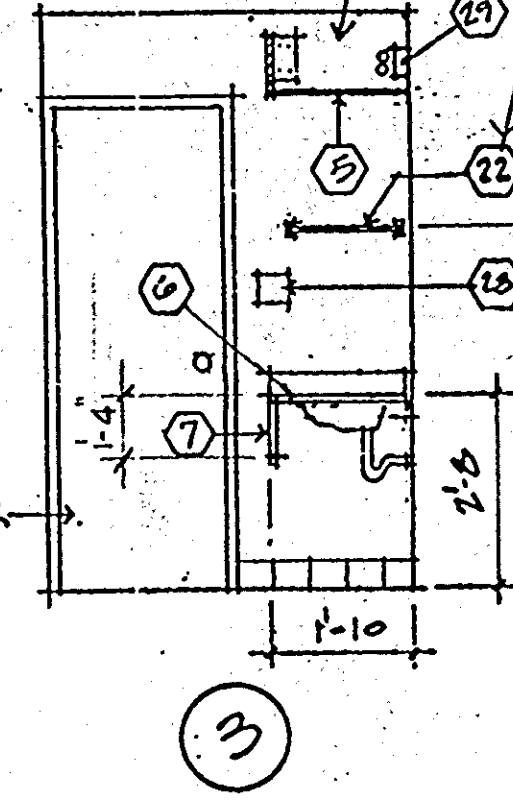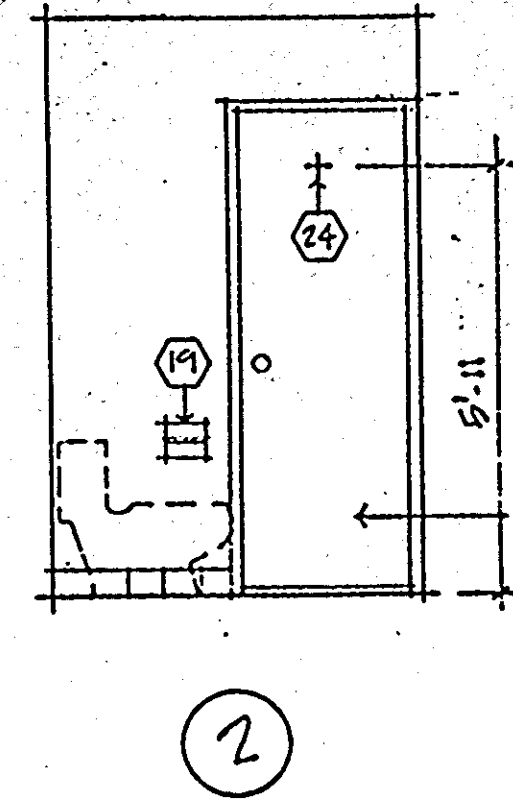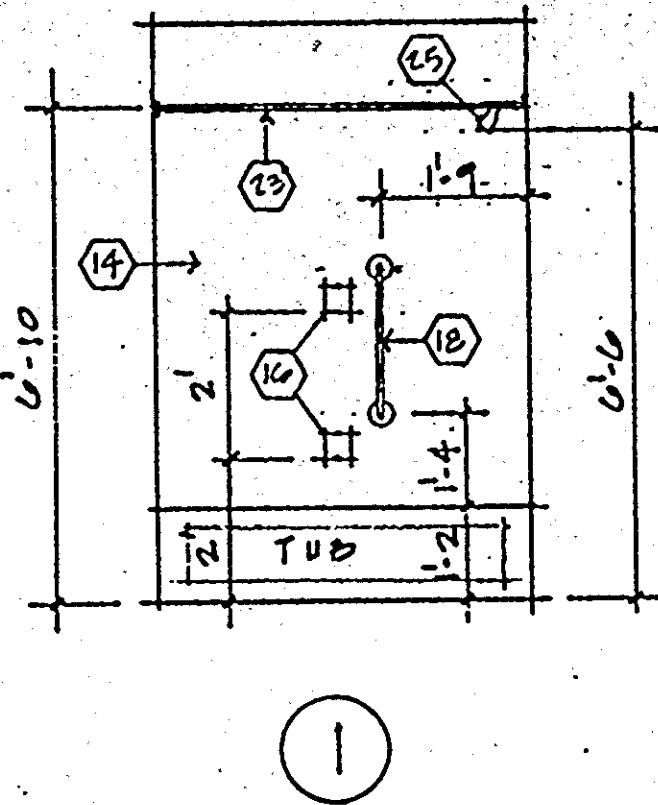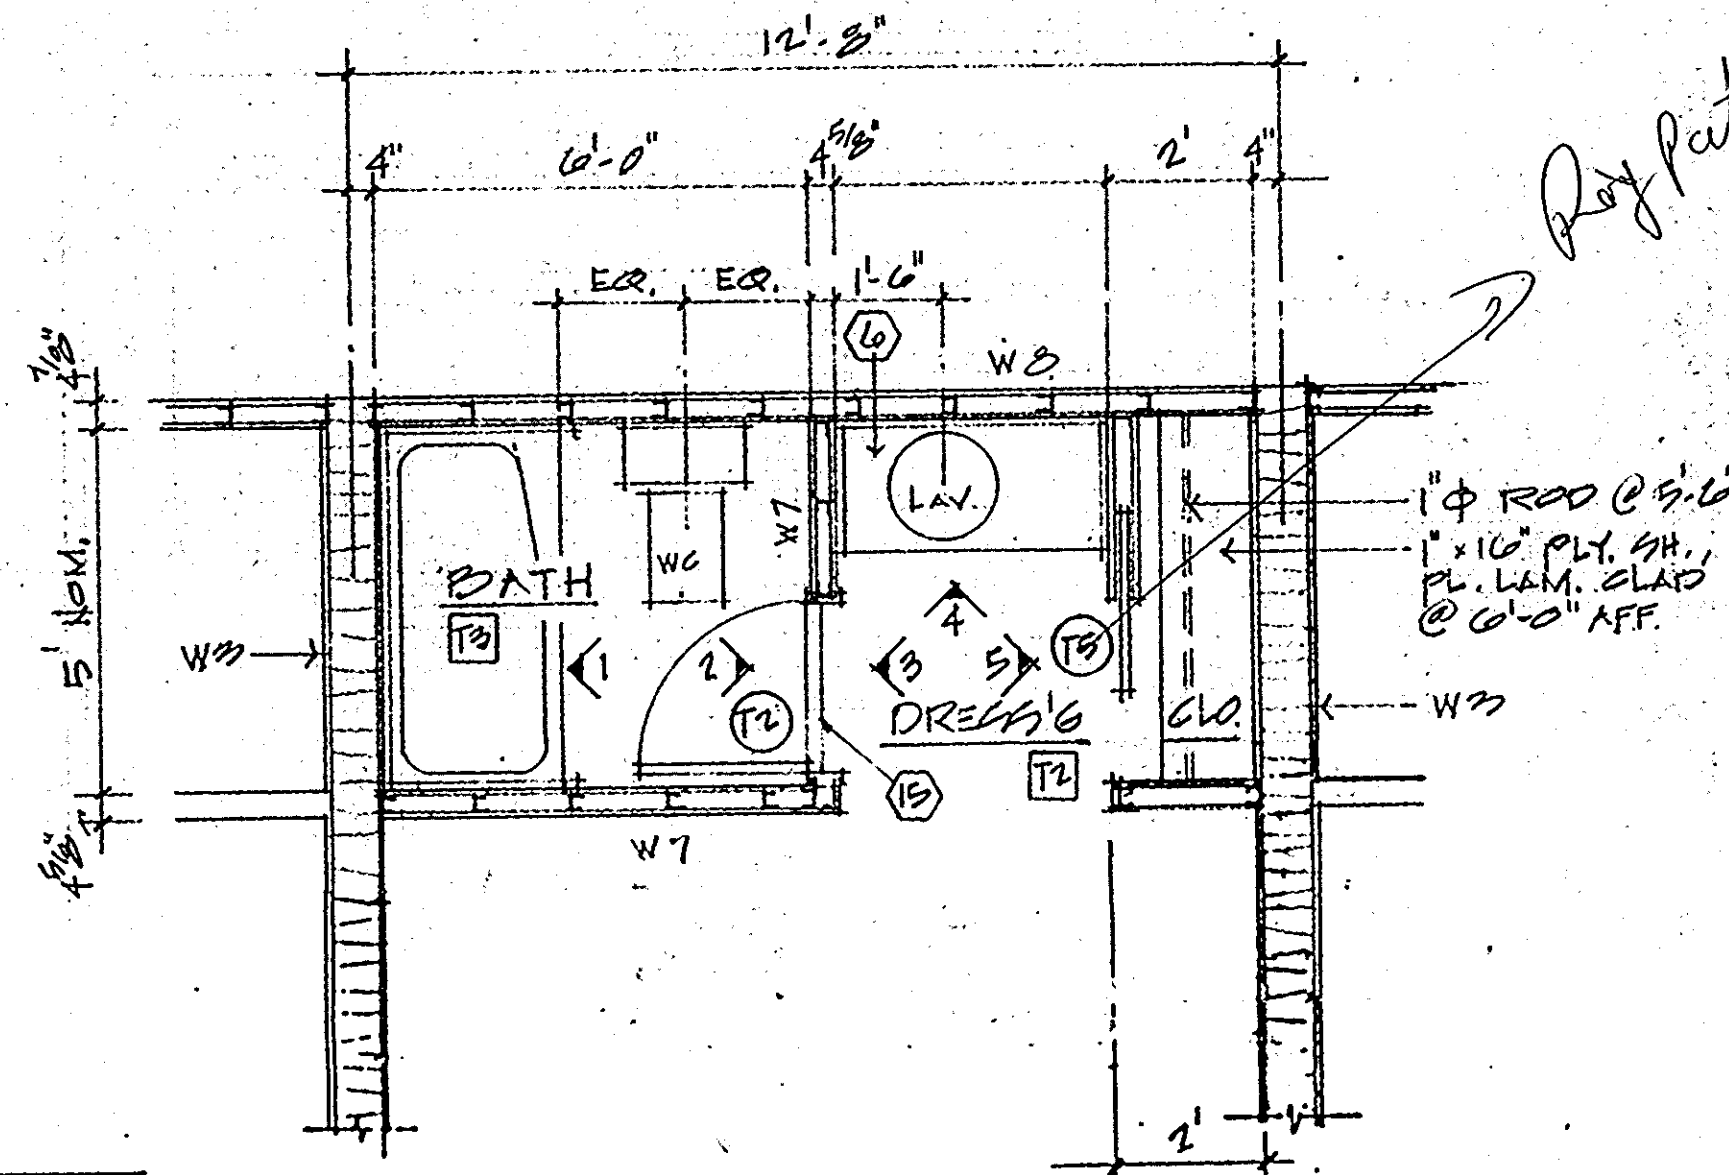


TYP. BATH & DRESSING ELEVATIONS

NOTES

1. G.C. TO PROVIDE PROPER FLOORING FOR WALL MOUNTED ITEMS.

2. BATHROOM & DRESSING SPECIALTIES TO BE CHROME PLATED BRASS UNLESS NOTED OTHERWISE.

A TYP. BATH & DRESSING PLAN 7'-5" x 1'-0"

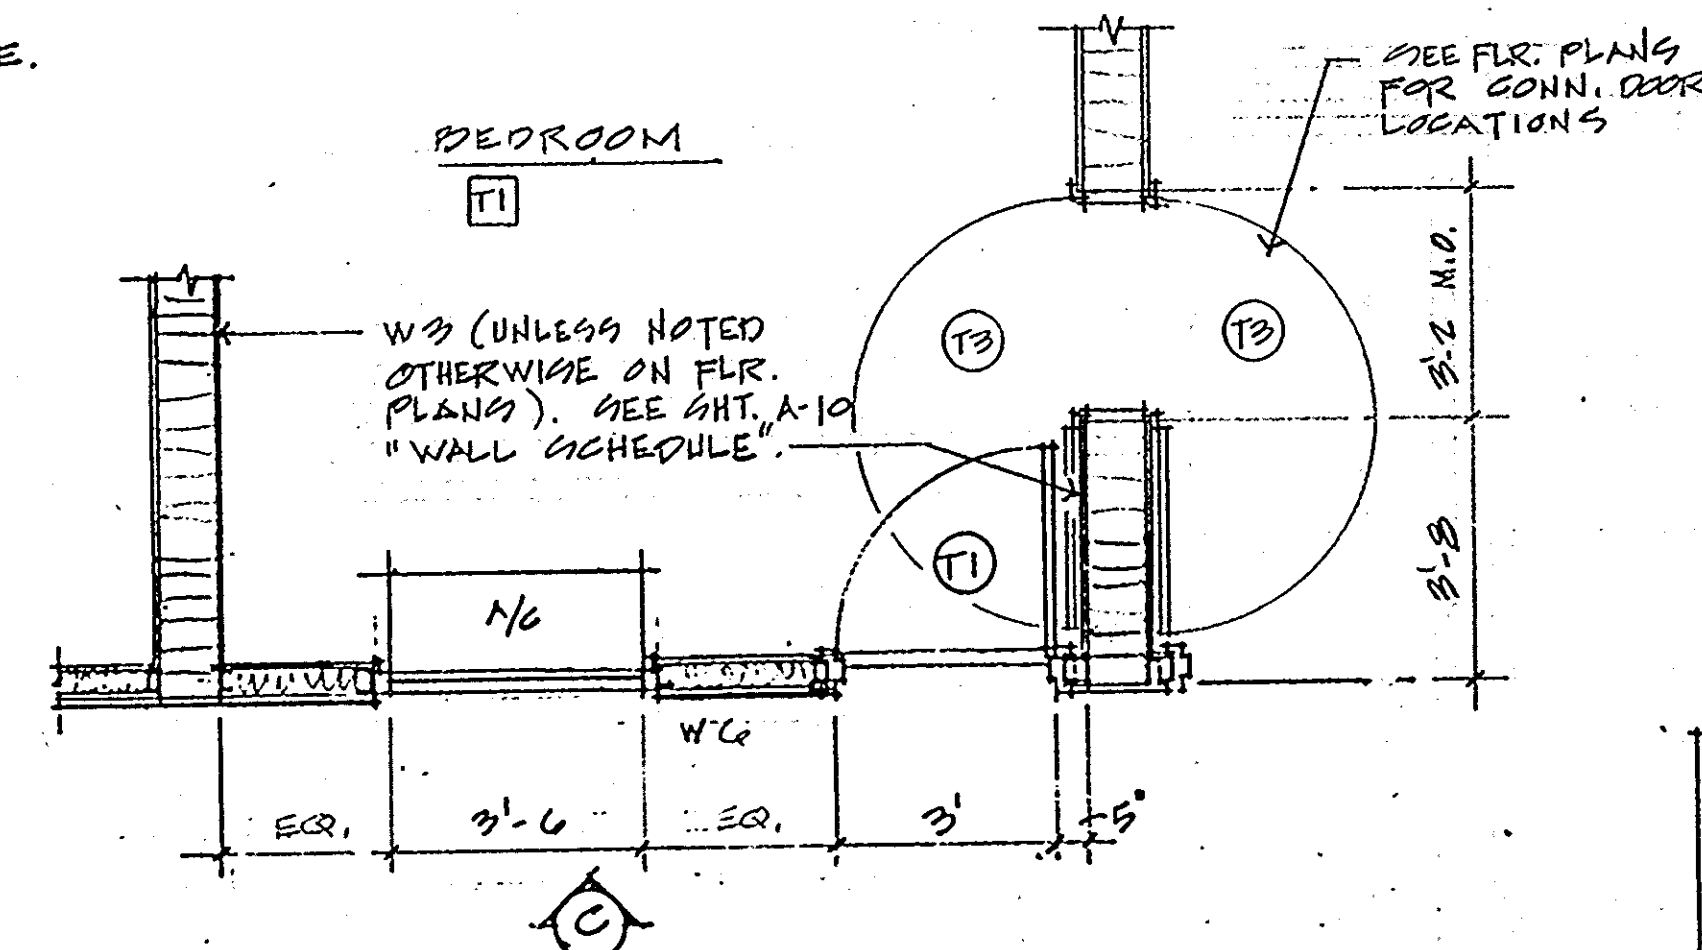



B TYP. ROOM FRONT PLAN 7'-5" x 1'-0"

STOREFRONT
5/8" INSULATING BRONZE TINTED GLASS
ALUM. TUBE FRAME, DARK BRONZE

EXT. INSUL. FINISH SYSTEM W/HIGH IMPACT MESH





N/C DELUX GRILLE, FINISH TO MATCH STOREFRONT FRAME

C TYP. ROOM FRONT ELEVATION 7'-5" x 1'-0"

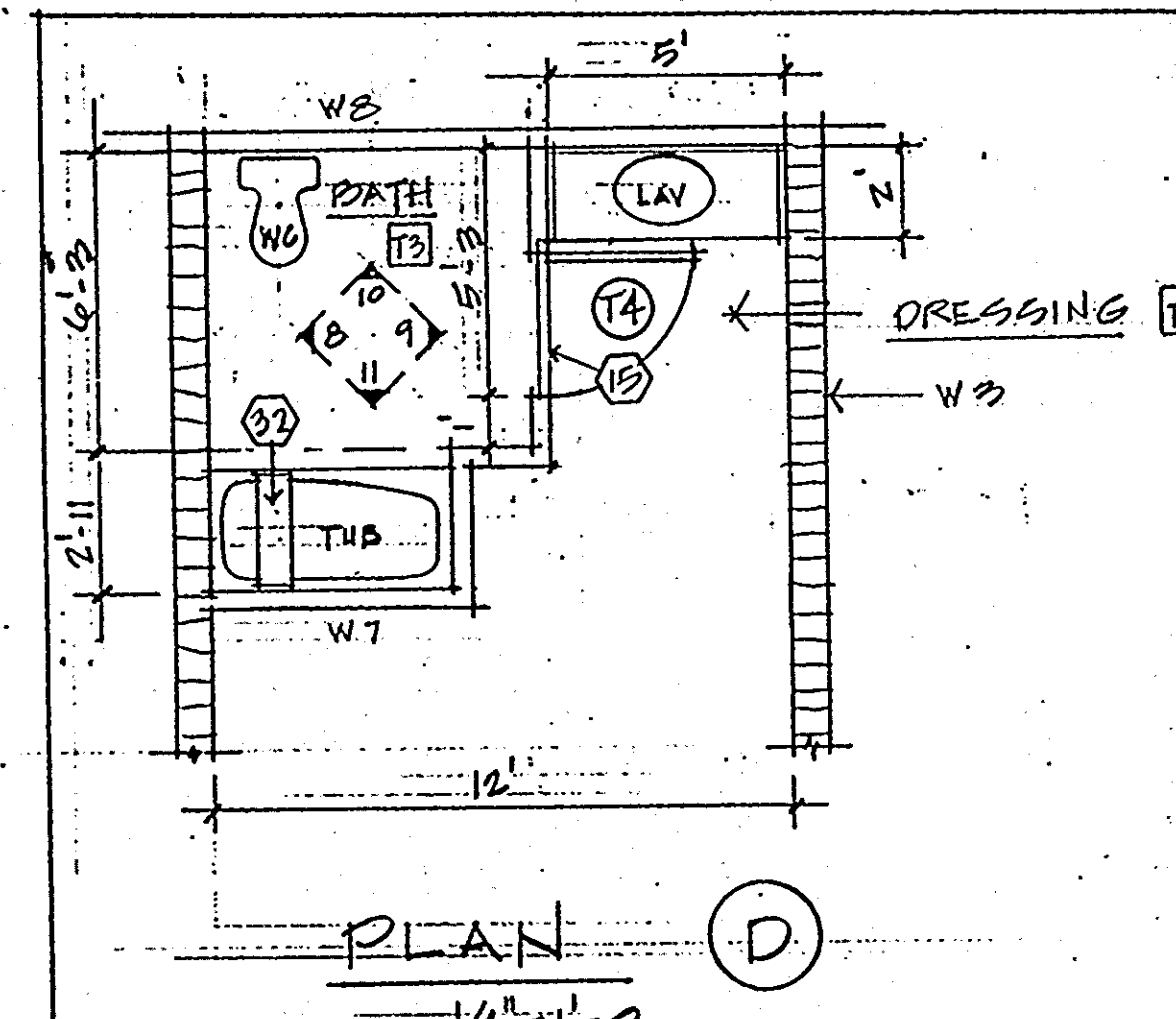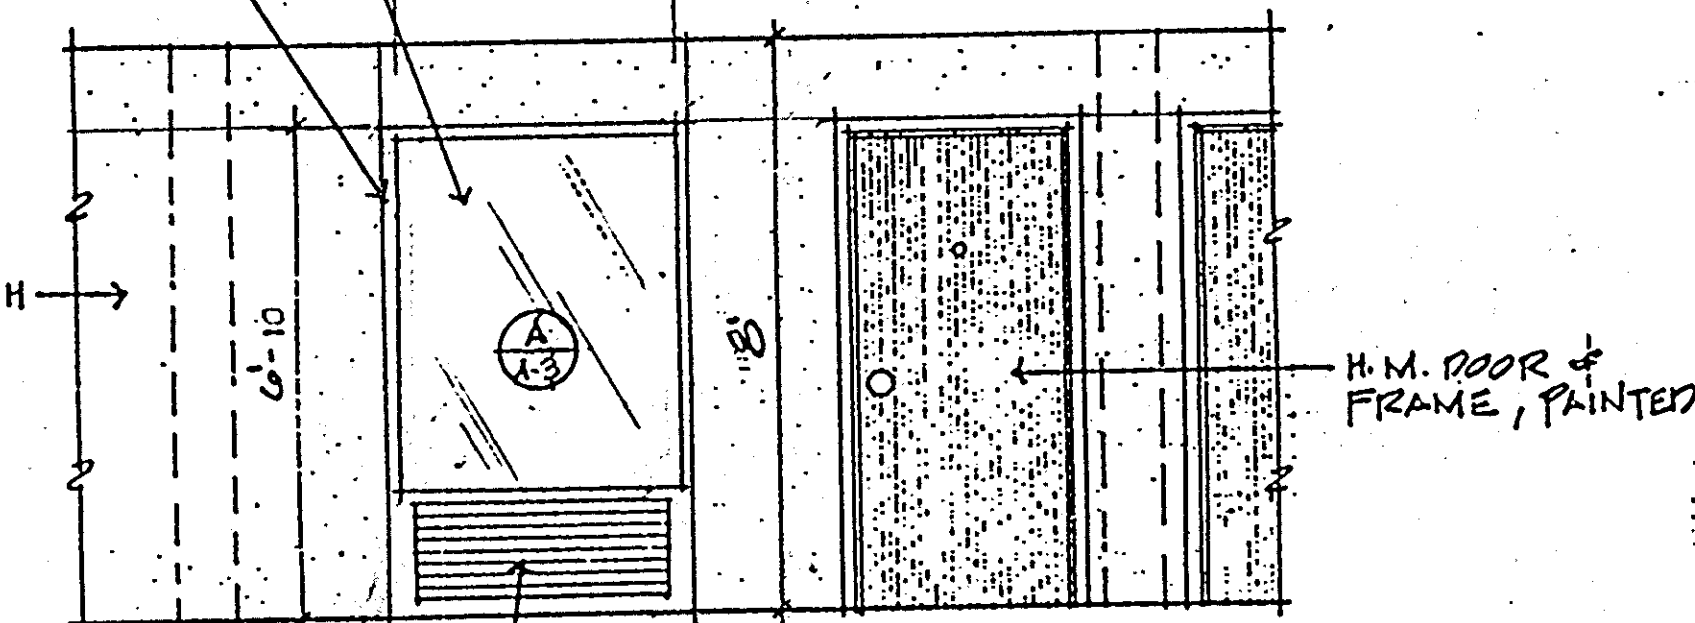

HANDICAP BATH

NOTE: GRAB BARS SHALL HAVE 1/2" CLEARANCE BETWEEN BAR & WALL, & CONFORM TO STRIC REQUIREMENTS OF ADA & GOVERNING CODE.

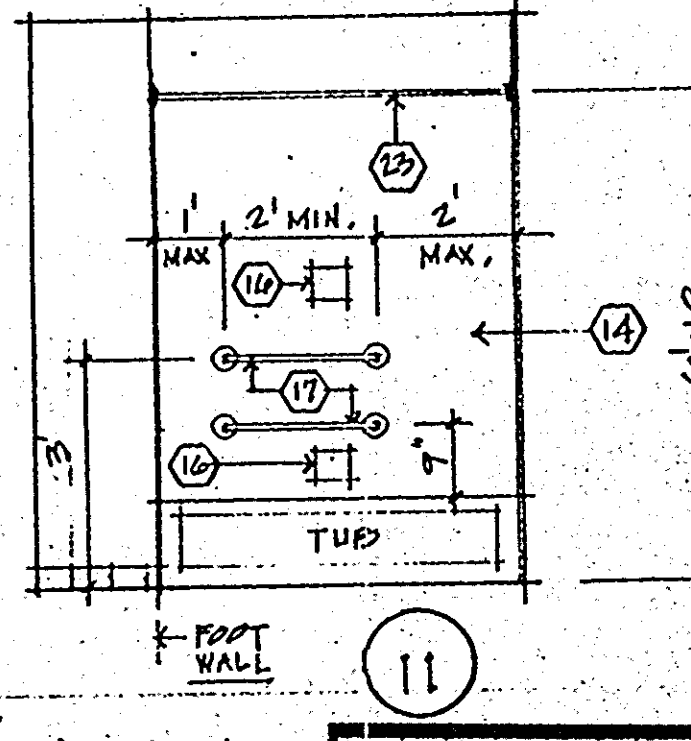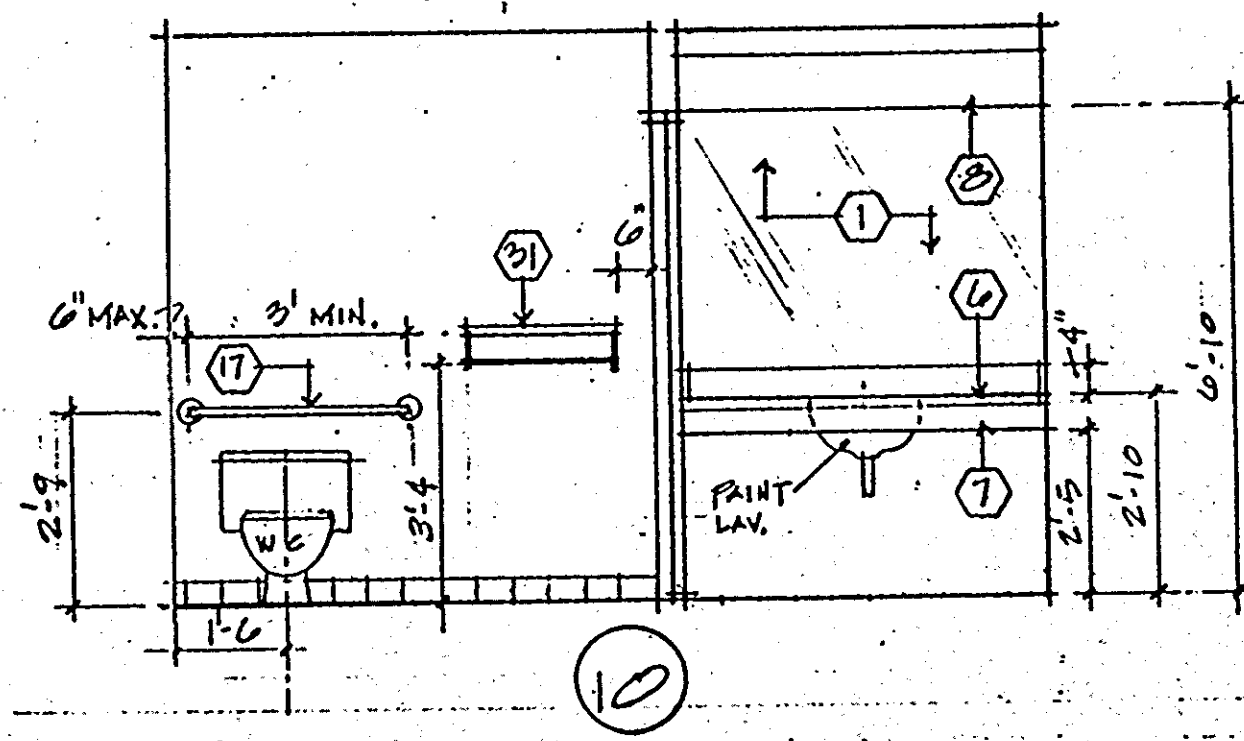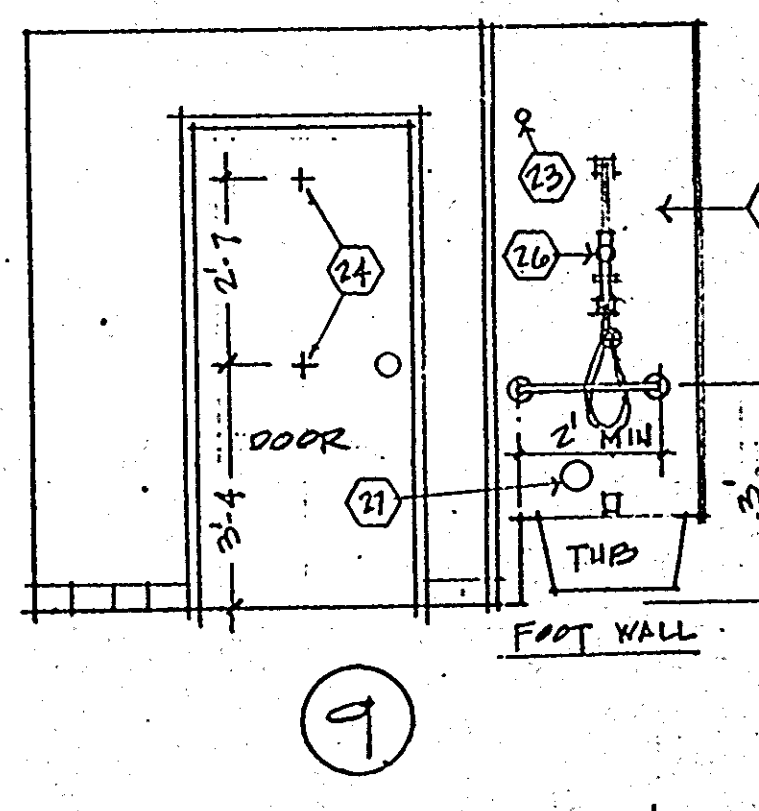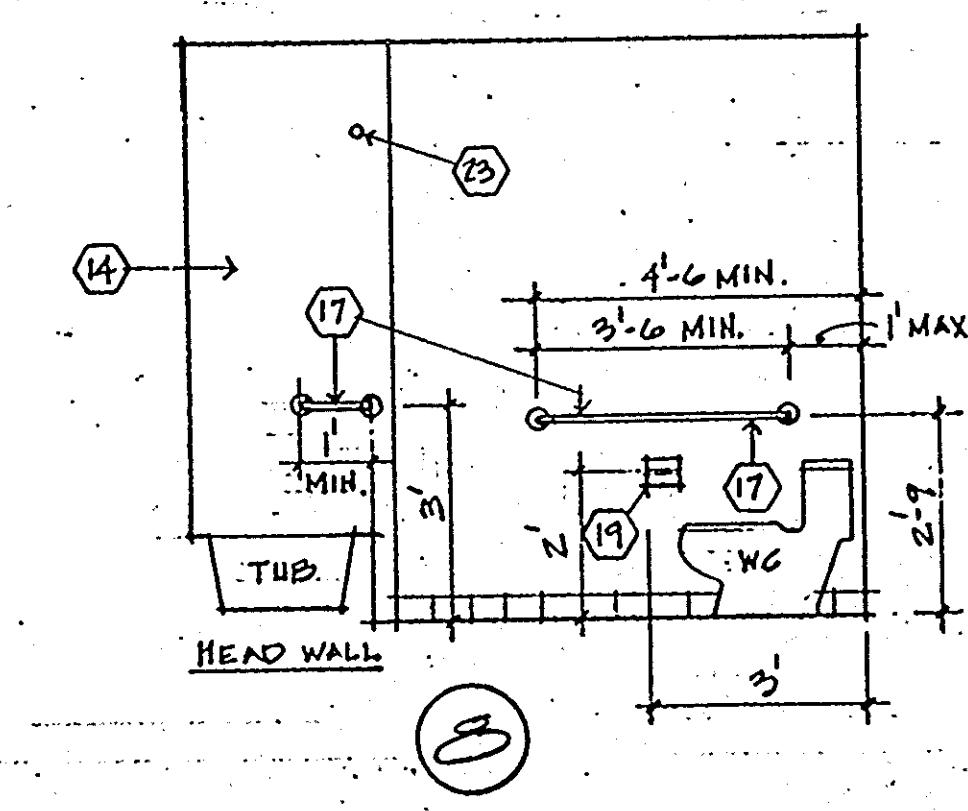

ACRYLIC PLASTIC "EGG CRATE" 1/2" x 1/2" x 1/2" INTEGRAL WHITE


7 SPEC. 1/2" x 1'-0"

KEY NOTES


1. FINISH LIGHT ENCL. APPL. PLAST. LENS W/ WHITE PENT. GLOSS PAINT.
2. PLASTIC LAY-IN LENS.
3. SUSPENSION GRID TO BE FACT. PTD. WHITE. SECURE EDGE MOLDINGS TO SUBSTRATE W/ SCREW @ 16" MAX. W/ SET W/ CONCEALED PEE OF 1/8" BELLAIR. WALL CORNER JOINTS.
4. CULTURED MARBLE VANITY TOP W/ INTEGRAL EDGES. DRESSING PLASH. & TOP BEL. SIDE PLASH. (3 WALLS).
5. CULTURED MARBLE VANITY FRONT.
6. PLASTIC LAM. ON 1" FLYND.
7. FACIAL TISSUE SLOT IN VANITY FRONT. DISPENSER CANISTER BEHIND.
8. CULTURED MARBLE TUB ENCL.
9. MARBLE THRESHOLD.
10. GOLD OISH / NO GRAD.
11. 1/2" AT GROUND BAR.
12. 1/2" AT GROUND BAR.
13. RECESSED DEL. RAIL TUB THROU HOLDER.
14. RECESSED FACIAL TISSUE TOP.
15. NET TUBE WARDROBE RACK.
16. TOWEL BAR / 1/2".
17. 1/2" SHOWER CURTAIN ROD.
18. DEL. REBE HOOK.
19. SHOWER HEAD - SEE FUND.
20. HAND HELD SHOWER HEAD.
21. SLIDE BAR - SEE TUBING.
22. SINGLE LEVER WATER CONTROL.
23. LIGHT SW. & CONV. OUTLET CAP.
24. FLUORESCENT LIGHT FIXT.
- 25.
26. COMP. TOWEL RACK / BAR - SUPPORT PLUCKETS 24".
27. REMOVABLE TUB SEAT (HIZ).

KEYNOTE:


- 1 GRADE
- 2 VEHICULAR PAVEMENT
- 3 SIDEWALK
- 4 CONC. WALKWAY, ROOM FINISH
- 5 CONC. FLOOR
- 6 CONC. ROOF
- 7 STEEL BEAM
- 8 HANDRAIL - 1 1/2" OD. MET. TUBE, PAINTED, ATT. TO GUARDRAIL W/ MET. BRACKETS W/ 1/2" CLEARANCE BETWEEN GUARDRAIL & HANDRAIL
- 9 GUARDRAIL - 1 1/4" x 6" TOP RAIL, 1 1/2" OD. MET. TUBE, DOT. RAIL & POSTS W/ 1/2" OD. MET. PICKETS @ 4 1/2" O.C. MAX., PAINTED
- 10 PREFAB. STL. STAIR SYSTEM W/ CONC. FILLED (NON-SLIP) TREADS & LANDING & STL. MET. RISERS, GALV. & PAINT FERROUS MET. OVERALL WIDTH
- 11 STRAIGHT STAIR - 8" CLEAR
- 12 SCISSOR STAIR - 8" CLEAR
- 13 2x WOOD FRAMING 24" O.C.
- 14 FACTORY WOOD TRUSSES 24" O.C.
- 15 EXT. FINISH SYSTEM (DRYVIT OR EQ.) ON CEM. PLAS. SKIM COAT ON CONC. BLK.
- 16 E.I.F.S. (1" MIN. EXT. INSUL. FINISH SYSTEM, DRYVIT OR EQ.) ON GYP. SHEATHING ON SCOT. WOOD OR SPACED WOOD FRAMING AS FOLLOWS:
2x5 @ 16" O.C. = 1/2" GYP. SHEATHING
2x5 @ 24" O.C. = 5/8" GYP. SHEATHING
- 17 EXT. FINISH SYSTEM (DRYVIT OR EQ.)
- 18 ROOF INSULATION BOARD - R-19 MIN., COMPATIBLE W/ ROOF SYSTEM
- 19 RUSTICATION (V-JOINT)
- 20 PREFORMED, PREFINISHED STANDING SEAM MET. ROOF PANELS & TRIM ON 15" FELT ON 5/8" EXT. PLY. SHEATH.
- 21 PARAPET WALL COVERING ON 5/8" EXT. PLY. SHEATH.
- 22 SINGLE PLY E.P.D.M. BALLASTED ROOFING, FLASHING & ACCESSORIES ON ROOF INSULATION BOARD (R-19 MIN.) COMPATIBLE W/ ROOFING
- 23 24 GA. GALV. MET. COPING, PREFINISHED, W/ SLIPS @ 32" O.C.
- 24 1 1/2" x 24 GA. GALV. MET. GUTTER, SLOPE 2" TO DROPT. CONNECT. DROPT. TO 3" & RAIN LEADER CONCEALED IN COL. & SPILL OUT THRU CURB ONTO VEHIC. PAV.
- 25 PAINT

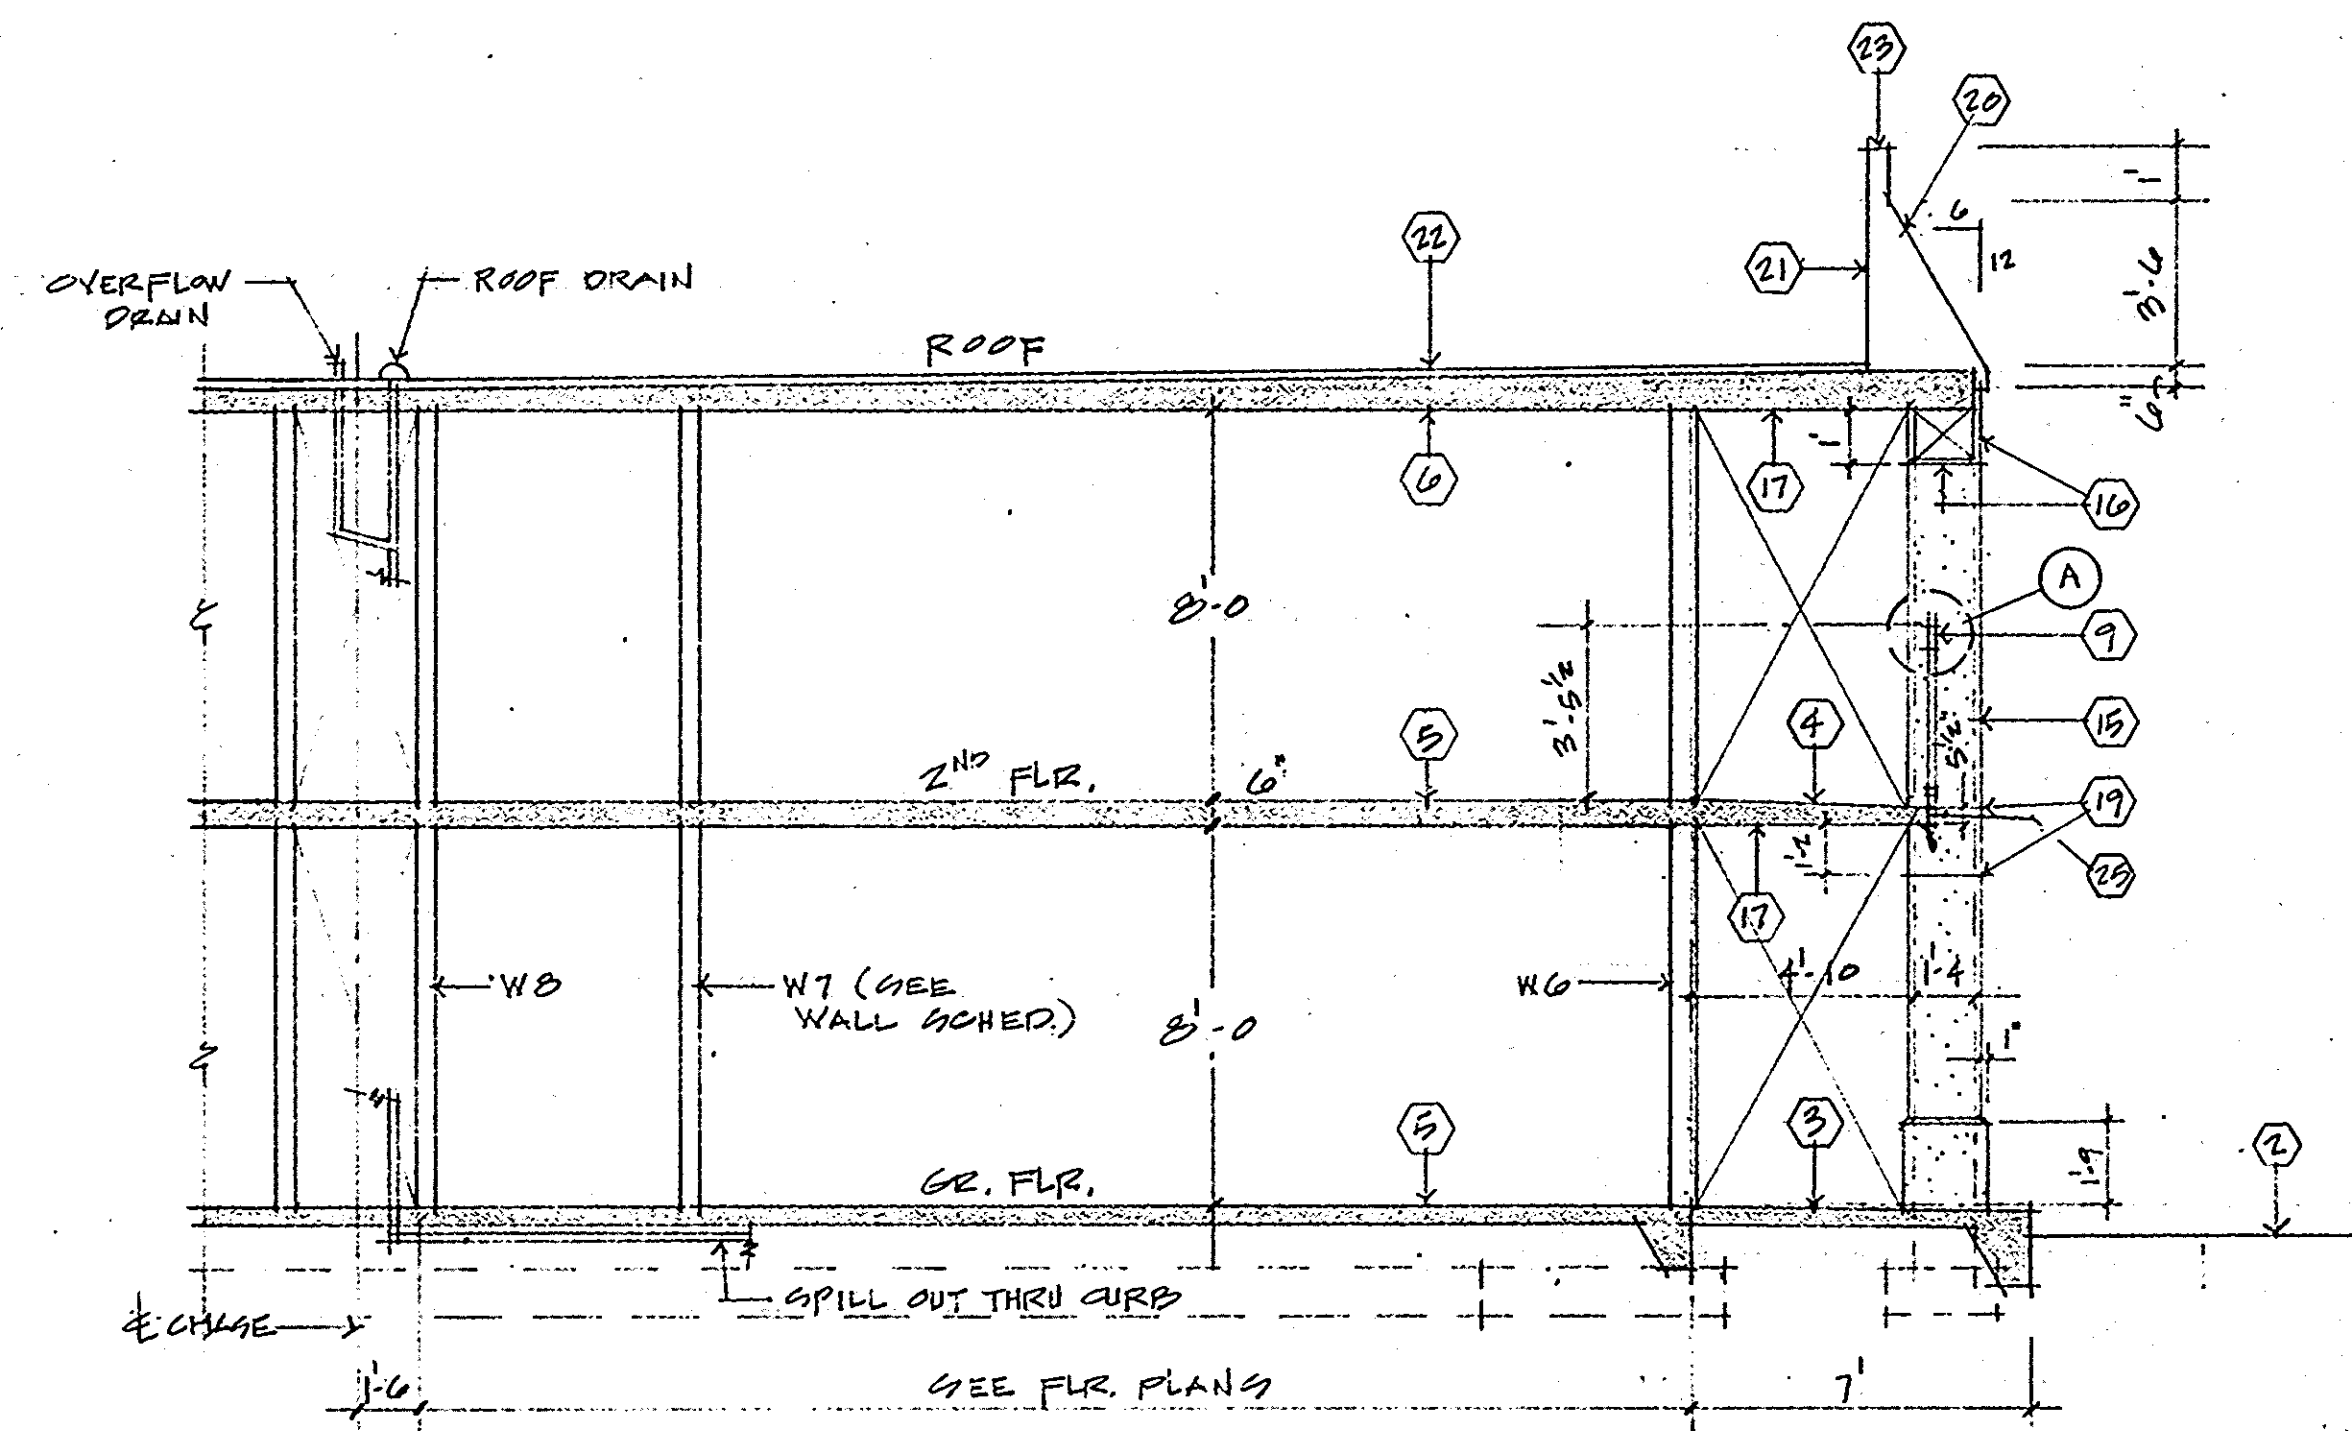

SEC. 1
1/4" = 1'-0"

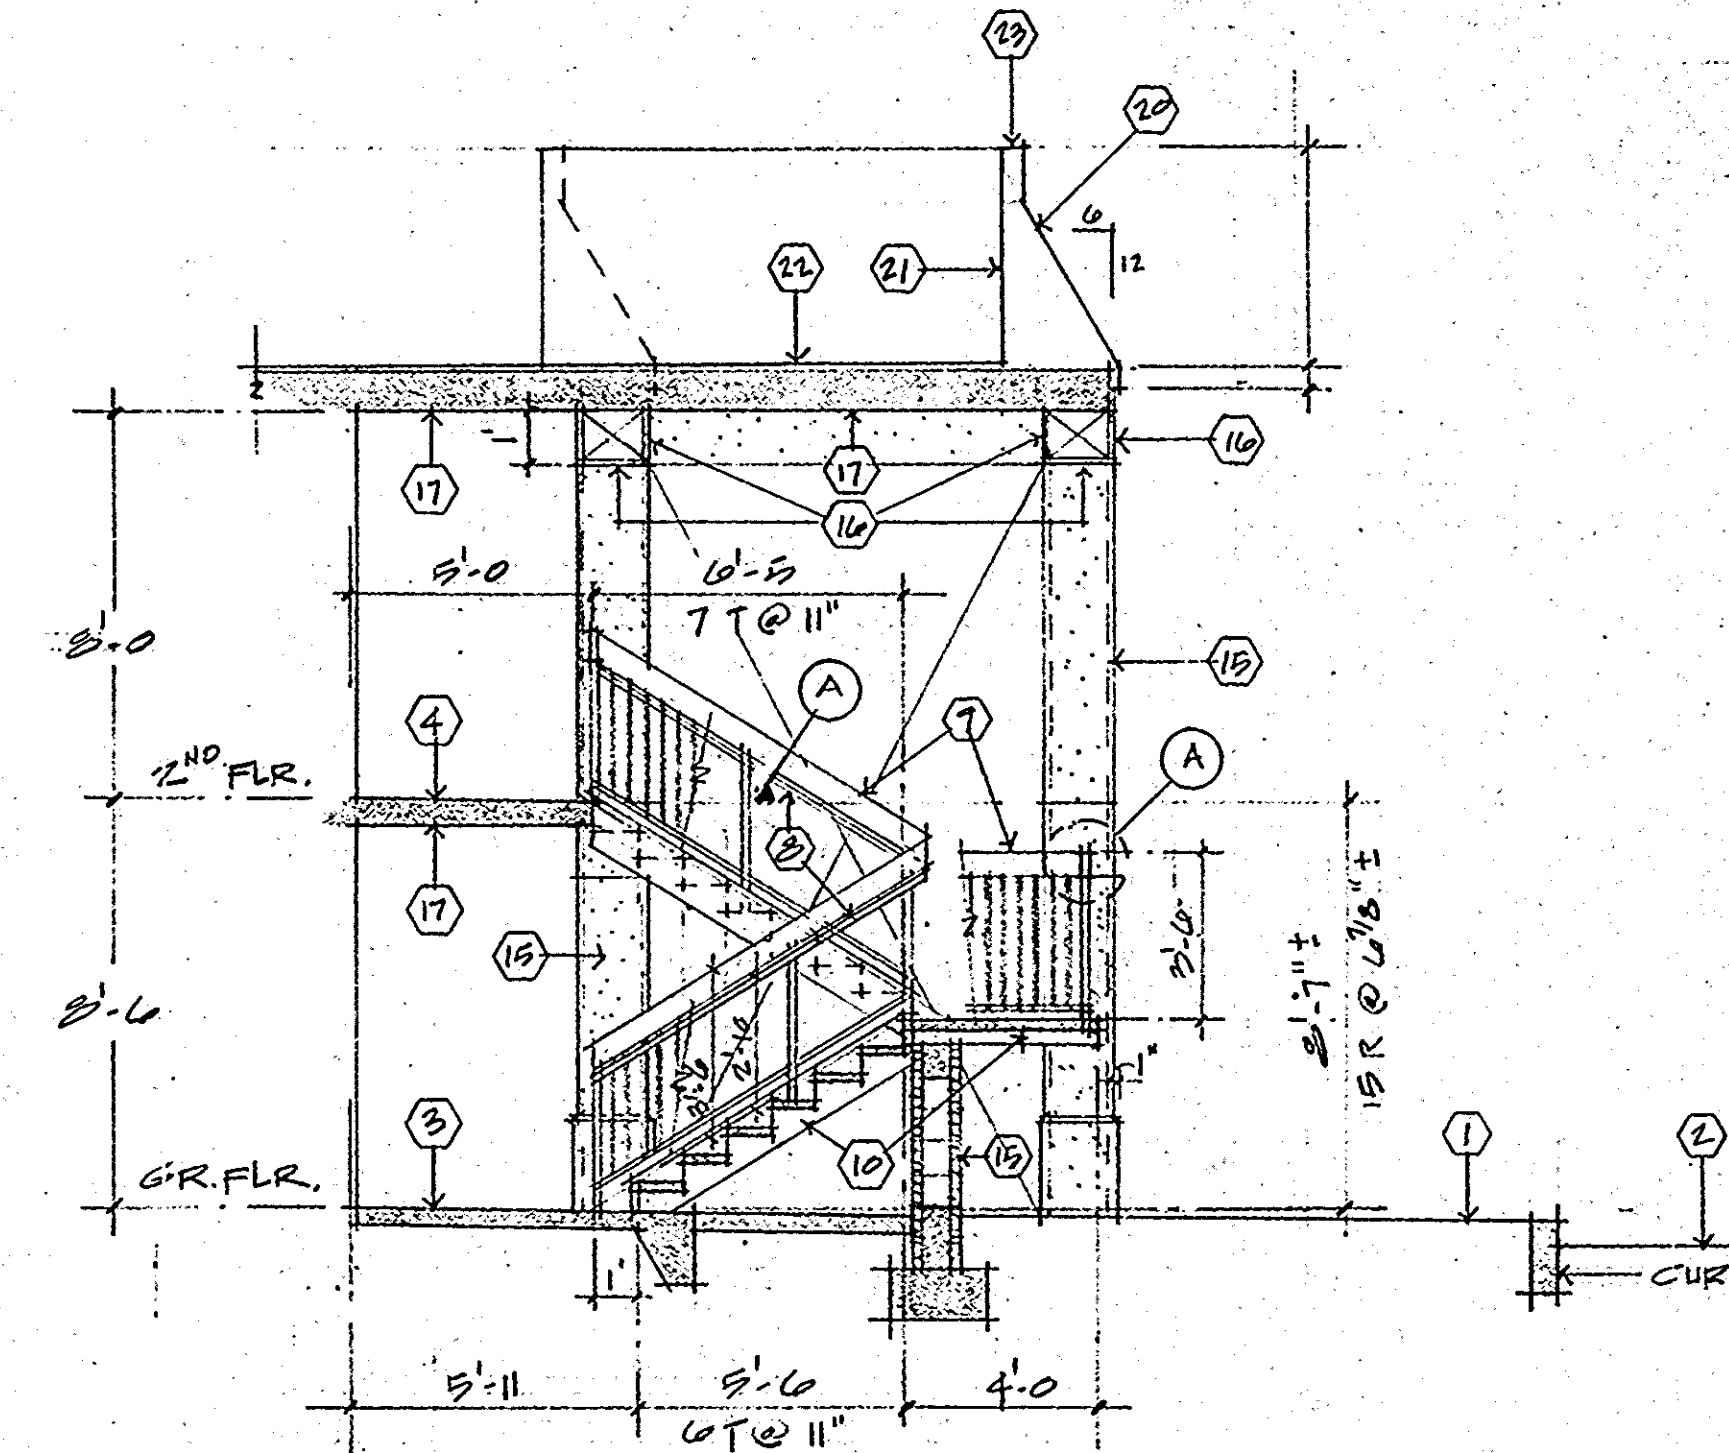


SEC. 2
1/4" = 1'-0"

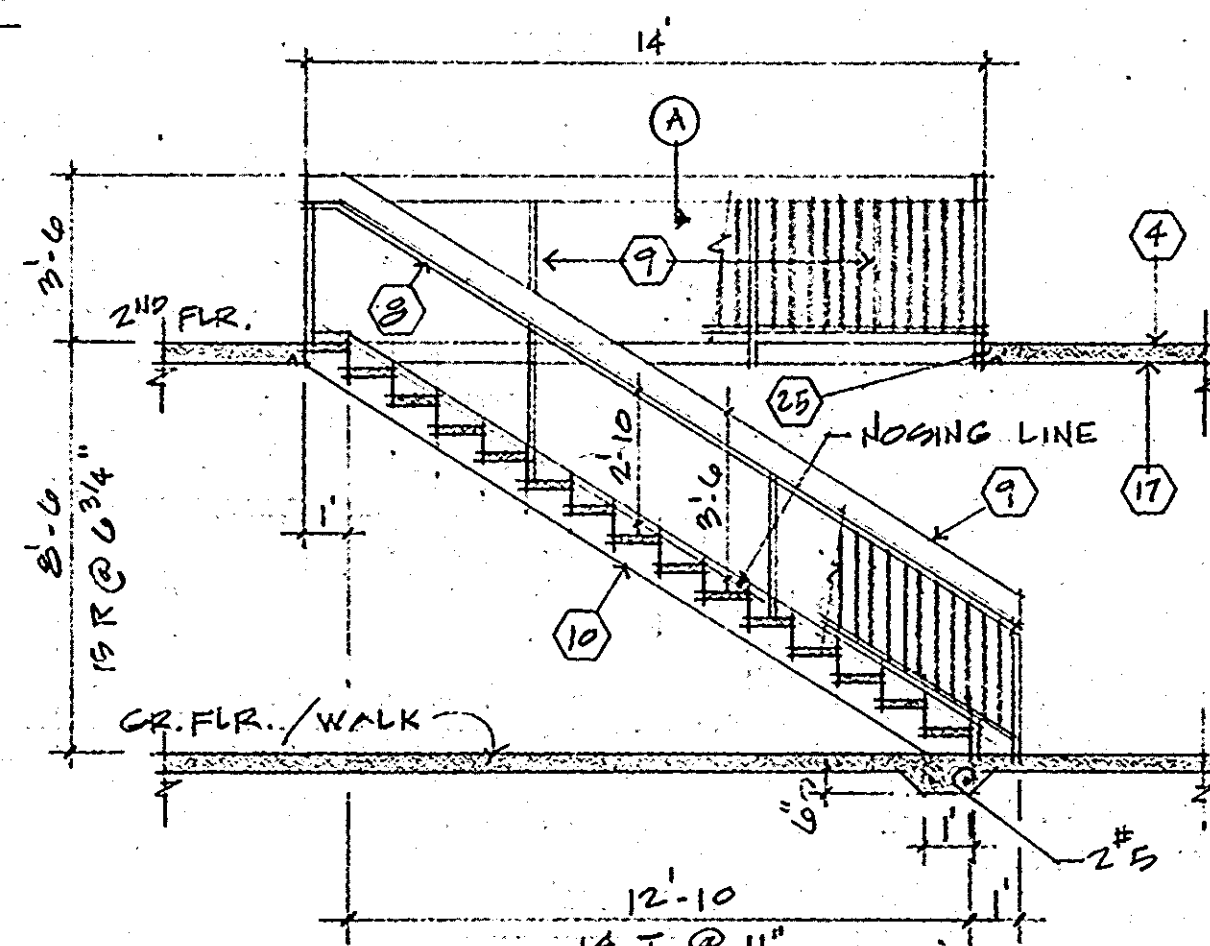


SEC. 4
1/4" = 1'-0"


AT WALL SIDE OF STAIR PROVIDE 1 1/2" OD. MET. TUBE HANDRAIL ATT. TO WALL W/ MET. BRKTS. W/ 1/2" CLEARANCE BETWEEN FIN. WALL & RAIL @ 2'-0" ABOVE NOSING LINE.

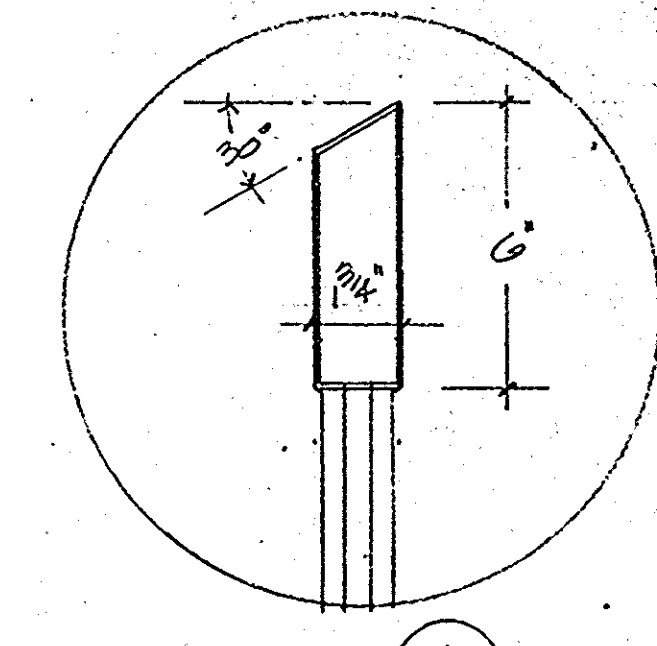

DET. A
1/4" = 1'-0"

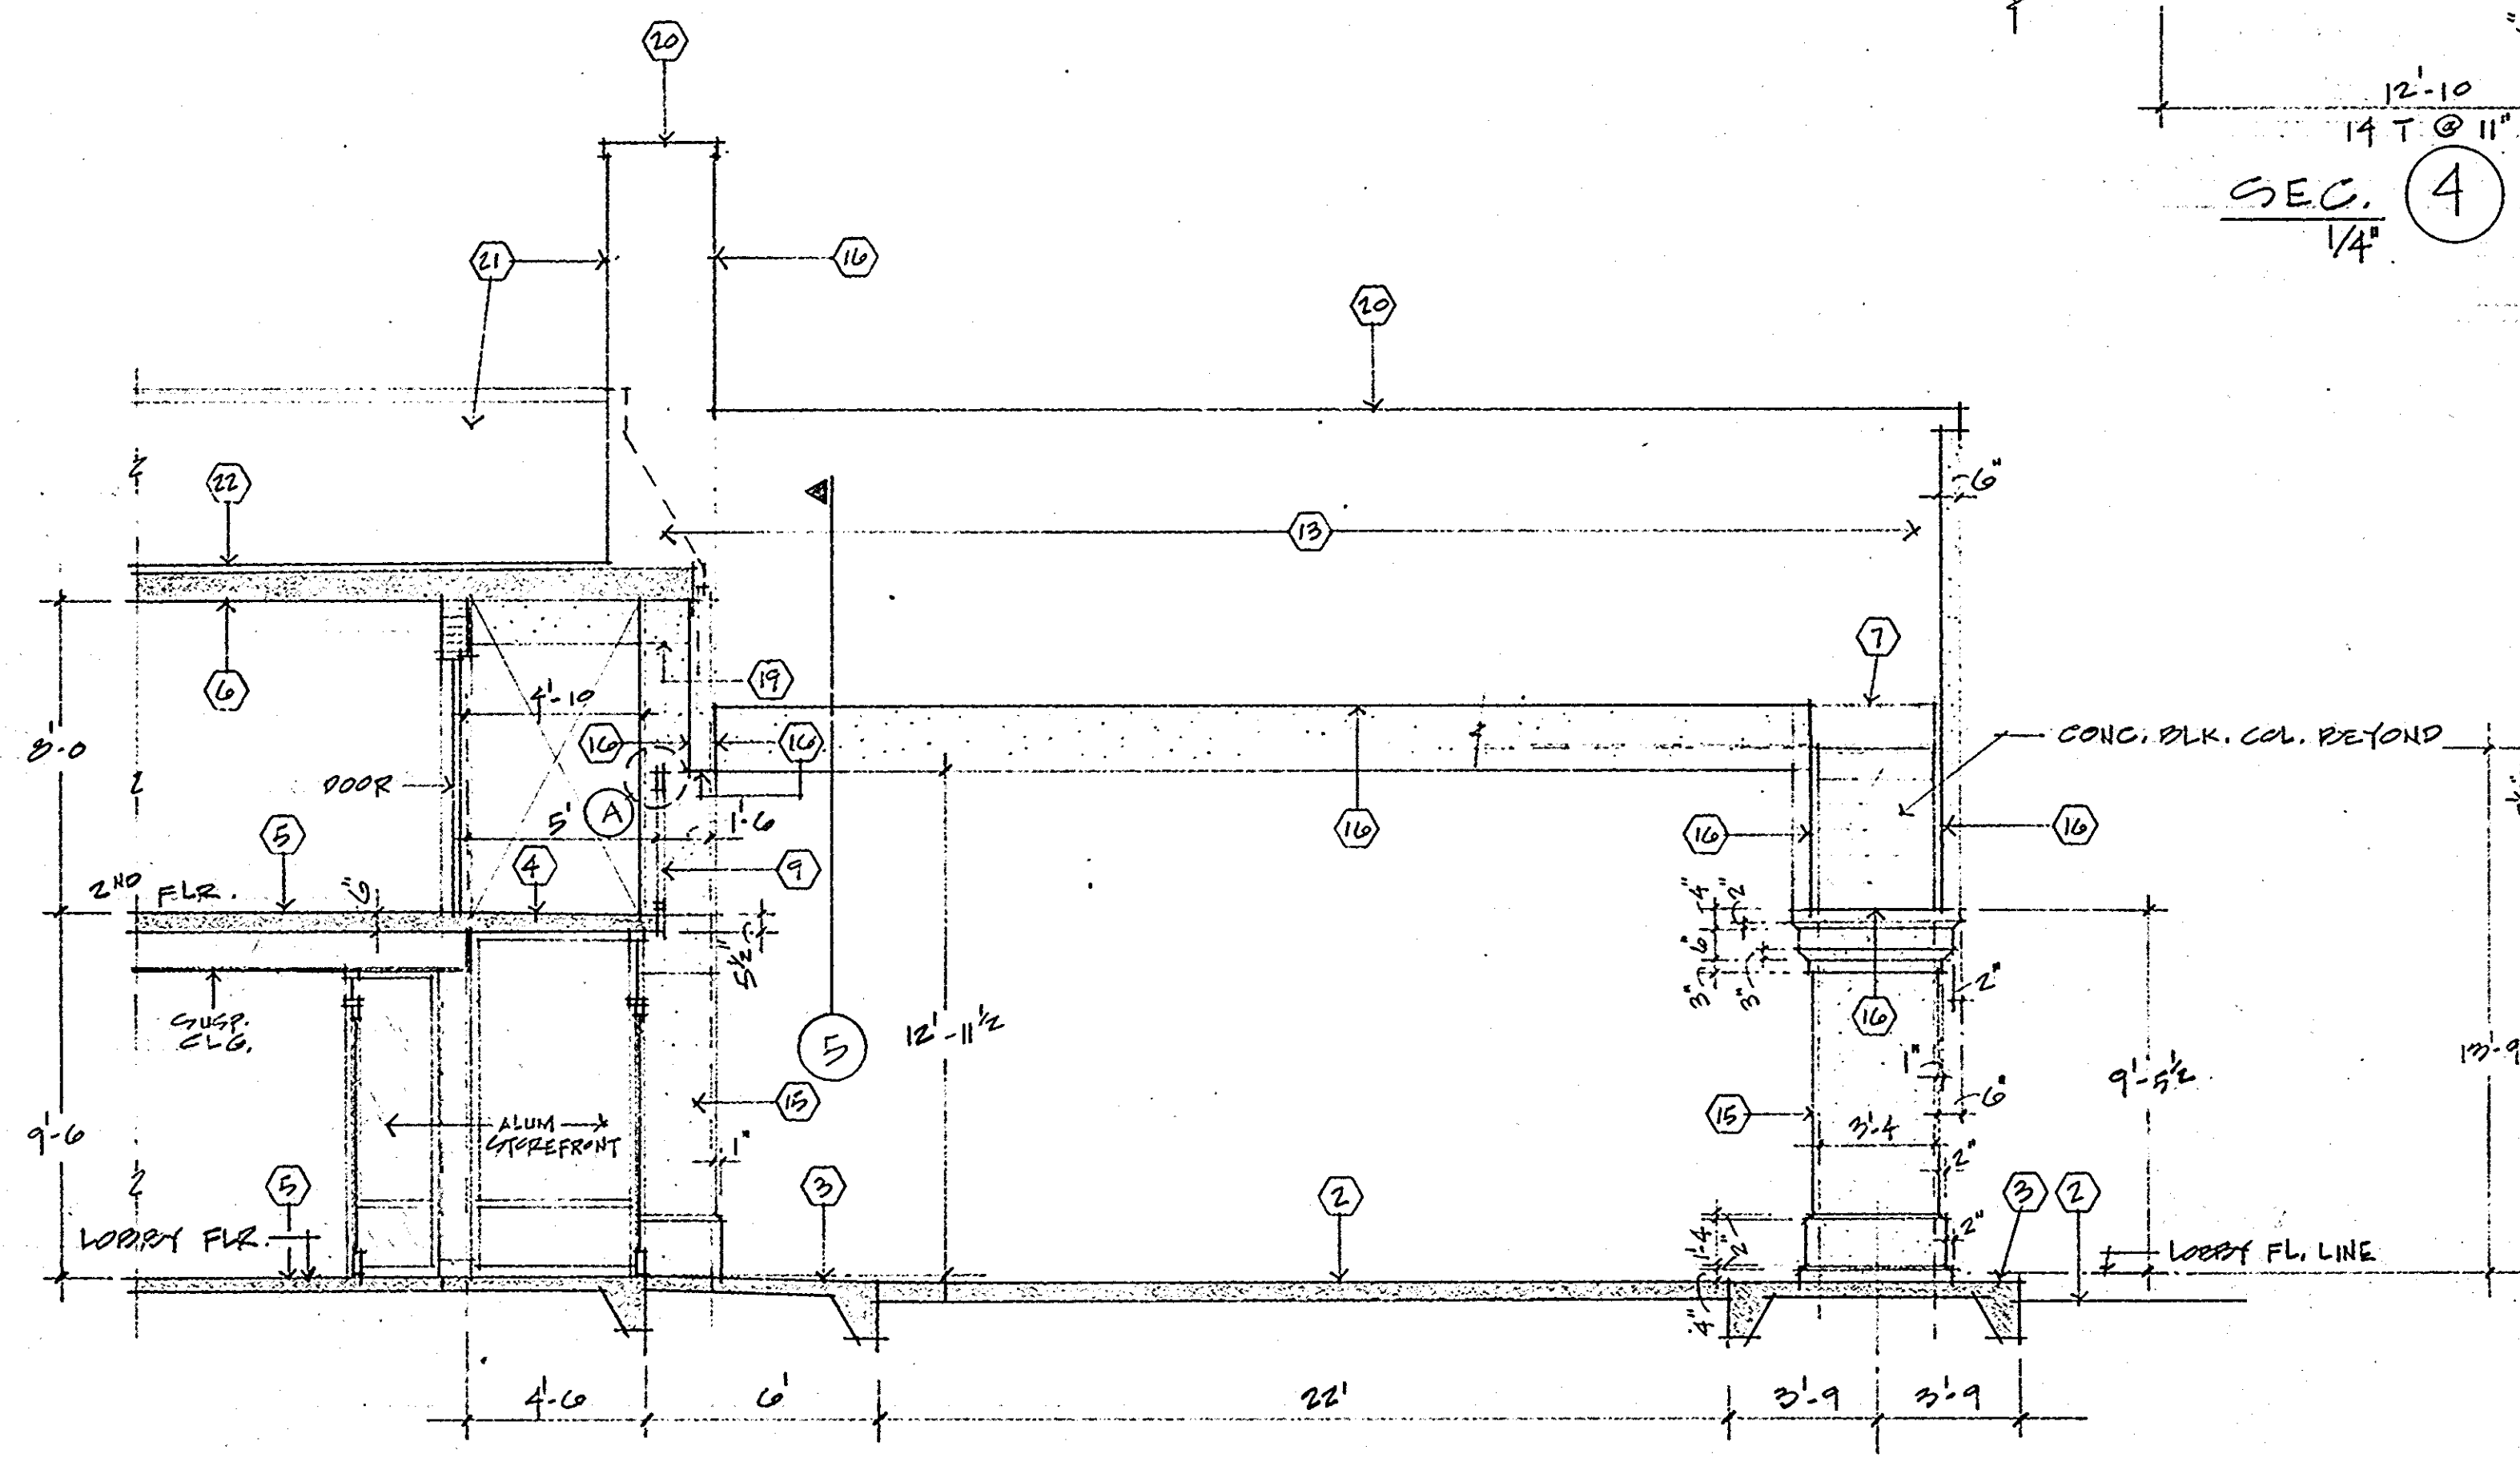

SEC. 3
1/4" = 1'-0"

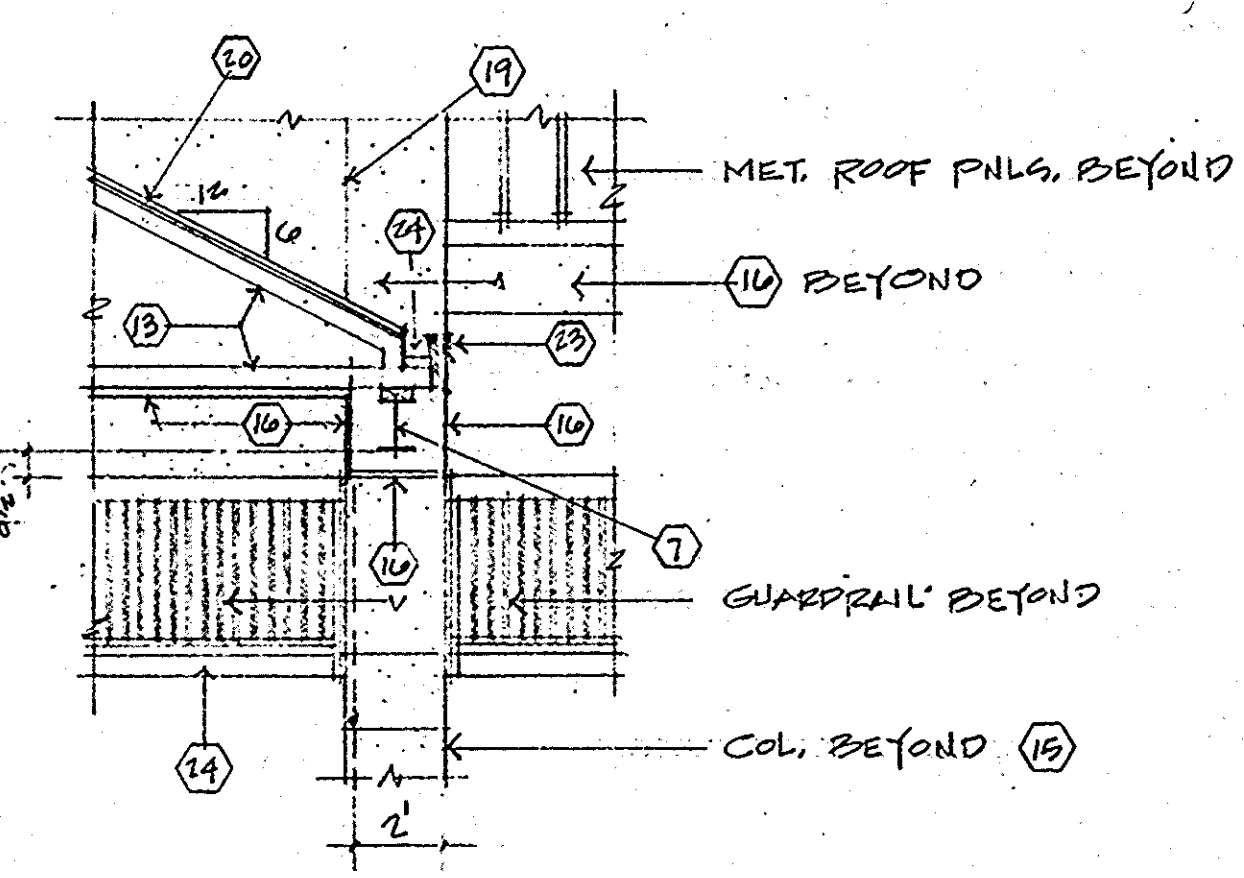

SEC. 5
1/4" = 1'-0"

REV. 3-21-93

HAMPTON INN MONROE, LA		DESIGN CONSORTIUM HOTEL CONSULTANTS MEMPHIS, TENNESSEE	
BUILDING SECTIONS AND DETAILS	DATE	3-10-93	A-7
	SCALE		
	JOB NO.		

DOOR SCHEDULE									
NO.	SIZE	DESCRIPTION	MARK	SIZE	DESCRIPTION	MARK	SIZE	DESCRIPTION	MARK
1	3'0" x 7'0"	A G S T Y CC	AA	2	3'0" x 7'0"	A G S T Y CC			
3	2'6" x 6'8"	D H K Q S		4	2'0" x 6'8"	D H K Q S			
5	2'6" x 6'8"	D H U R S		6	3'0" x 6'8"	E H U R S			
7	3'0" x 6'8"	D H U R V Y		8	3'0" x 6'8"	D H U R V Y			
9	2'6" x 6'8"	B H N P Q S		10	2'6" x 6'8"	E H K Q U			
11	3'0" x 6'8"	D H K M Q S Y		12	2'0" x 6'8"	E H K Q U			
13	4'0" x 6'8"	D H K Q S Y		14	3'0" x 6'8"	E H O Q S			
15	3'0" x 6'8"	B H K Q S W		16	3'0" x 6'8"	B H K Q S W			
17	3'0" x 6'8"	B H O Q S		18					
19	3'0" x 6'8"	B H K Q S W		20	3'0" x 6'8"	E F K Q S Z			




DOOR SCHEDULE									
NO.	SIZE	DESCRIPTION	MARK	SIZE	DESCRIPTION	MARK	SIZE	DESCRIPTION	MARK
21	2'6" x 6'8"	E I Q U		22	2'0" x 6'8"	E I Q V			
23	2'6" x 6'8"	B H Q S		24	2'6" x 6'8"	B H Q S W X			
25	3'0" x 6'8"	B H Q S W		26	3'0" x 6'8"	B H P Q S			

DOOR DESCRIPTION LEGEND									
A	ALUM. ENTRANCE	B	HOL. MET. FLUSH	C	HOL. MET. 6 PANEL	D	WOOD SOLID CORE	E	WOOD HOLLOW CORE
F	MIRROR (SUBMIT SHG.)	G	ALUMINUM	H	HOLLOW METAL	I	WOOD	J	PURCH
K	1/2" HARDWARE	L	20 MINUTE	M	C-3/4 HR.	N	D-1/2 HR.	O	DOT. HALF
P	FULL	Q	PAINT	R	STAIN	S	KEYED LOCK	T	EXIT DEVICE
U	PASSAGE LATCH	V	PRIVACY BATH LOCK	W	W/STRIP GASKET	X	ALUM. SADDLE	Y	SURFACE CLOSER
Z	POCKET DOOR FRAME & ACCESSORIES								

DOOR DESCRIPTION LEGEND									
AA	HARDWARE:	BB	HARDWARE:	CC	KANNEER OR EQUAL NARROW				
AA	MORTISE LOCKSET: VINCARD 1060	BB	SURFACE SLIDE BOLT	CC	STILE (1/2" H. BOT. RAIL) W/				
AA	1/2" BRASS HINGES	BB	HINGES - 1/2" FR.	CC	MFR'S STD. HARDWARE - SEE				
AA	PAVING BAR DOOR GUARD			CC	STOREFRONT ONGS. FOR FINISH & GL.				
AA	ONE-WAY VIEWER (2. REG'D @								
AA	HANDICAPPED, LOWER VIEWER 42" AFF.)								
AA	DOOR SHOE: PEMKO 216 AN.								
AA	SADDLE: WARRIOR 3351;								
AA	3350 @ HANDICAPPED.								
AA	WEATHERSTRIPPING: PEMKO								
AA	"SILICONE SEAL" DOOR GASKET								
AA	APPLIED TO FRAME HEAD & JAMB.								

FINISH SCHEDULE																									
NO.	ROOM	FLOOR				WALLS				CEILING				FINISH				REMARKS							
		CONC. FLOOR	CARPET (COST)	RESIL. TILE	CERAMIC TILE	QUARRY TILE	OAK 1x6	VINYL	CERAMIC TILE	QUARRY TILE	CONC. BLOCK	GYPSUM BO.	FINISH		FINISH										
													PAINT	VNIC (COST)	CERAMIC TILE	CONCRETE	GYPSUM BO.		LAST. PAINTS.	PAINT	GRAY TEXT.	FACTORY			
		1	2	3	4	5	6	7	8	9	10	11	12	13	14	15	16	17	18	19	20	21	22	23	







FINISH NOTES									
1.	GUEST RM. BATH								
2.	ELEC. PAINT SHALL								
3.	BE ENAMEL								
4.	APPROVED FOR USE								

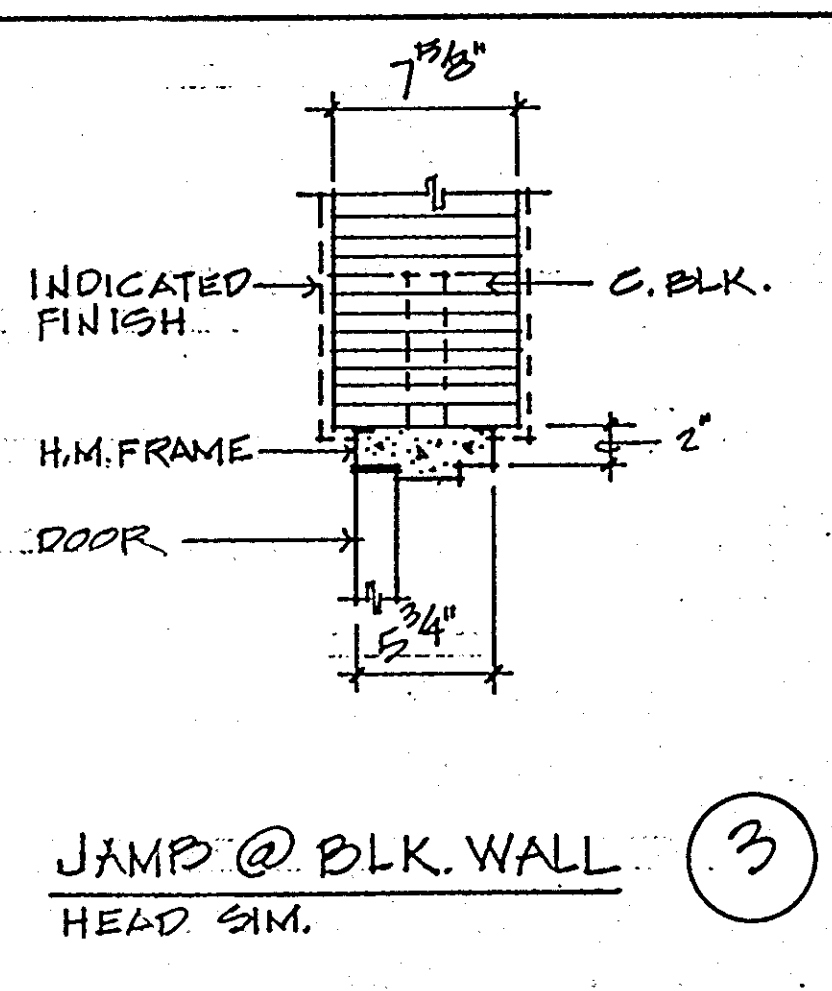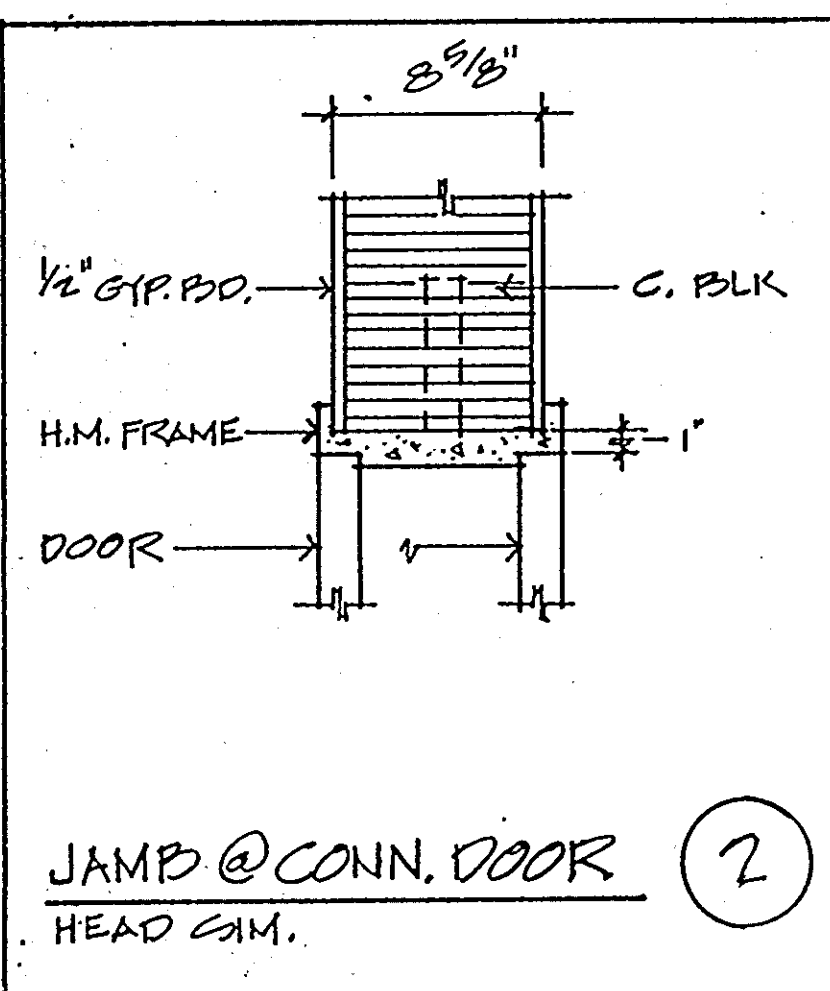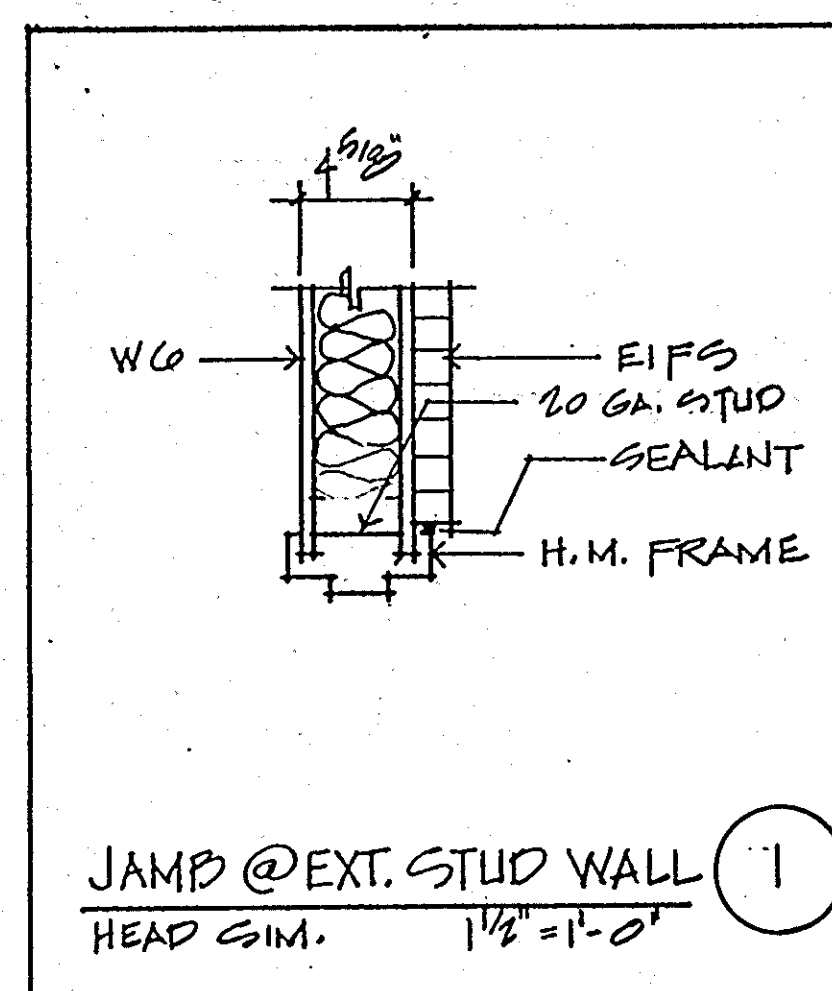


- ### DOOR NOTES
- WOOD DOORS, HOLLOW METAL DOORS TO BE 1 3/4" THK. UNLESS NOTED OTHERWISE.
 - EXT. HOLLOW MET. DOORS TO OR FROM CONDITIONED SPACE TO BE INSULATED.
 - WHERE REQ'D, DOOR HARDWARE SHALL CONFORM TO ADA & GOVERNING HANDICAP CODE.
 - VERIFY KEYING REQUIREMENTS W/ OWNER.
 - PROVIDE 1/2" HR. FIB. LINK LOWER IN DOOR MK. 9.
 - DEL. CARPET PAD (COST) TO BE PROVIDED @ CONNECTING DOORS.

WALL SCHEDULE									
NO.	DESCRIPTION	MARK	SIZE	DESCRIPTION	MARK	SIZE	DESCRIPTION	MARK	SIZE
W1	EXT. 1 HR			W10					
W2	EXT. 1 HR			W11					
W3	THK. 1 HR			W12					
W4	THK. 1 HR			W13					
W5	THK. 1 HR			W14					

- ### WALL KEYNOTES
- 8" CONC. BLK.
 - EXTERIOR INSULATED FINISH SYSTEM
 - 1/2" GYP. DO.
 - 5/8" TYPE X GYP. DO.
 - 1/2" GYP. SHEATH.
 - 2x4 MET. STUDS 16" OC
 - THERMAL INSULATION: 3/8" GLASS FIBER
 - GROUND BATT: 3/8" GLASS FIBER
 - 2x4 MET. STUDS 16" OC
 - 2 LAYERS 5/8" TYPE X GYP. DO.

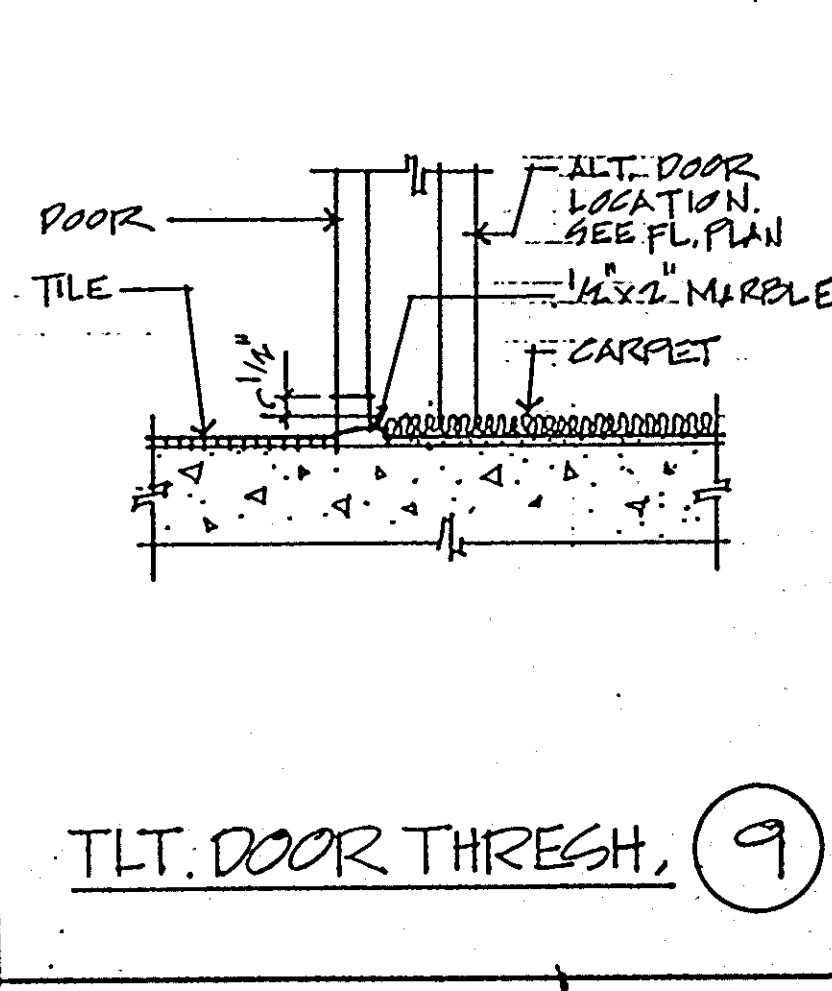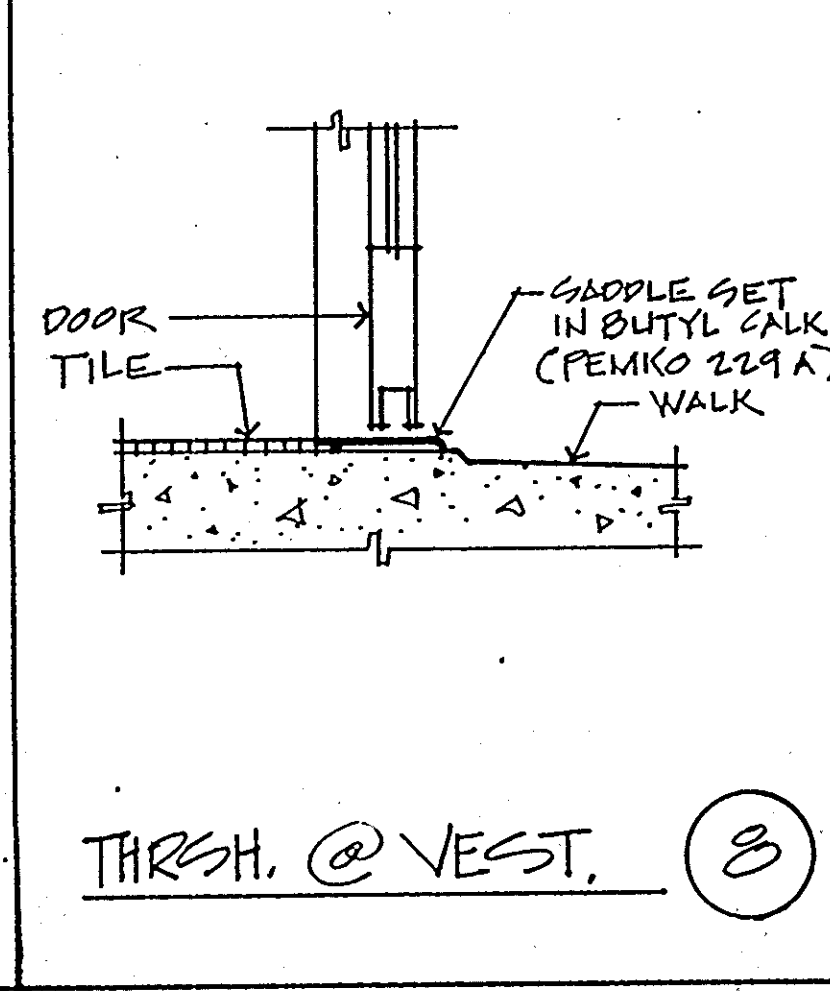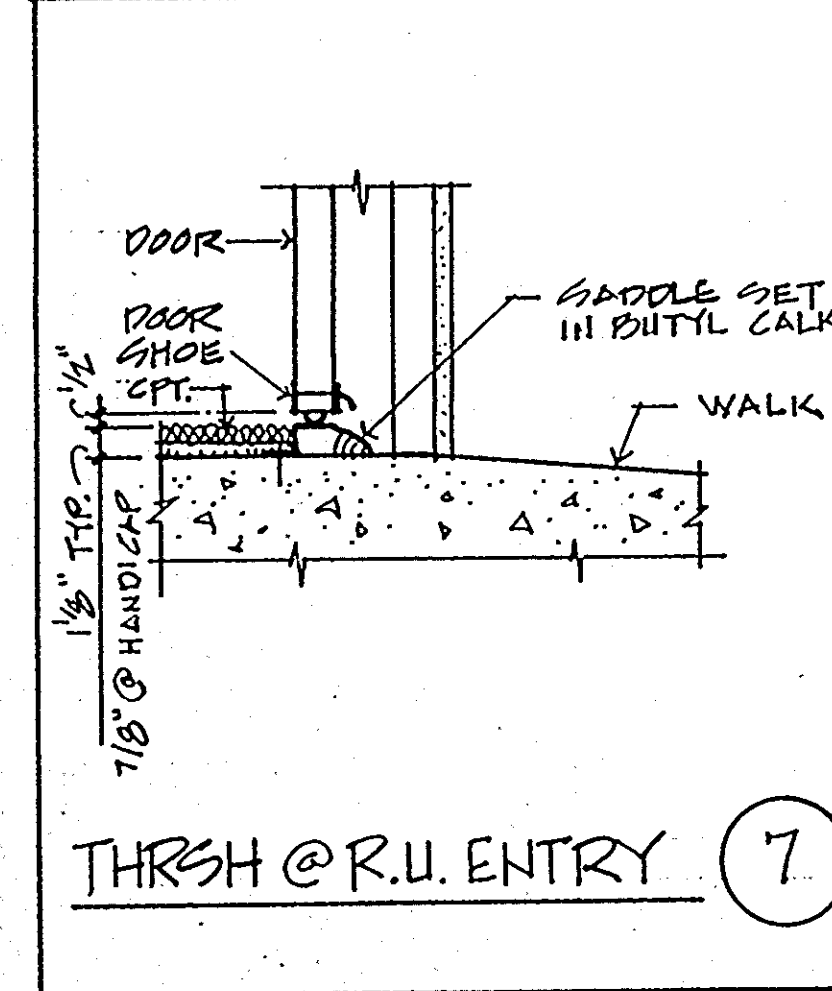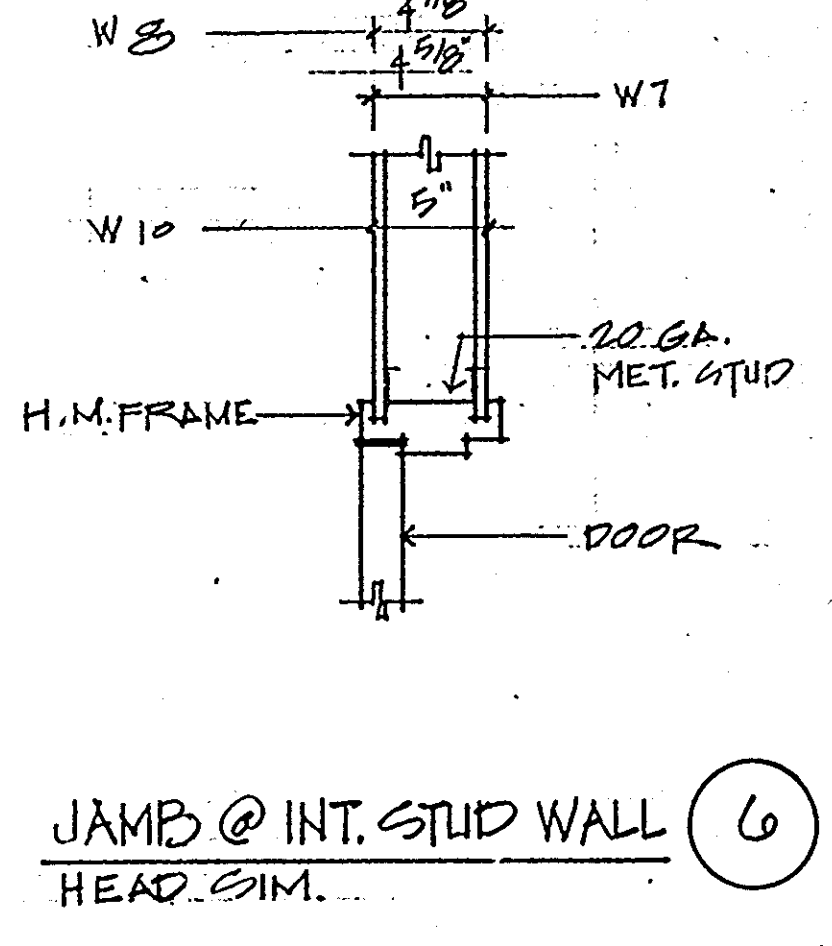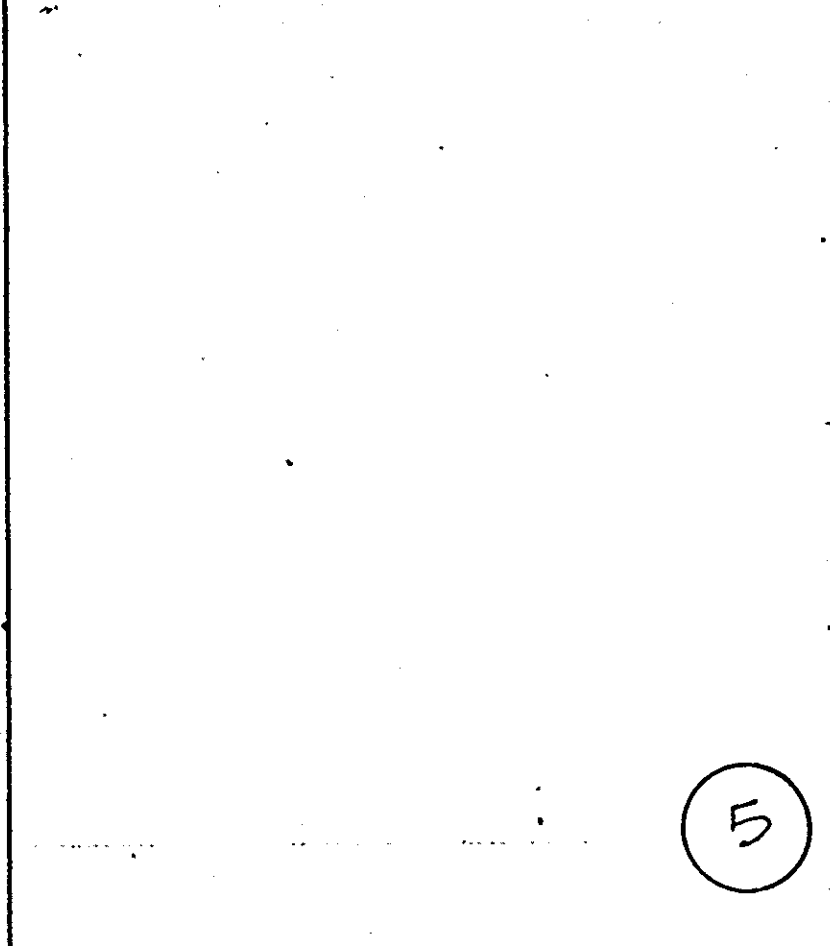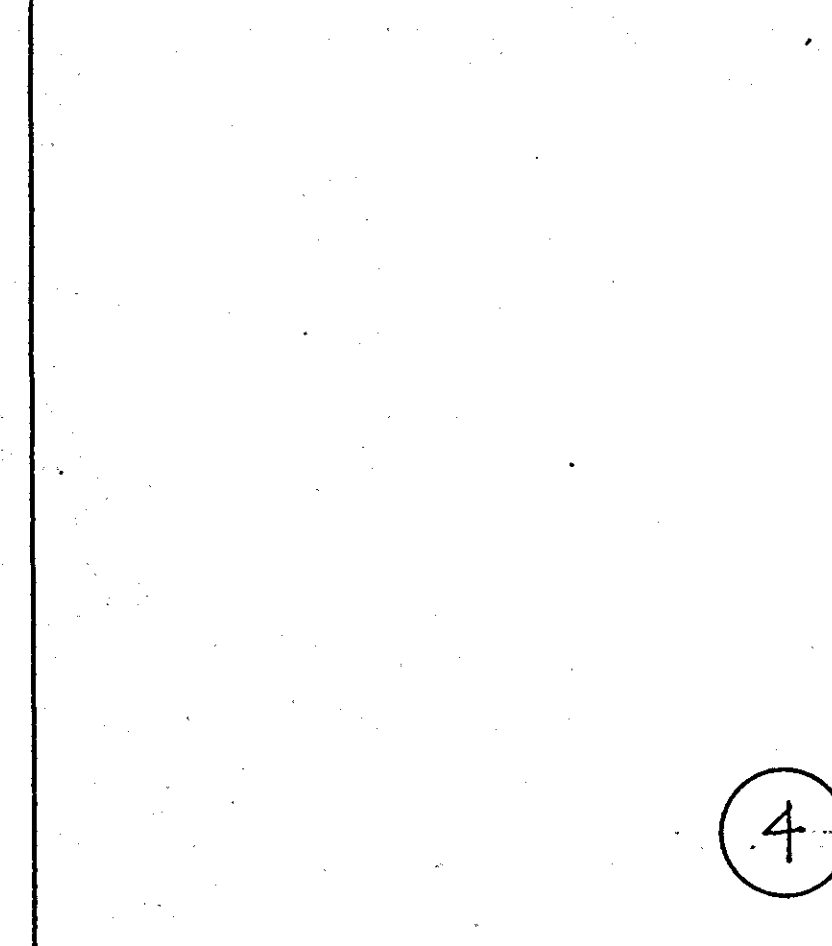

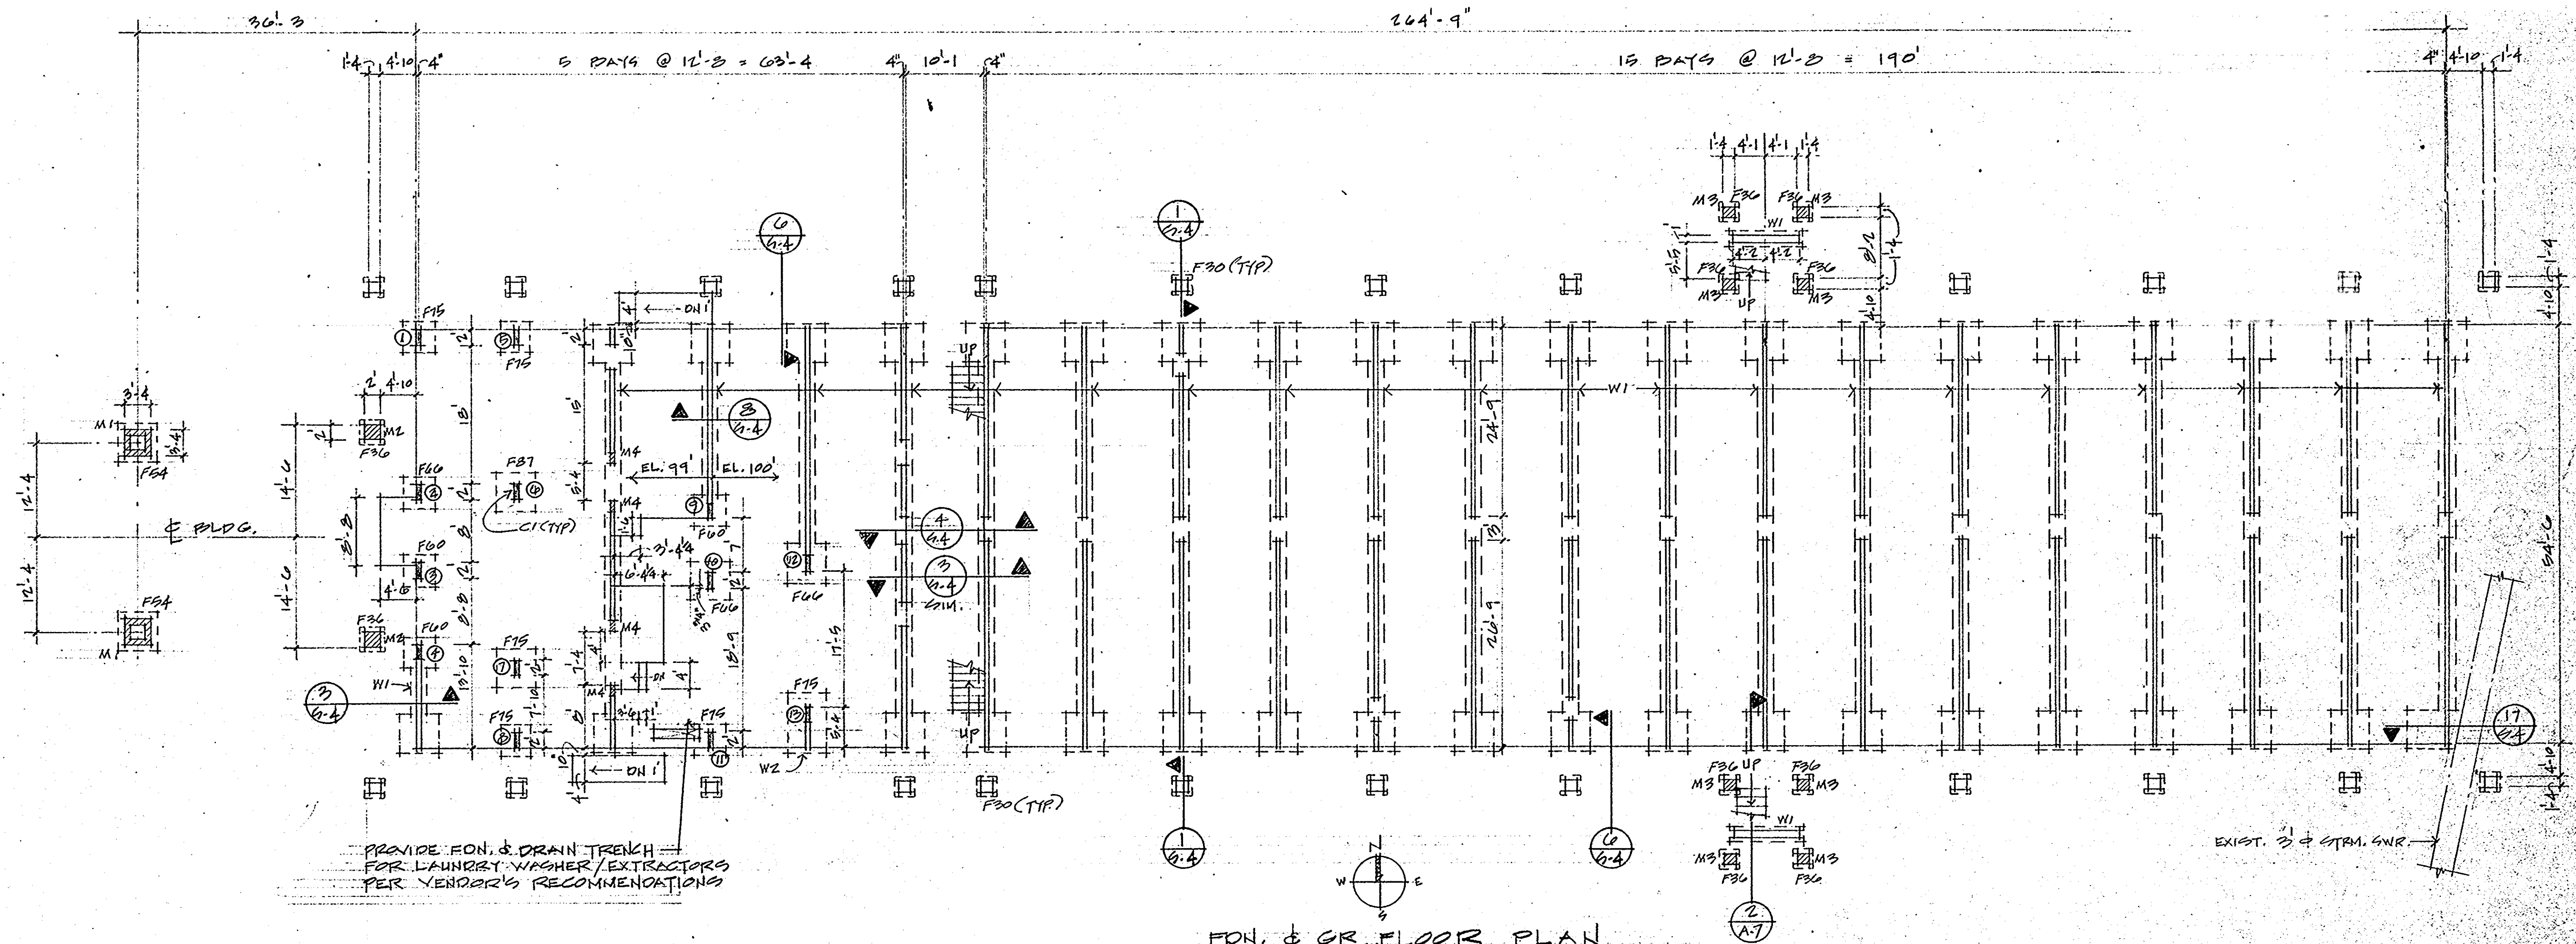

NOTES:


- FLOOR SLAB - 4" CONC. W/ 6x6x10 WMM ON VAPOR BARRIER (DAMP-PROOFING) ON GRADE (PREPARED IN ACCORDANCE W/ GEOTECHNICAL INVESTIGATION GUIDELINES).
- MASONRY WALLS
 - FILL 1 BLK. SOLID EL. SIDE OF WALL OPPOS.
 - FILL ALL BLK. SOLID BELOW FIN. FLR. ELEV.

COLUMN FOOTING SCHEDULE		
MARK	SIZE W x L x D	REINFORCING ONE HALF EACH WAY
F30	2'-6" x 2'-6" x 14"	6 #4 x 2'-0"
F31	3'-0" x 3'-0" x 14"	6 #4 x 2'-6"
F32	4'-6" x 4'-6" x 14"	8 #6 x 4'-0"
F33	5'-0" x 5'-0" x 14"	12 #6 x 4'-6"
F34	5'-6" x 5'-6" x 14"	10 #7 x 5'-0"
F35	6'-3" x 6'-3" x 14"	14 #7 x 5'-9"
F36	7'-3" x 7'-3" x 15"	14 #8 x 5'-9"


WALL FOOTING SCHEDULE					
MARK	TYPICAL			SPECIAL END	
	SIZE W x D	CONT. REINF.	TRANS. REINF.	SIZE W x D	REINF. ADD'L. TRANS.
W1	3'-3" x 14"	3 #5	—	6'-3" x 14"	4 #5
W2	6'-3" x 14"	7 #5	4 #5 @ 5' OC.	—	—

CONC. COLUMN SCHEDULE			
MARK	SIZE	REINF.	SKETCH
C1	2' x 24"	6 #5 V. #3 @ 8" TIES (2/SET)	


MASONRY COLUMN SCHEDULE			
MARK	SIZE	REINF.	SKETCH
M1	2'-3" x 16"	10 #5 VERT. #2 @ 8" TIES (8/SET)	
M2	4'-3" x 16"	4 #6 VERT. #2 @ 8" TIES	
M3	2'-3" x 16"	4 #5 VERT. #2 @ 8" TIES	
M4	2'-3" x 16"	2 #5 VERT. #2 @ 8" TIES	

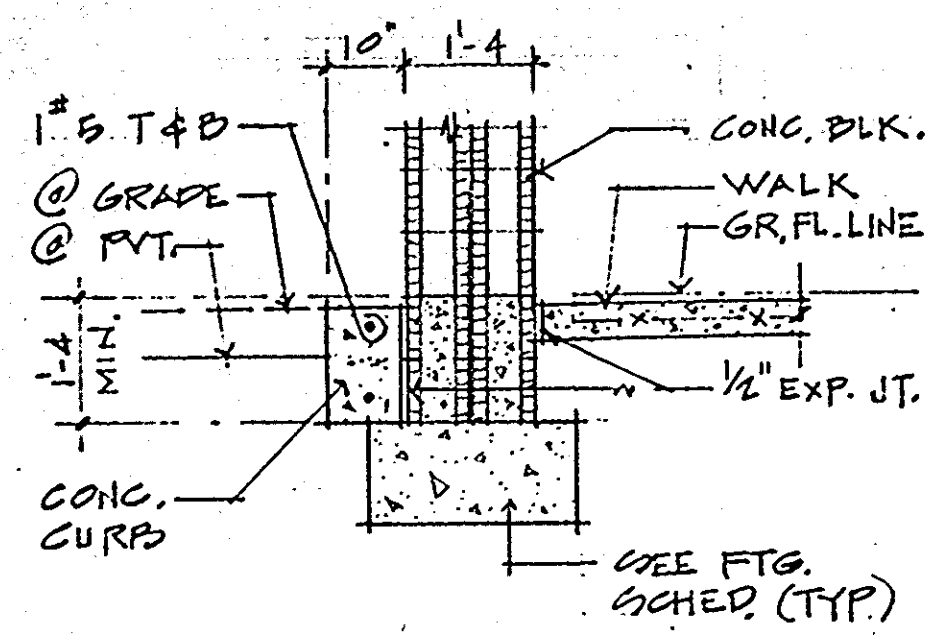


FDN: DEC. COL. 1

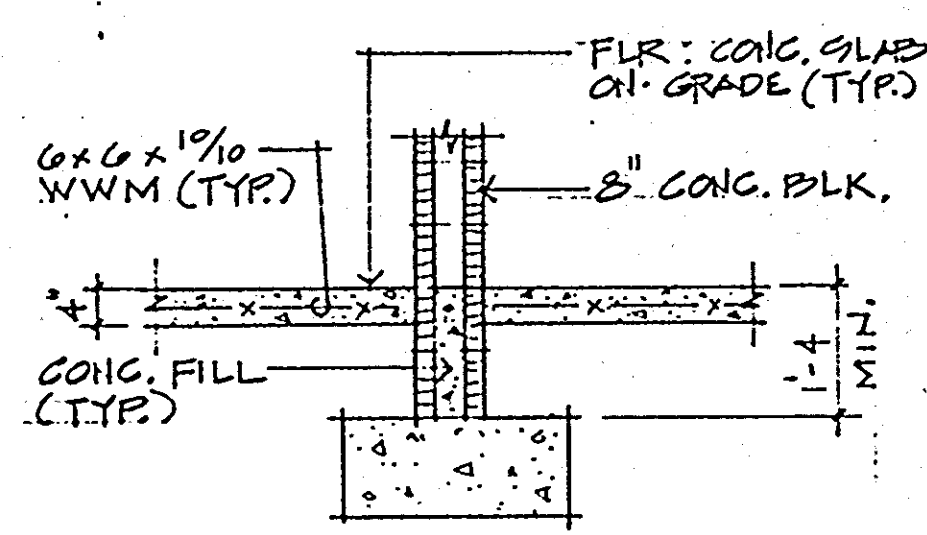


FDN: DIVIDER WALL 2

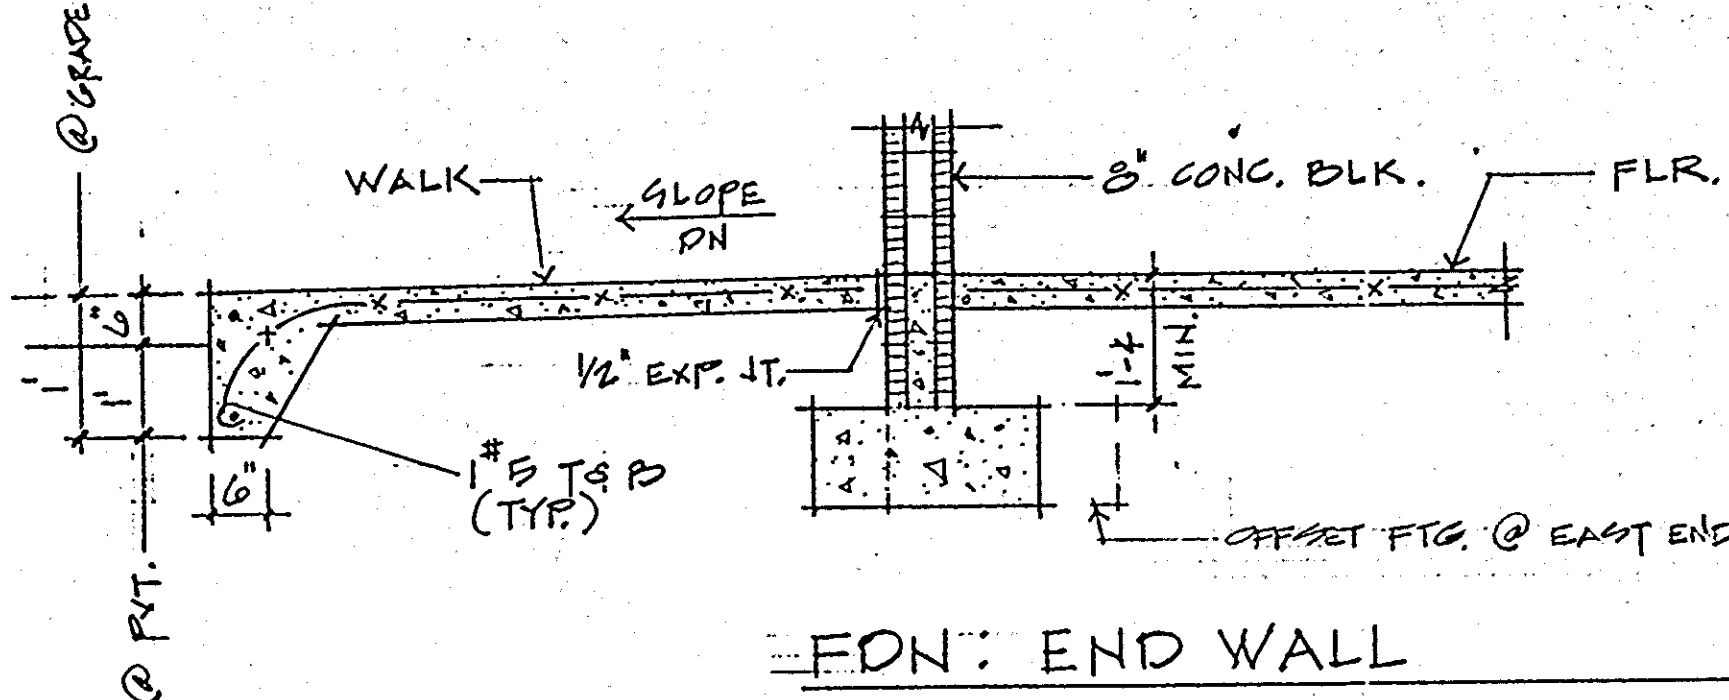


FDN: END WALL 3

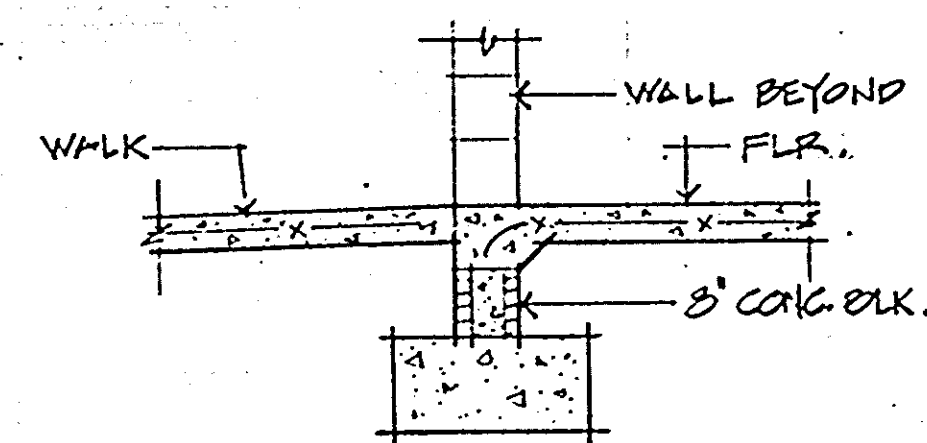


FDN: 4

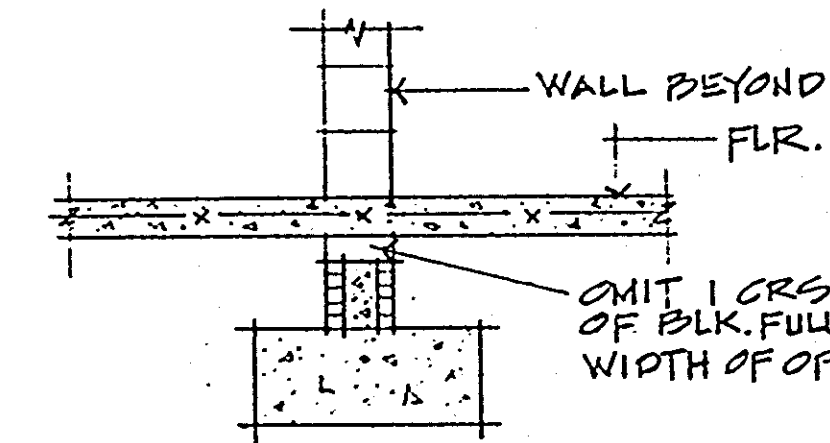


FDN: 5

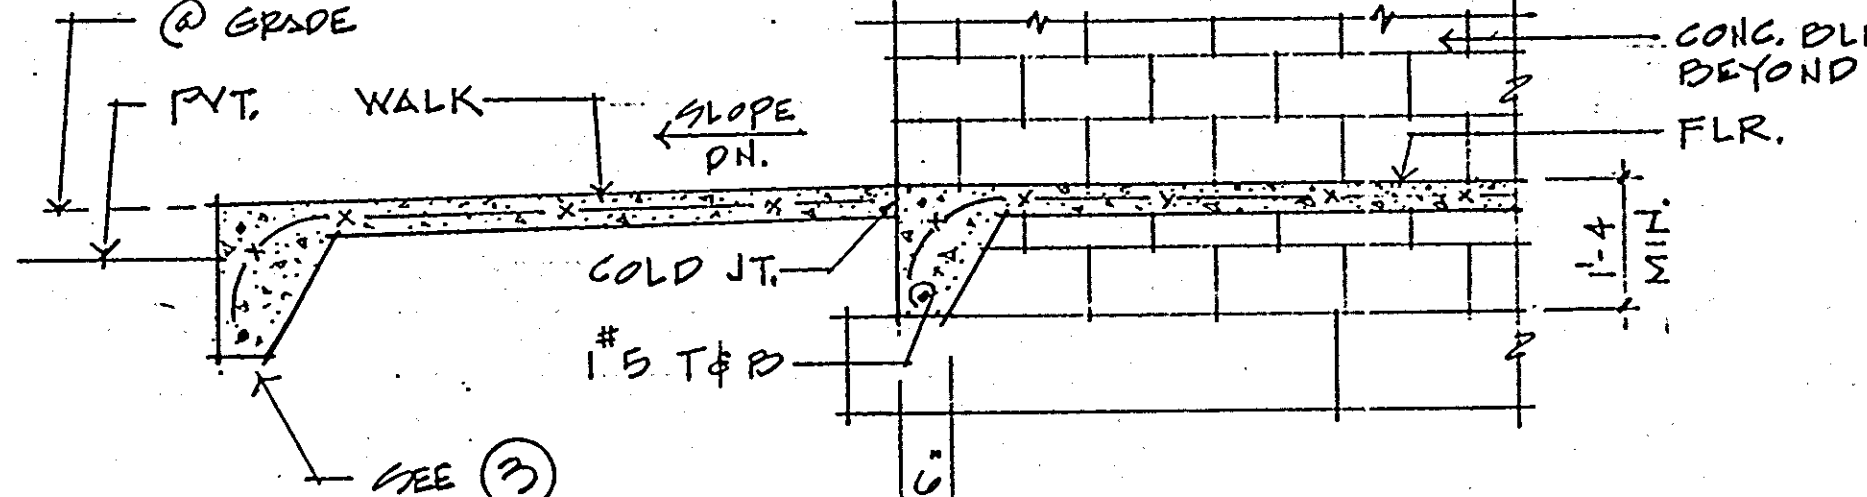


FDN: FRONT WALL 6

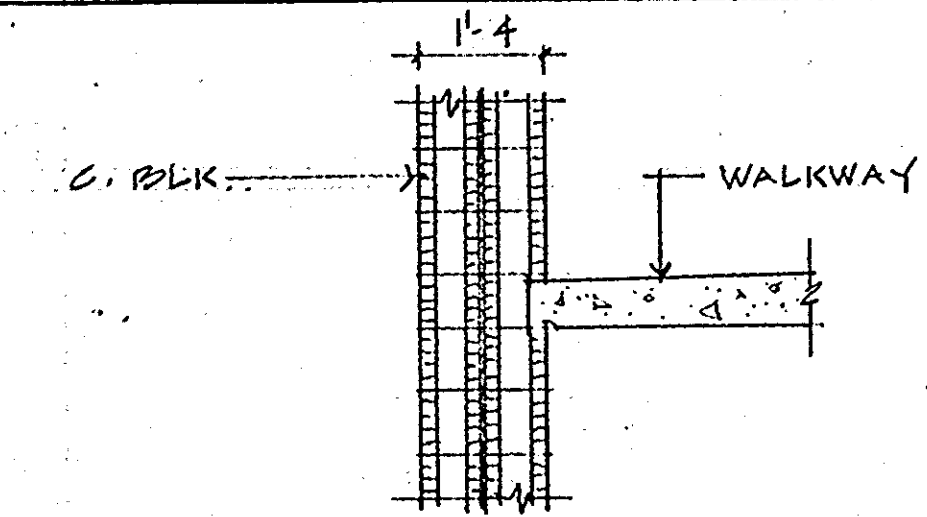


2ND FLR: DEC. COL. 7

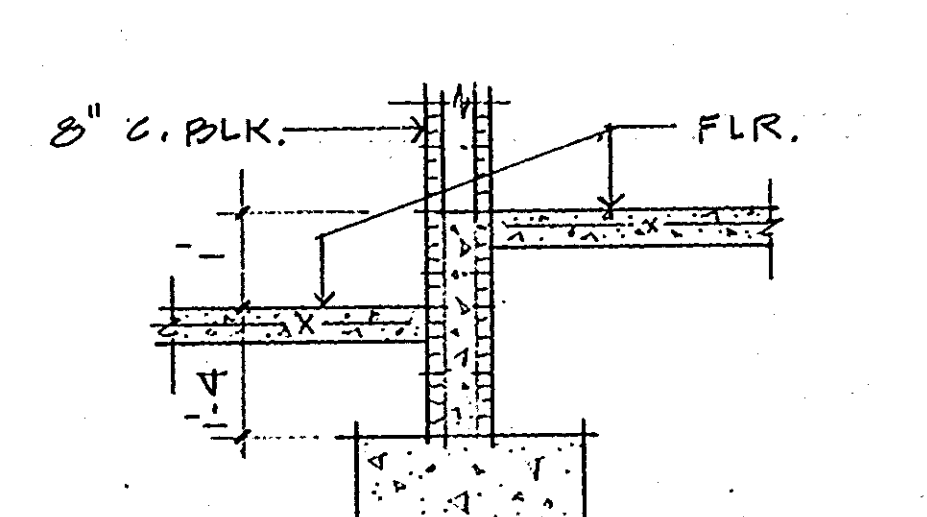


FDN: 8

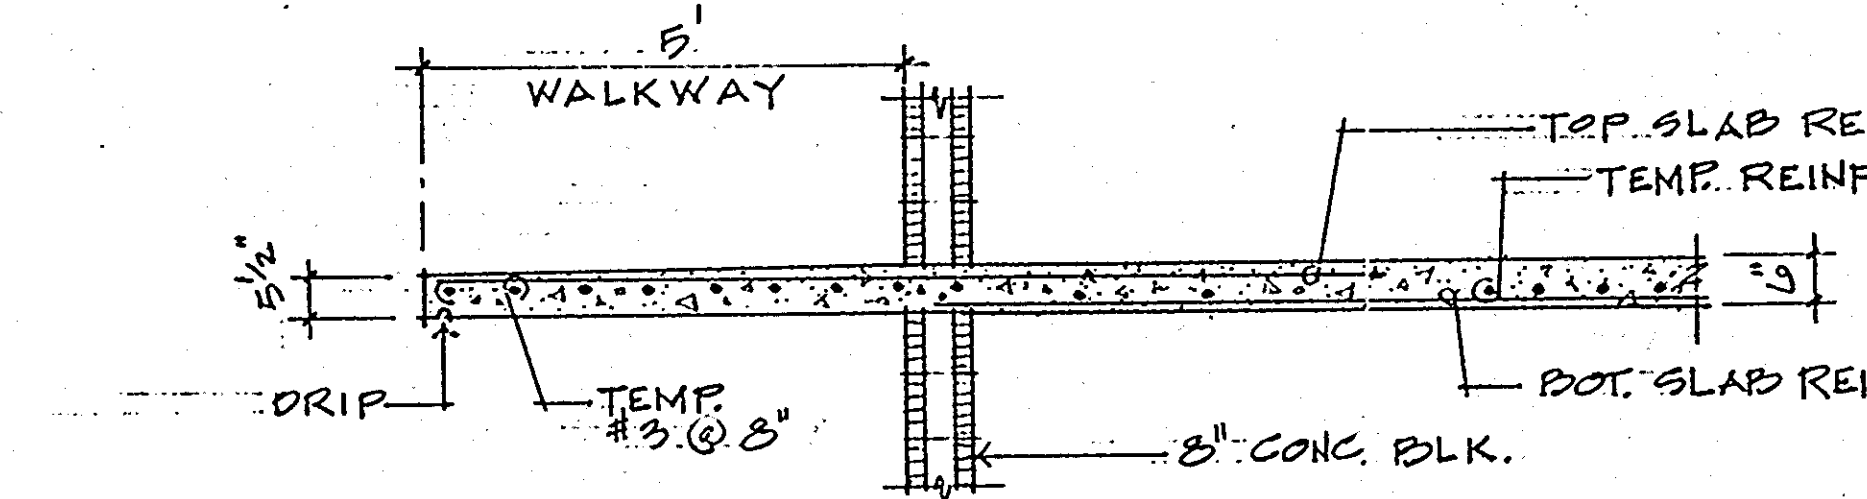


2ND FLR: END WALL 9

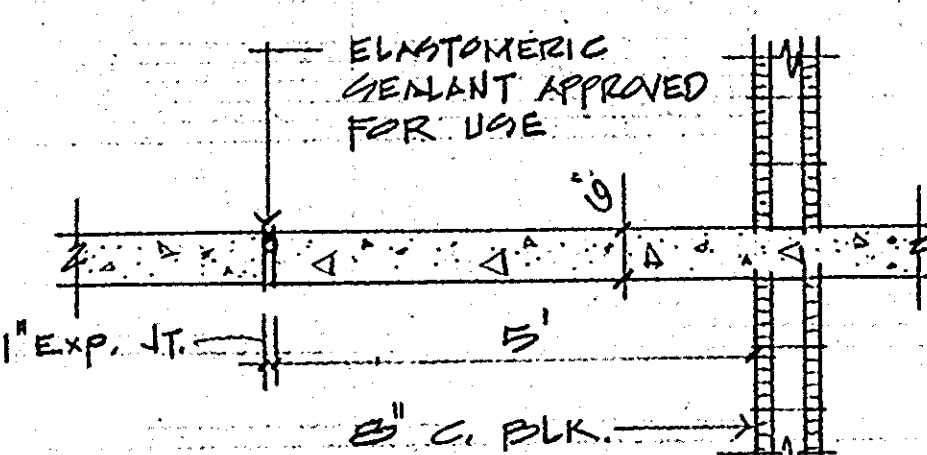


2ND FLR: BREEZEWAY 10

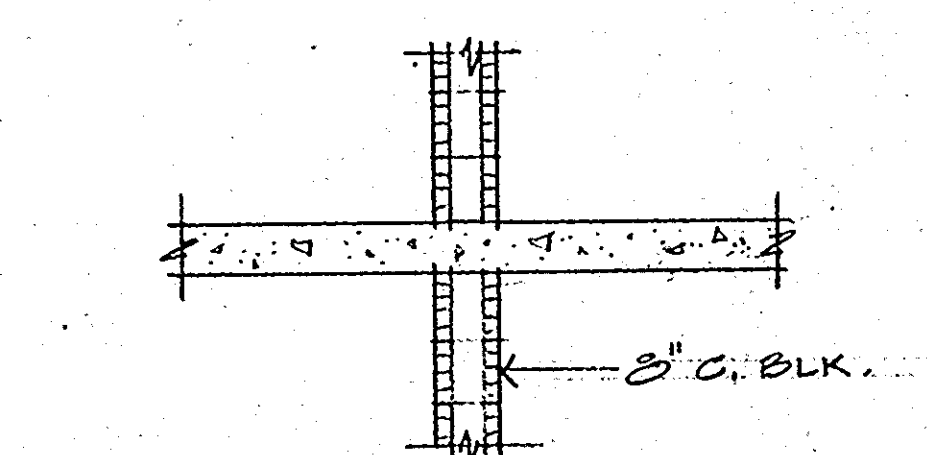


2ND FLR: DIV. WALL 11

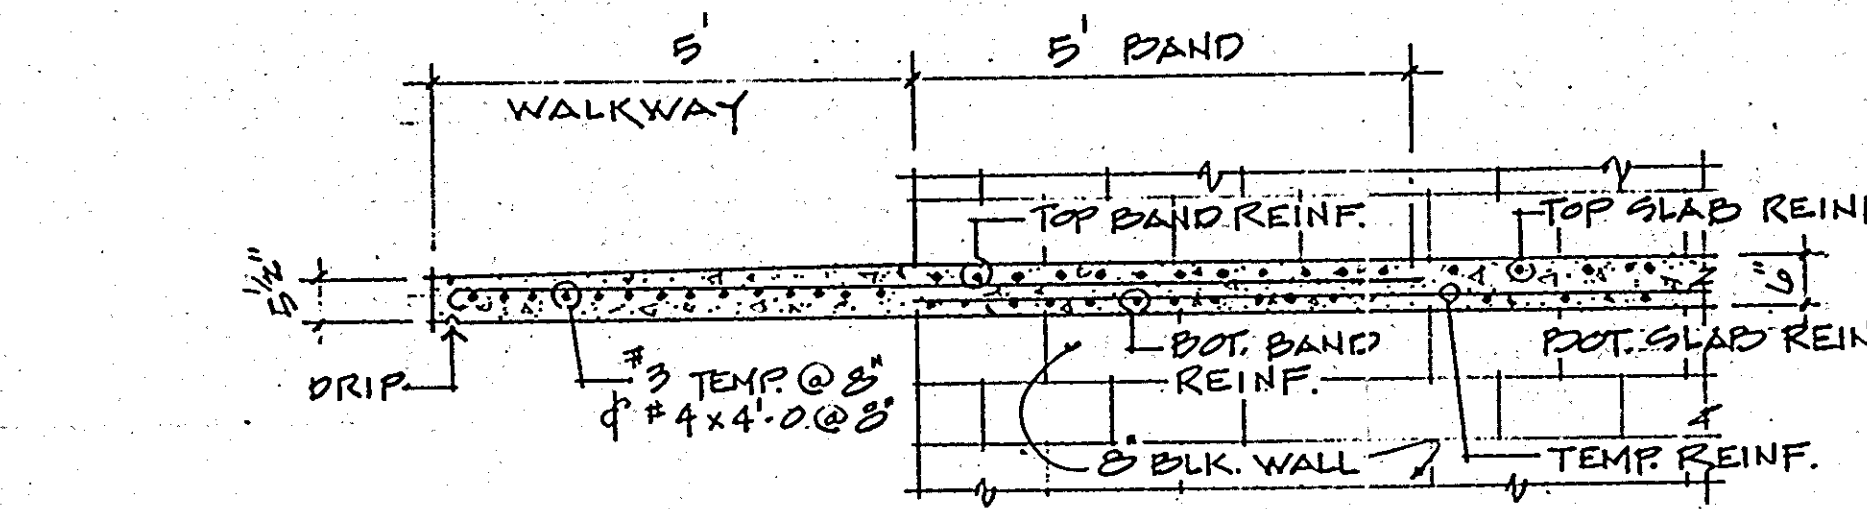


2ND FLR: FRONT WALL 12

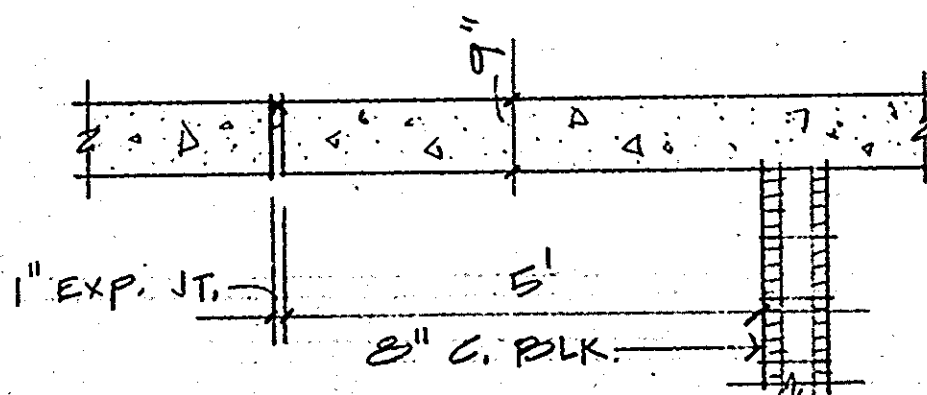


ROOF: BREEZEWAY 13

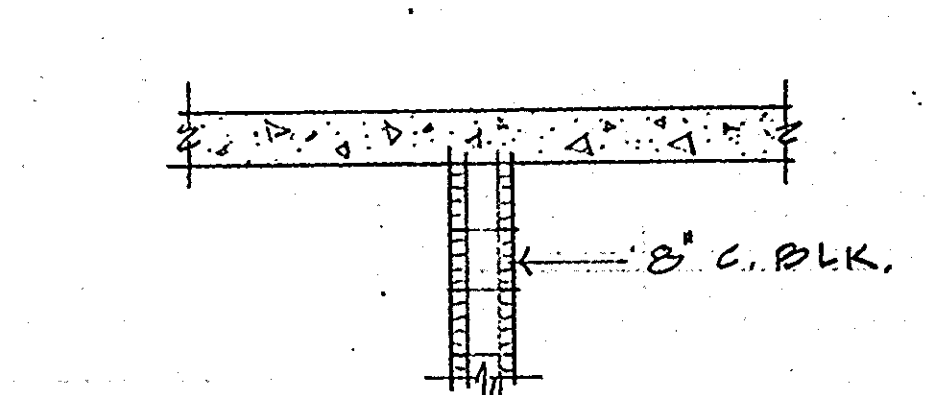


ROOF: DIV. WALL 14

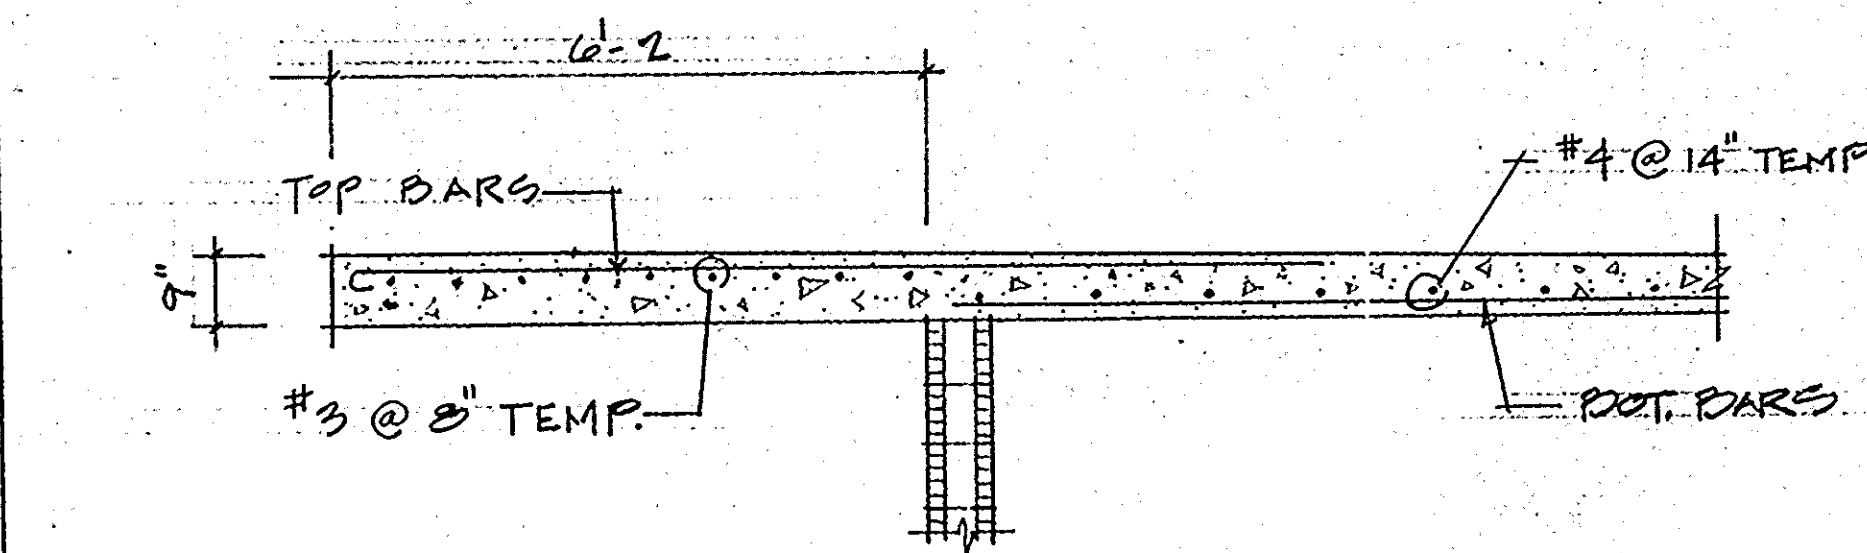

ROOF: END WALL 15

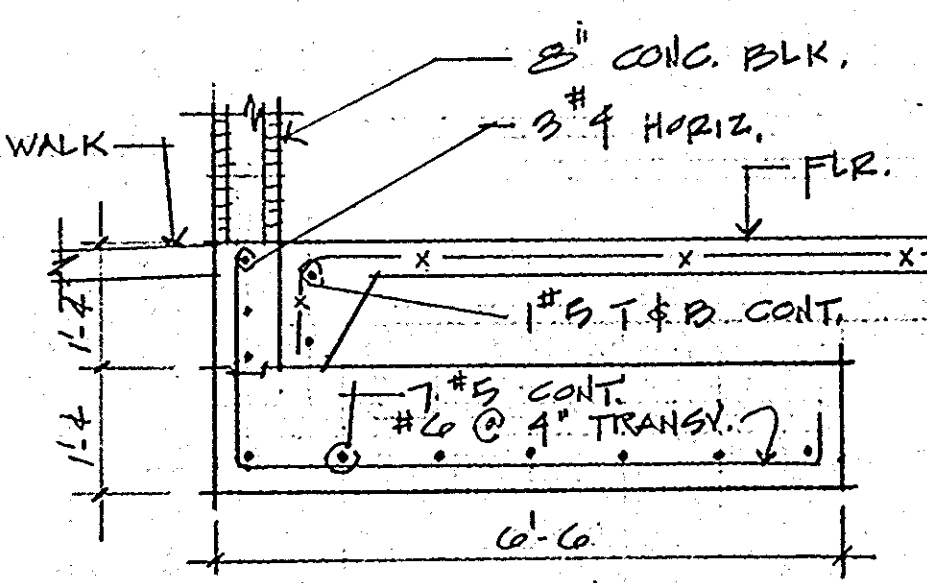

FDN: END WALL 17

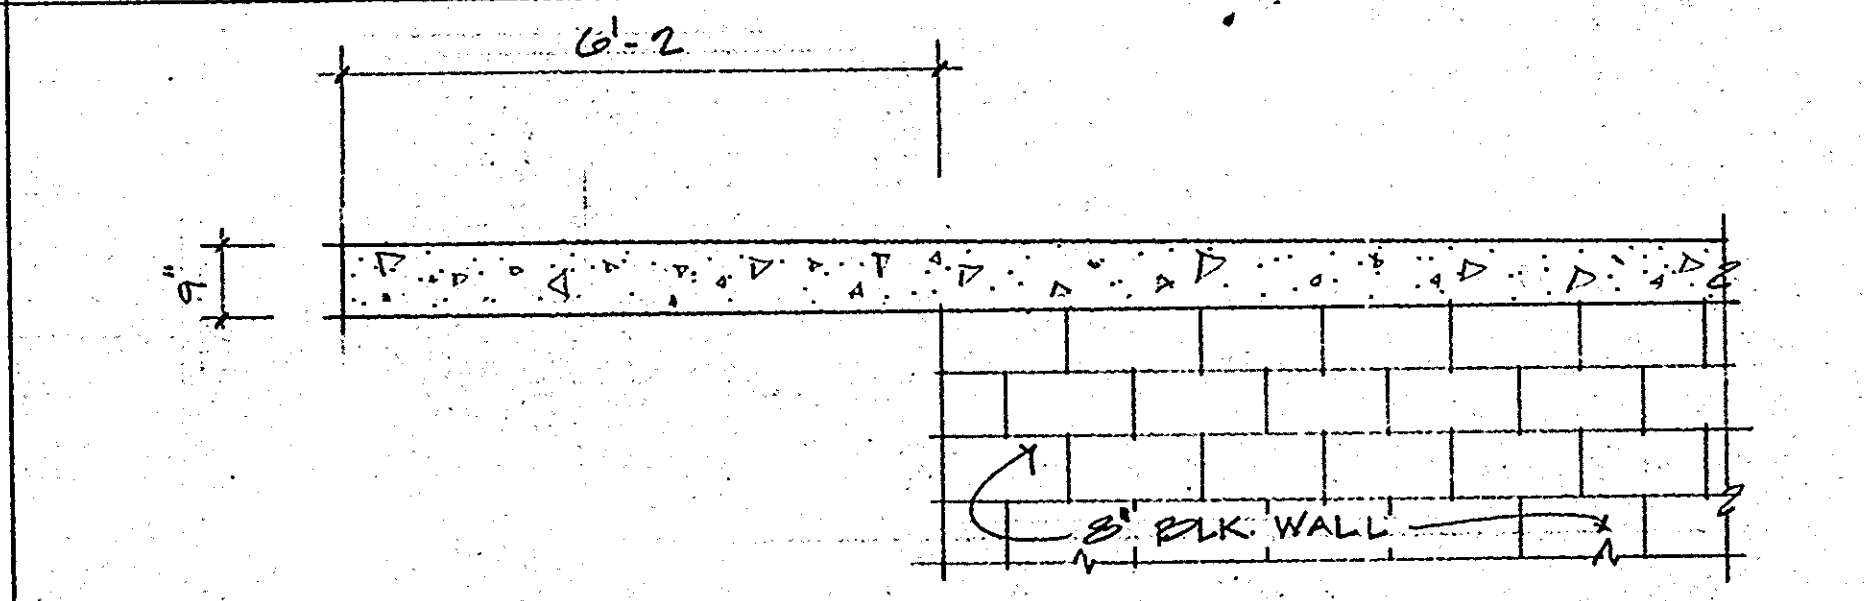

ROOF: FRONT WALL 18

GENERAL:
1. ALL WORK SHALL CONFORM TO "STANDARD BUILDING CODE", LATEST EDITION.

FOUNDATION:

- ALL BLOS. FOOTINGS & FLOOR SLABS-ON-GRADE SHALL BE SUPPORTED ON ENGINEERED FILL TO SUSTAIN BEARING PRESSURE AS RECOMMENDED BY THE SOILS ENGR. EMPLOYED BY THE OWNER.
- THE FOUNDATION IS DESIGNED FOR NET ALLOWABLE BEARING PRESSURE OF 2000 PSF FOR COLUMNS & 1500 PSF FOR WALL FTG.
-
- IT SHALL BE THE OWNER'S RESPONSIBILITY TO EMPLOY A LICENSED SOILS ENGINEER TO PROVIDE THE FOLLOWING SERVICES:
A. REVIEW THE CONSTRUCTION DOCUMENTS & STRUC. SHOP DWGS. PRIOR TO CONSTRUCTION TO ASCERTAIN THAT THE PROJECT IS IN ACCORDANCE W/ THE "GEOTECHNICAL INVESTIGATION" GUIDELINES.
B. OBSERVE ALL SITE PREPARATION TO VERIFY THAT THE WORK IS BEING PERFORMED AS RECOMMENDED BY THE "GEOTECHNICAL INVESTIGATION" GUIDELINES.

CONCRETE:


- CODES & STANDARDS: ACI 301 "SPECS. FOR STRUC. CONC. BLDGS." & ACI 318 "BLDG. CODE REQ. FOR REINF. CONC."; COMPLY W/ APPLICABLE PROVISIONS.
- STRENGTH: 28 DAY COMPRESSIVE STRENGTH OF 3000 P.S.I., EXCEPT WALKS & CONC. PVT. SHALL BE 4000 PSI.

REINFORCING:

- STANDARDS: ACI DETAILING MANUAL.
- DEFORMED REINF. BARS: ASTM A 615, GRADE 60, EXCEPT GRADE 40 FOR TIES & STIRRUPS. WELDED WIRE MESH: ASTM A 185.
- ACCESSORIES: PLASTIC TIPPED.
- MIN. BAR LAP: AT SPLICES 14 BAR DIAMETERS OR 15", WHICHEVER IS GREATER.
- PROVIDE 2 #5 EXTRA T & B AROUND ALL STRUC. SLAB OPNGS. & EXTEND SAME 12" 0" BEYOND EACH SIDE OF OPNG.

CONCRETE BLOCK:

- STANDARDS: COMPLY W/ RECOMMENDATIONS OF N.C.M.A.
- CONCRETE BLOCK: ASTM C 90, GRADE N-1 (MOISTURE CONTROLLED)
- HORIZ. JOINT REINF.: EXTRA HEAVY DUTY "OUR-O-WAL"
- MORTAR: ASTM C 270, APPROPRIATE TYPE.
- CONG. FILL: 3000 PSI.

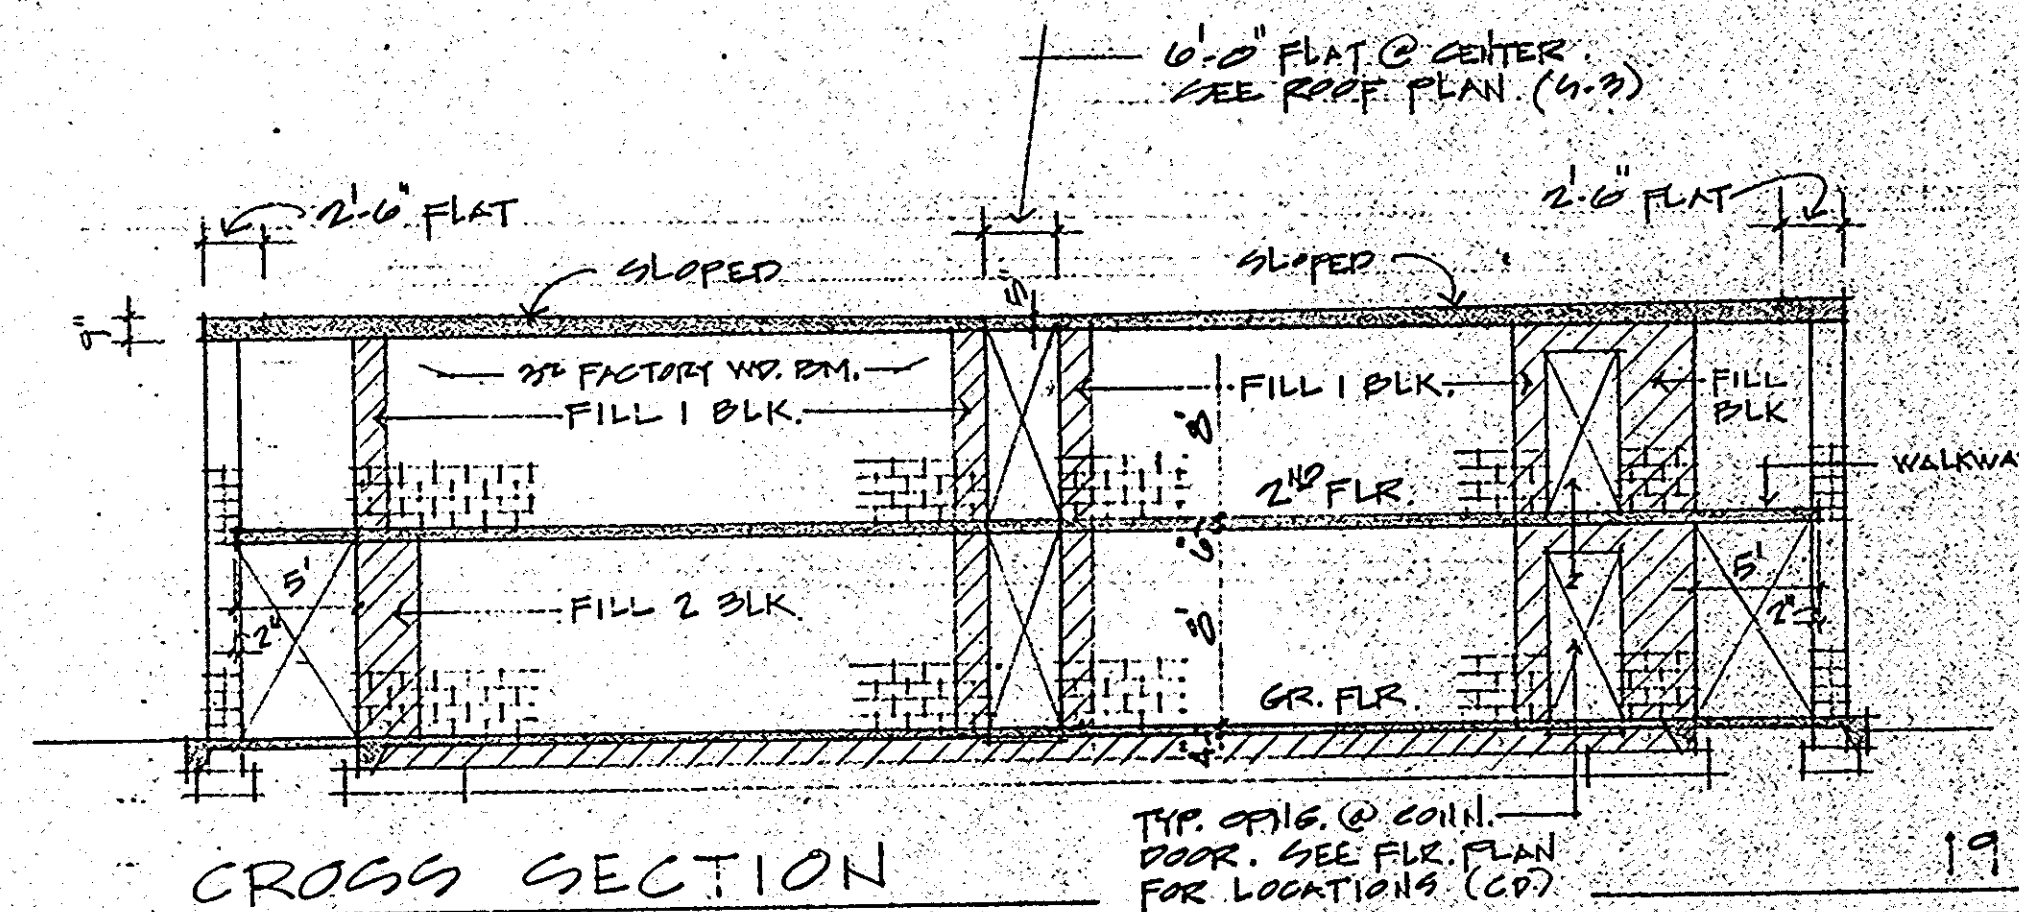


CROSS SECTION

DESIGN LOADS:

- DEAD LOADS: 10 PSF ROOFING, 10 PSF STUD PARTITIONS
- LIVE LOADS: 30 PSF ROOF, 40 PSF FLOOR, 100 PSF WALKWAYS, 300 PSF STAIR BANDS
- WIND LOAD: 20 PSF


HAMPTON INN MONROE, LA	DESIGN CONSORTIUM HOTEL CONSULTANTS MEMPHIS, TENNESSEE		
	DATE	3-11-93	S-4
MISC. STRUCTURAL DETAILS	SCALE		
	JOB NO.		

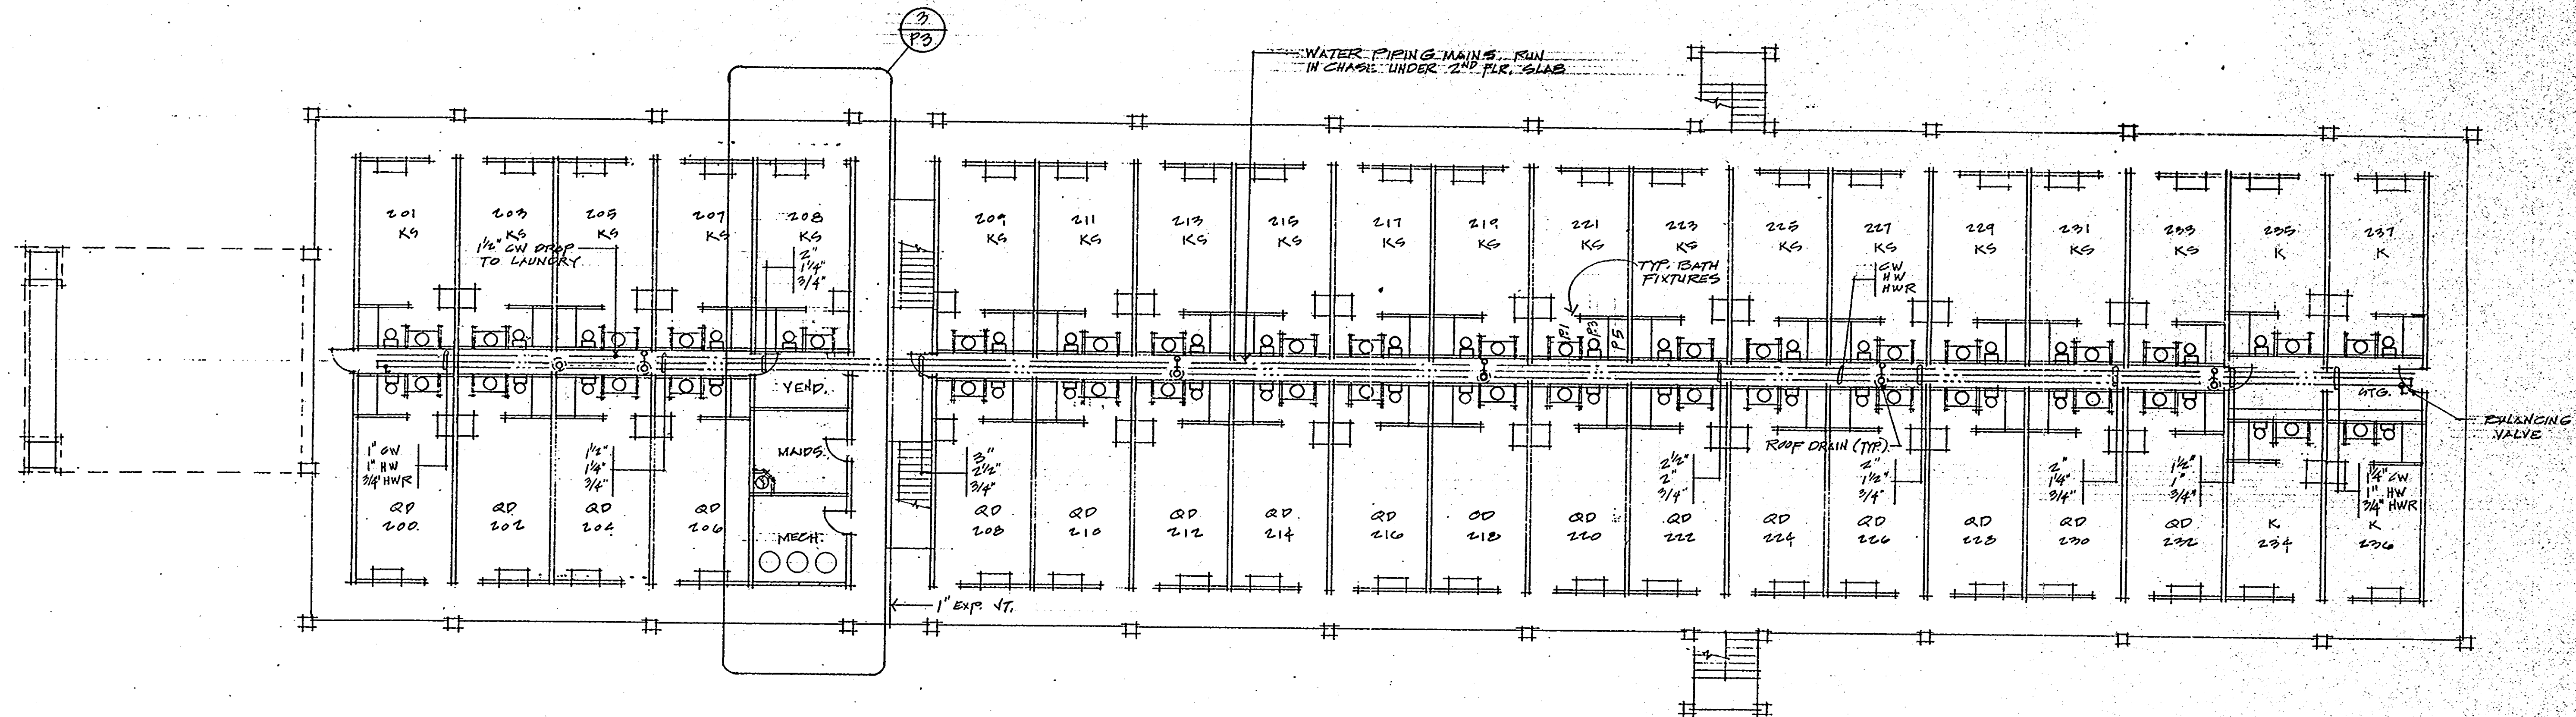



2ND FLOOR PLAN
3/32" = 1'-0"

REV. 3-27-93


HAMPTON INN MONROE, LA	DESIGN CONSORTIUM		
	HOTEL CONSULTANTS		
	MEMPHIS, TENNESSEE		
SECOND FLOOR PLUMBING PLAN	DATE	3-10-93	P-2
	SCALE		
	JOB NO.		

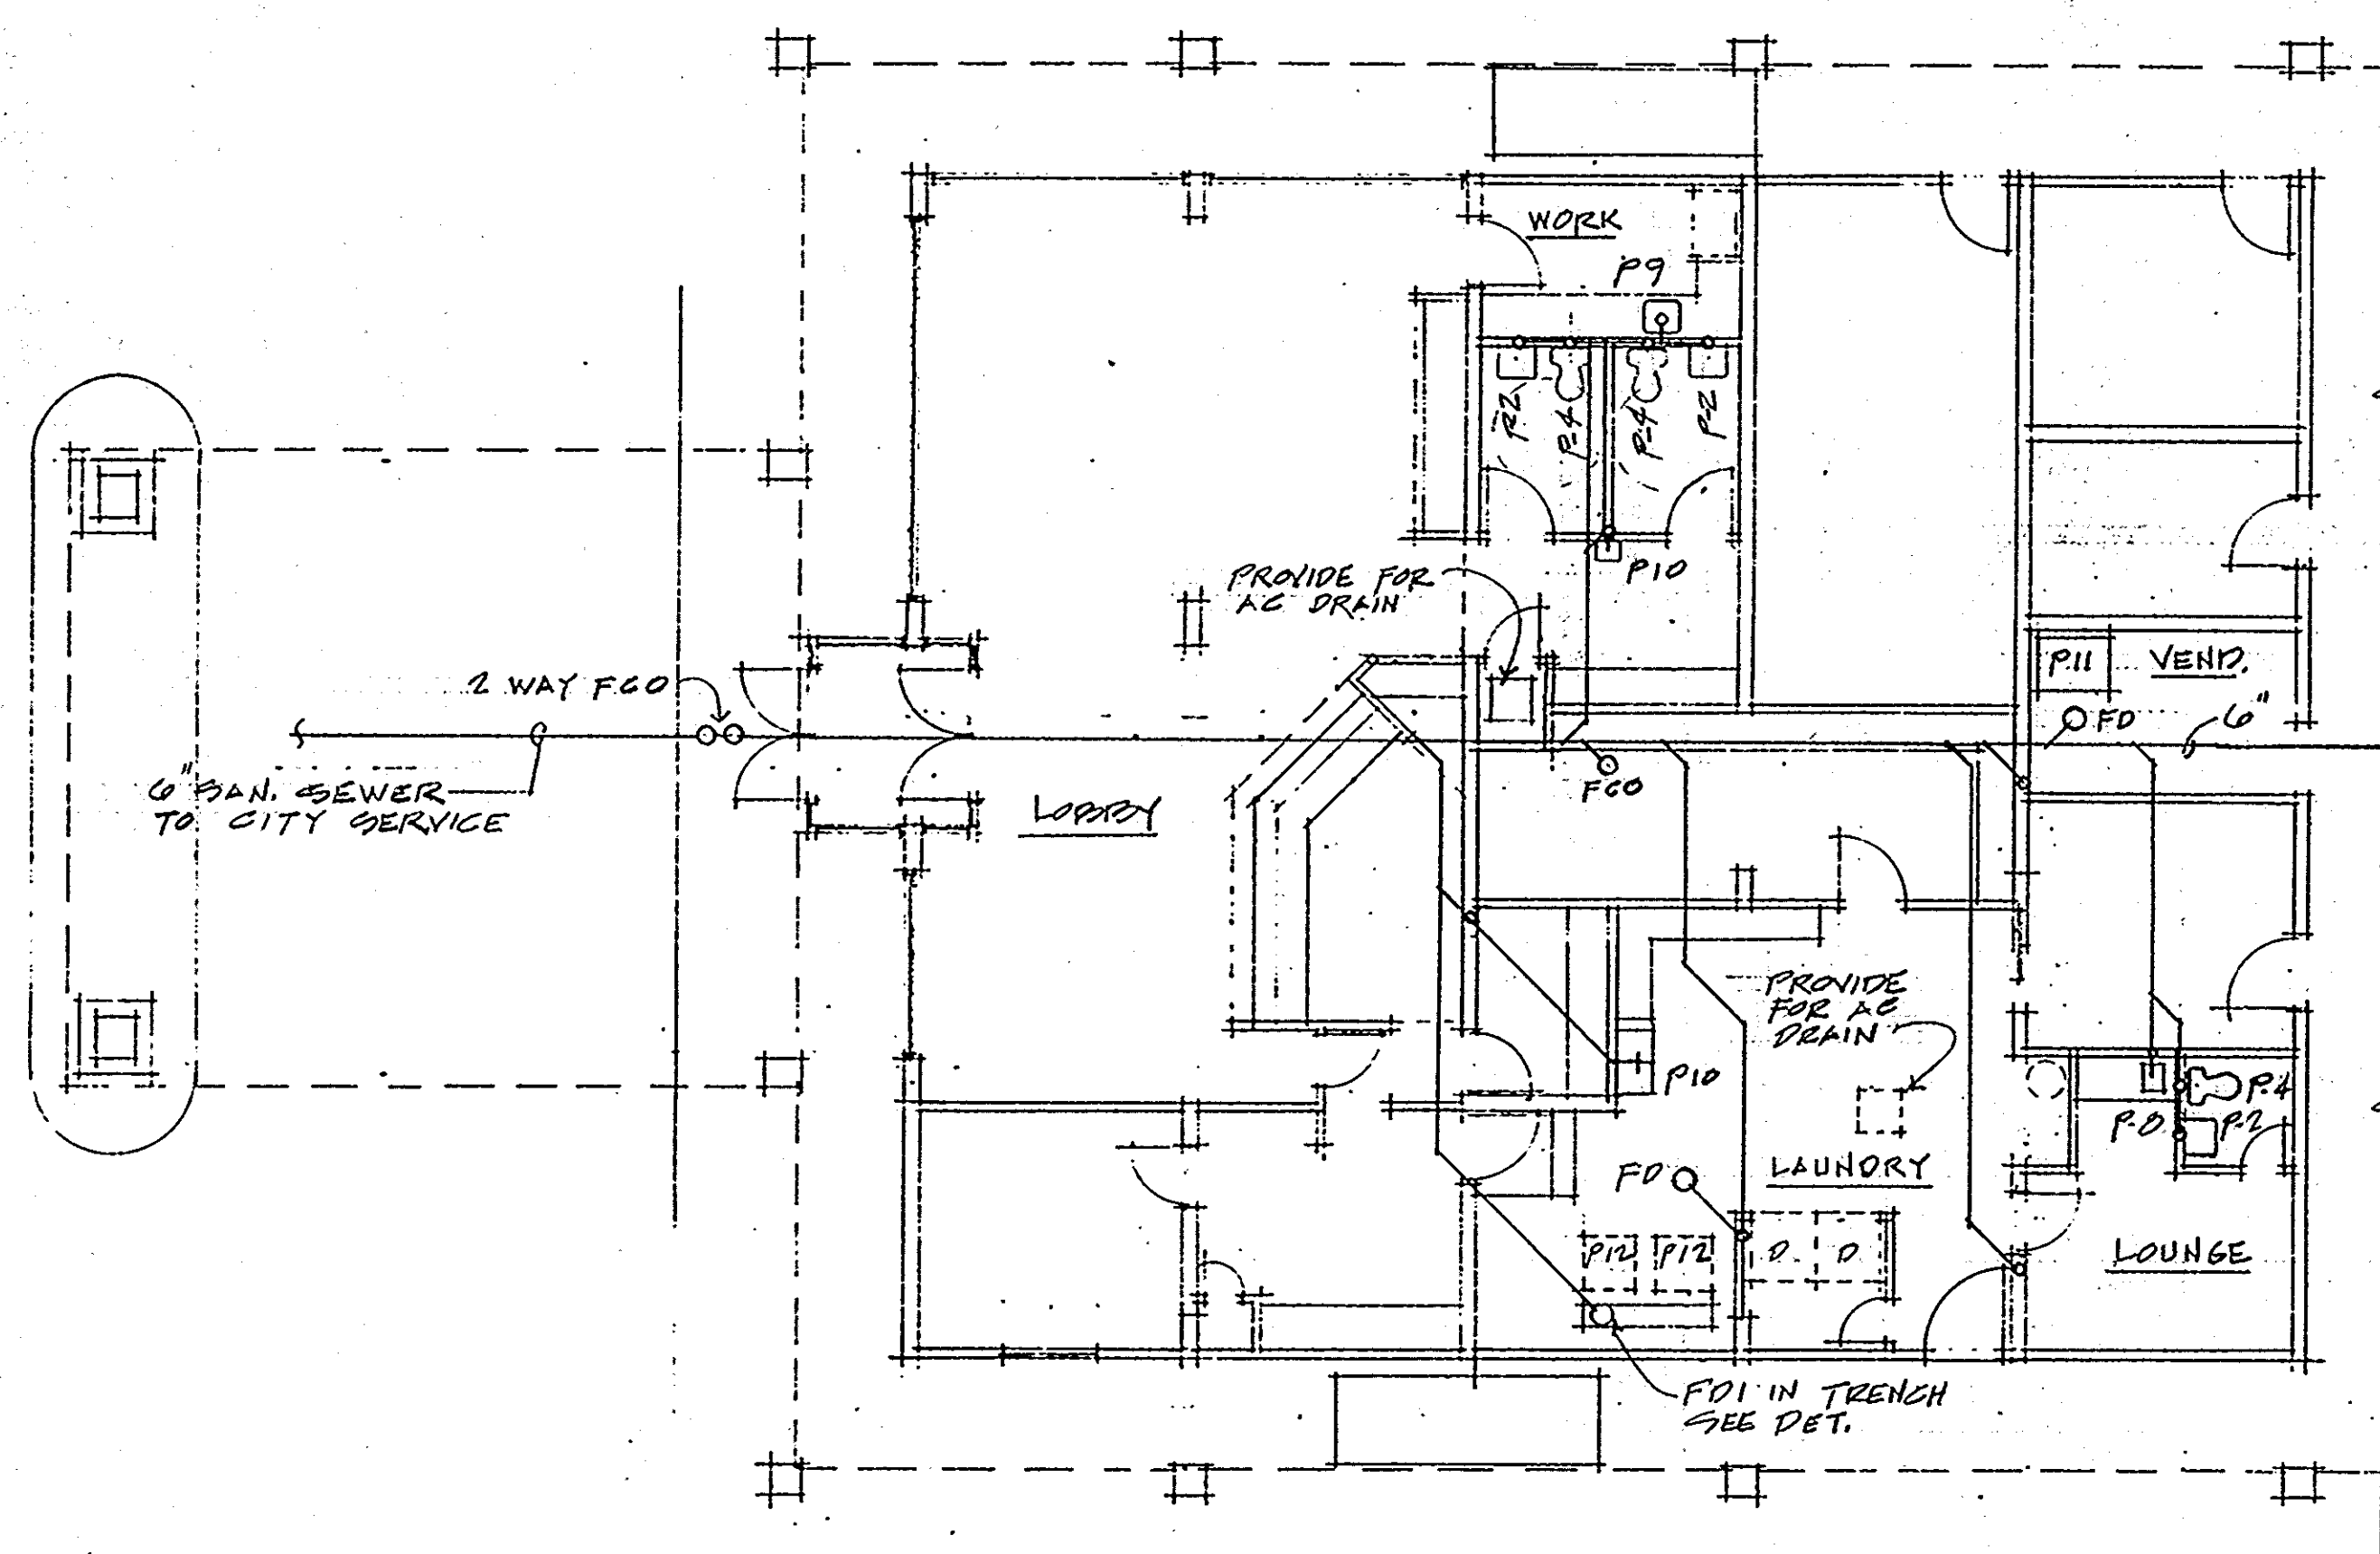

①
PART 1 GROUND
FLOOR PLANS
1/8" = 1'-0"





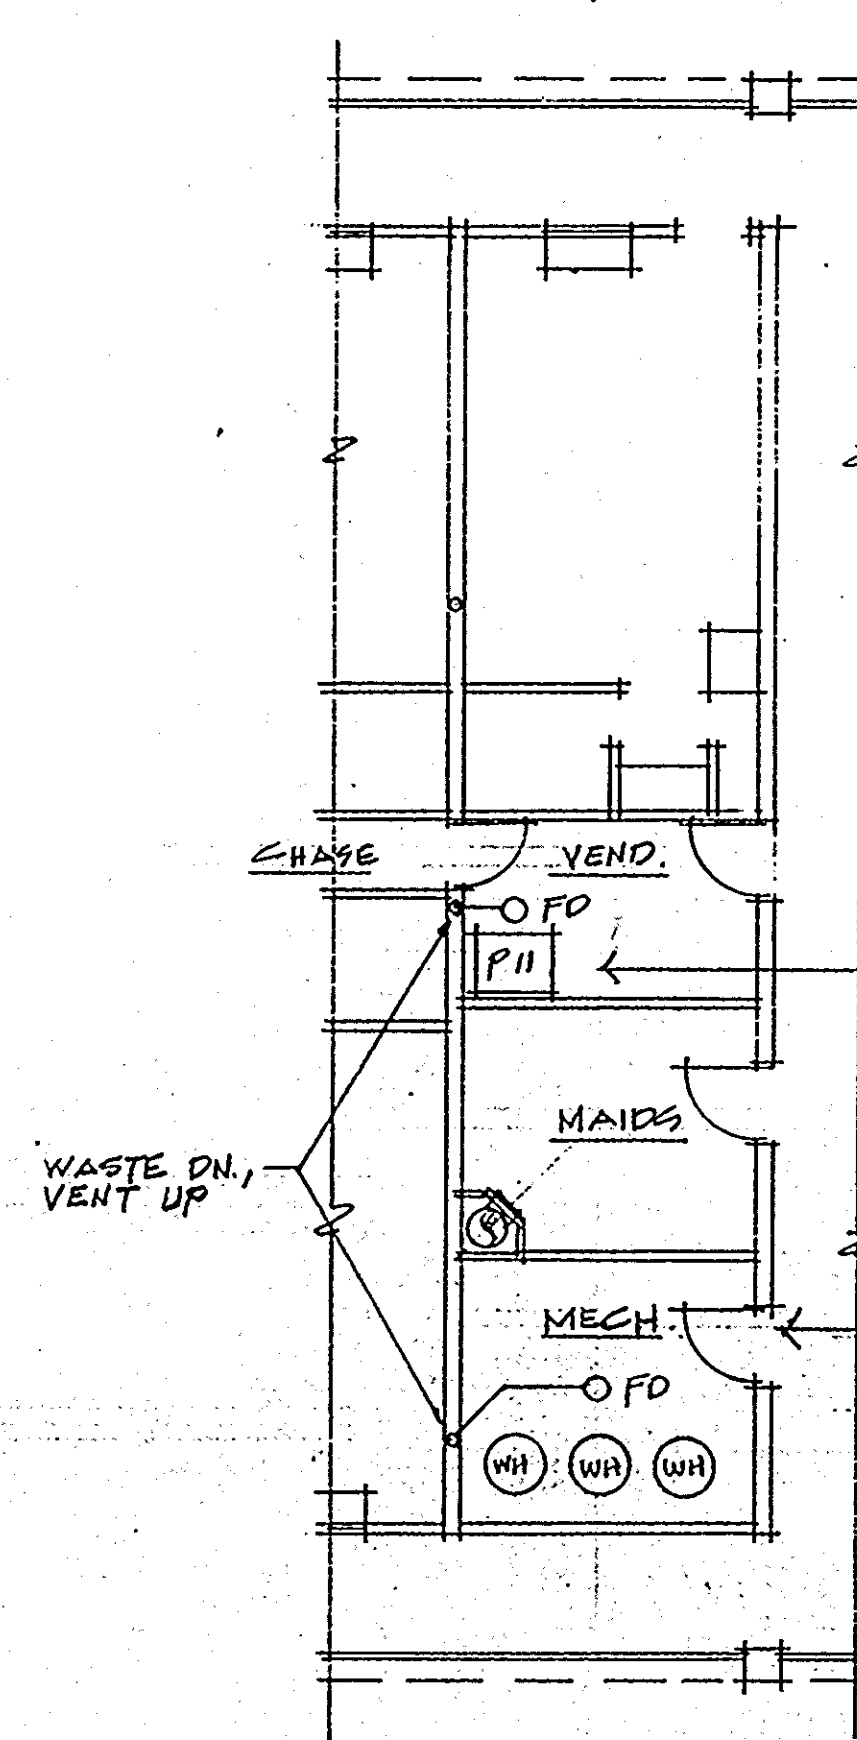
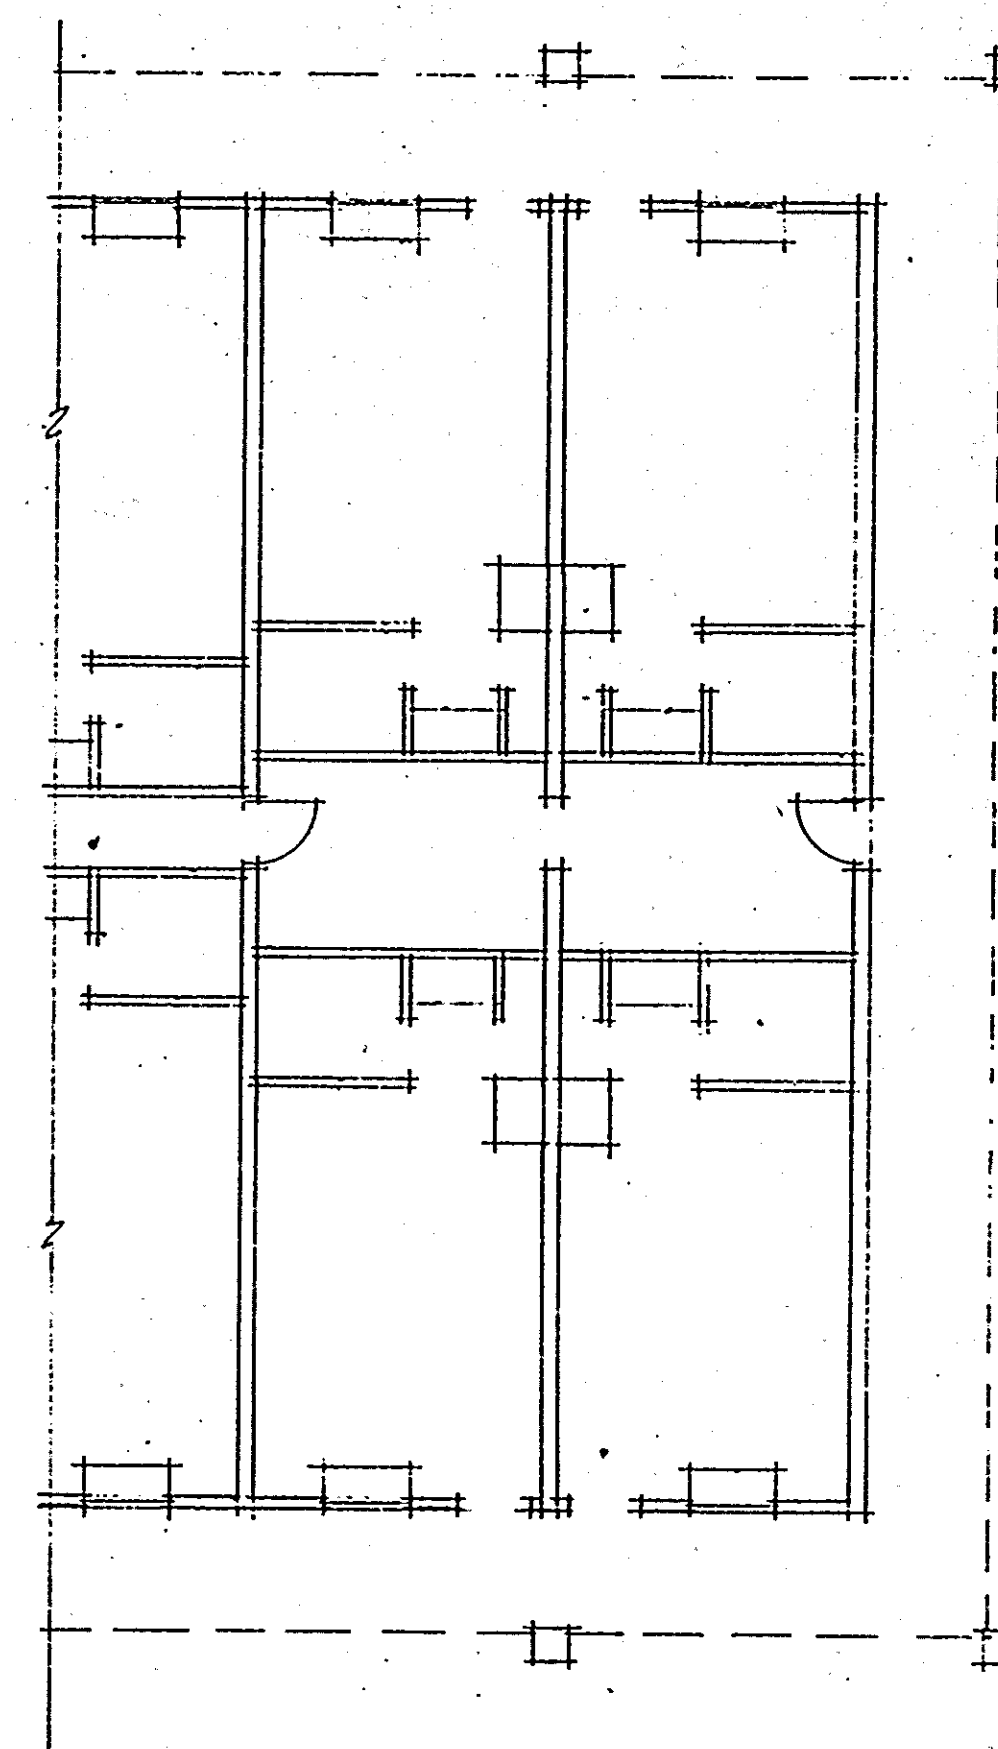


③
PART 3 SECOND
FLOOR PLANS
1/8" = 1'-0"

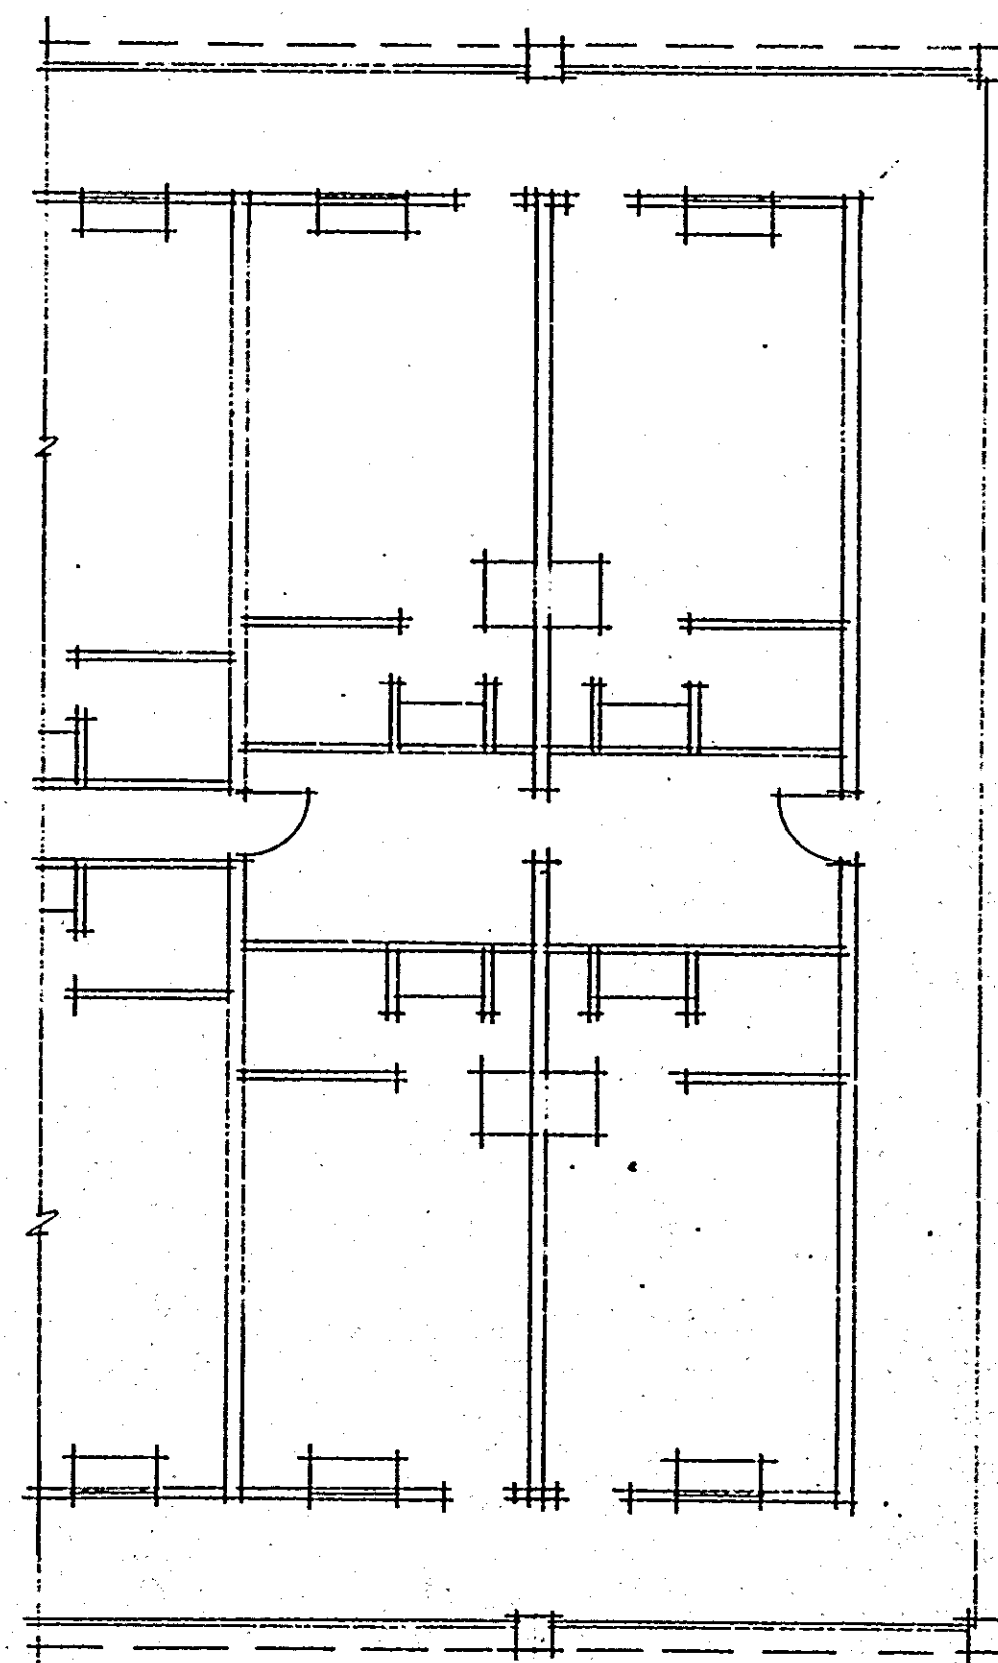

REV. 3-21-93


HAMPTON INN MONROE, LA		DESIGN CONSORTIUM HOTEL CONSULTANTS MEMPHIS, TENNESSEE	
COMMERCIAL / SERVICE AREA FLOOR PLANS	DATE	3-10-93	
	SCALE		
	JOB NO.		

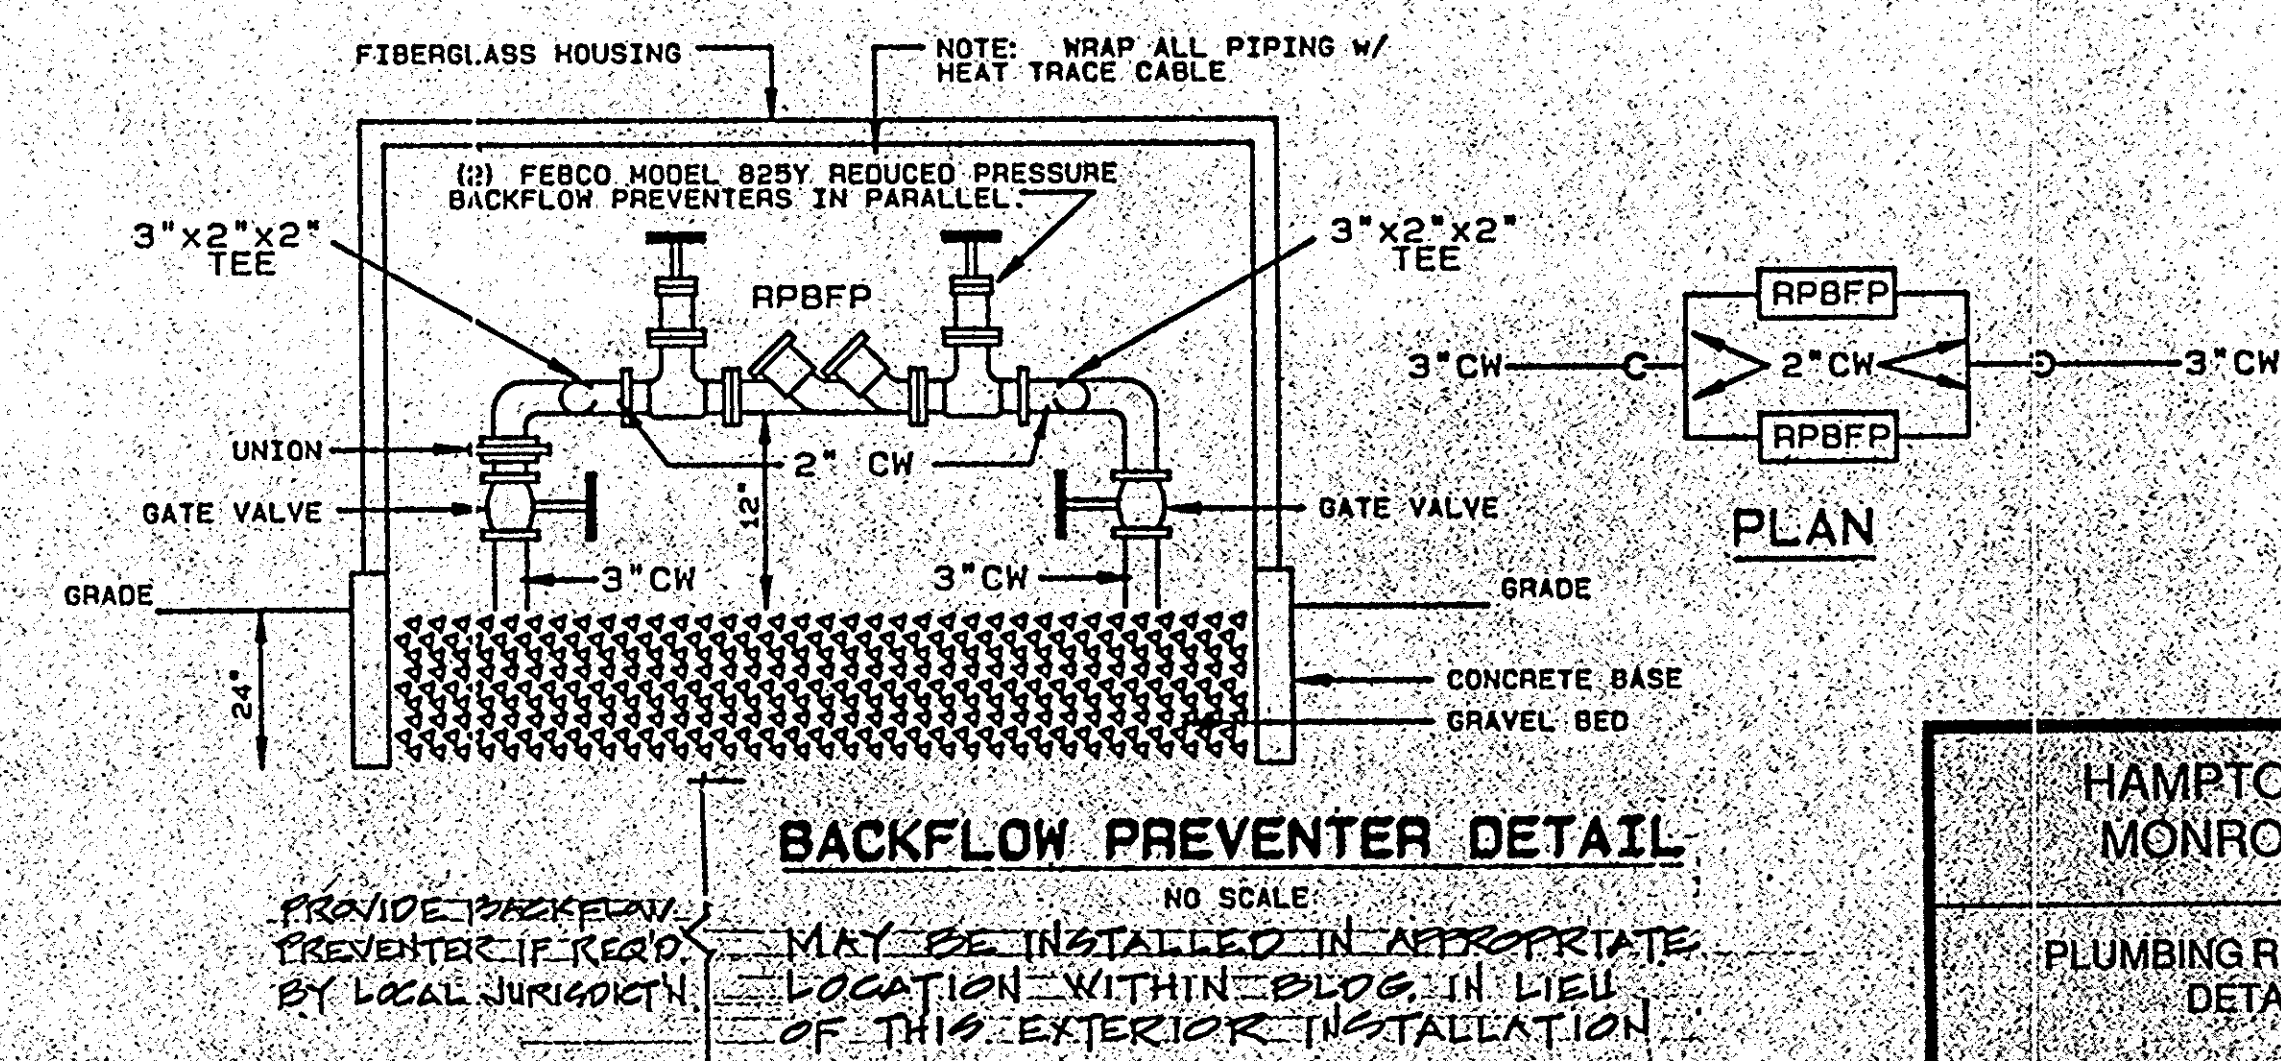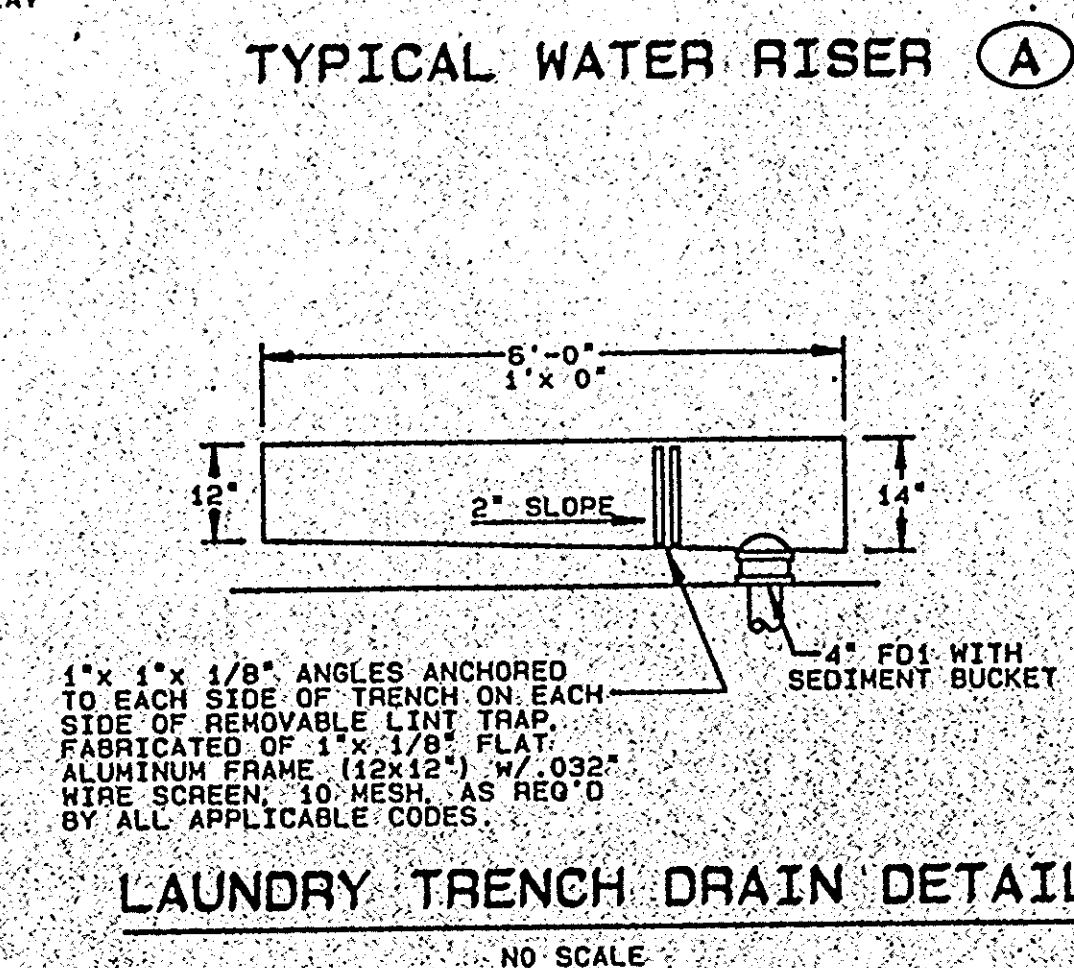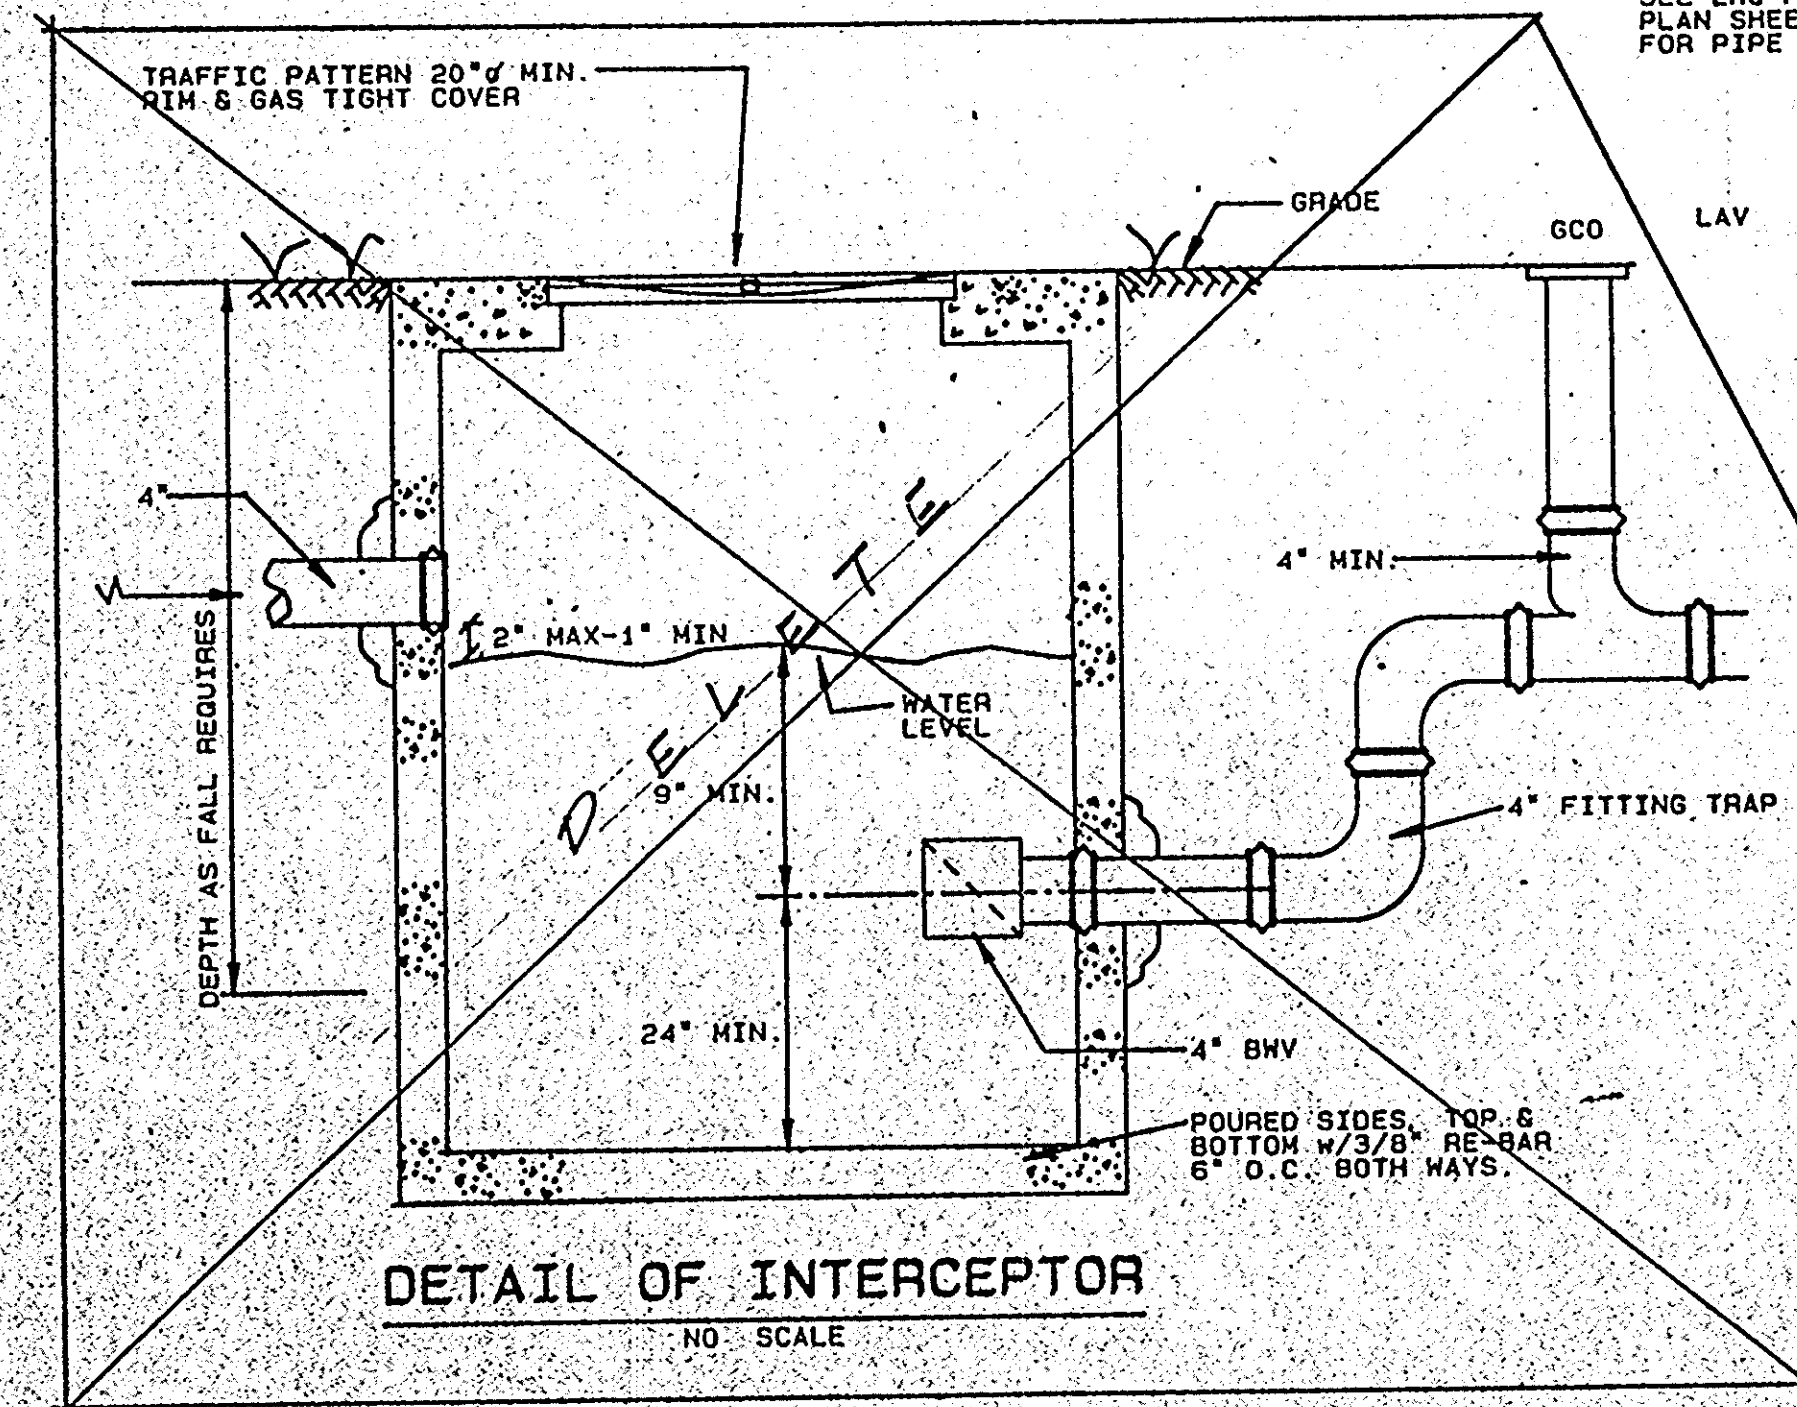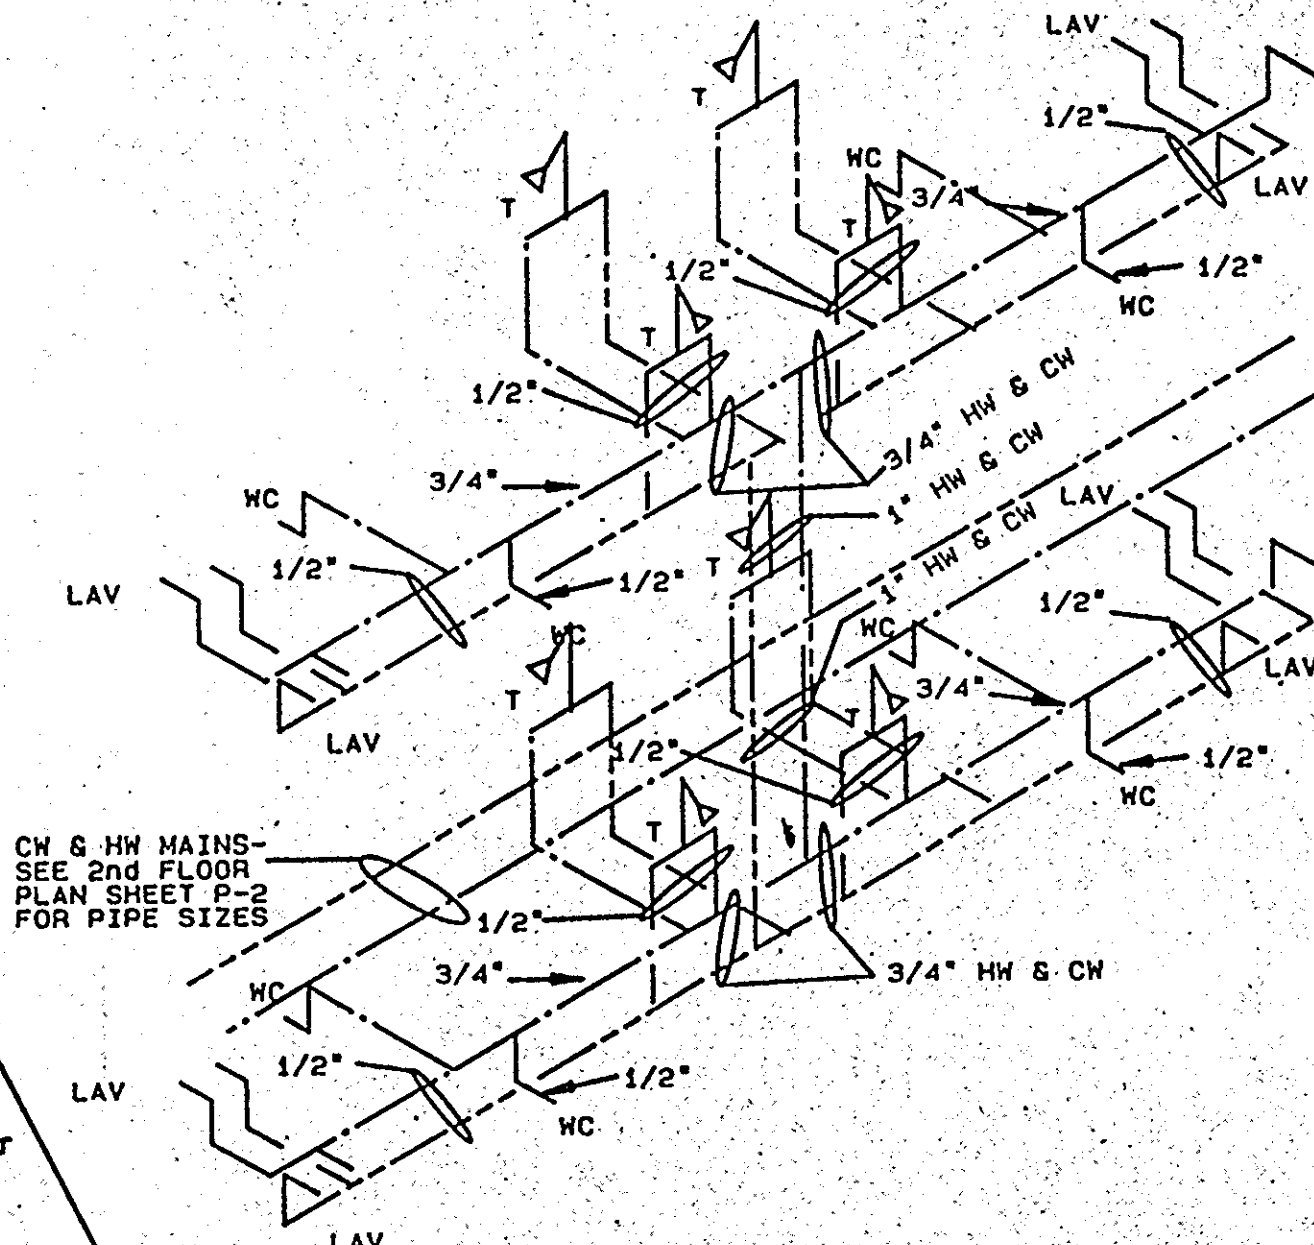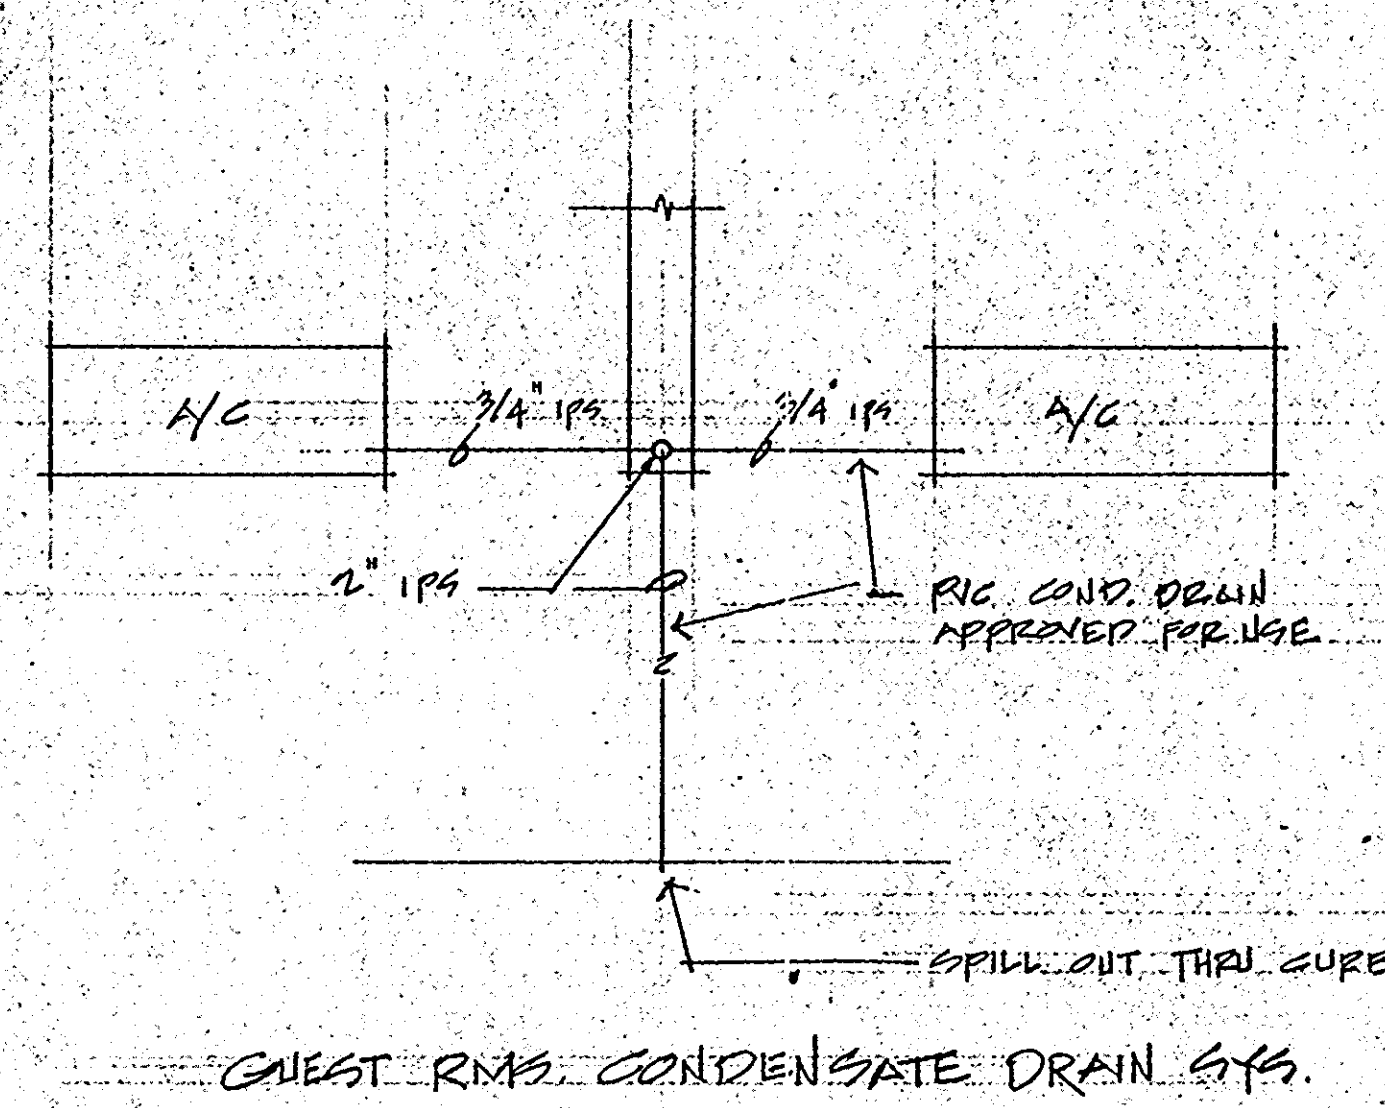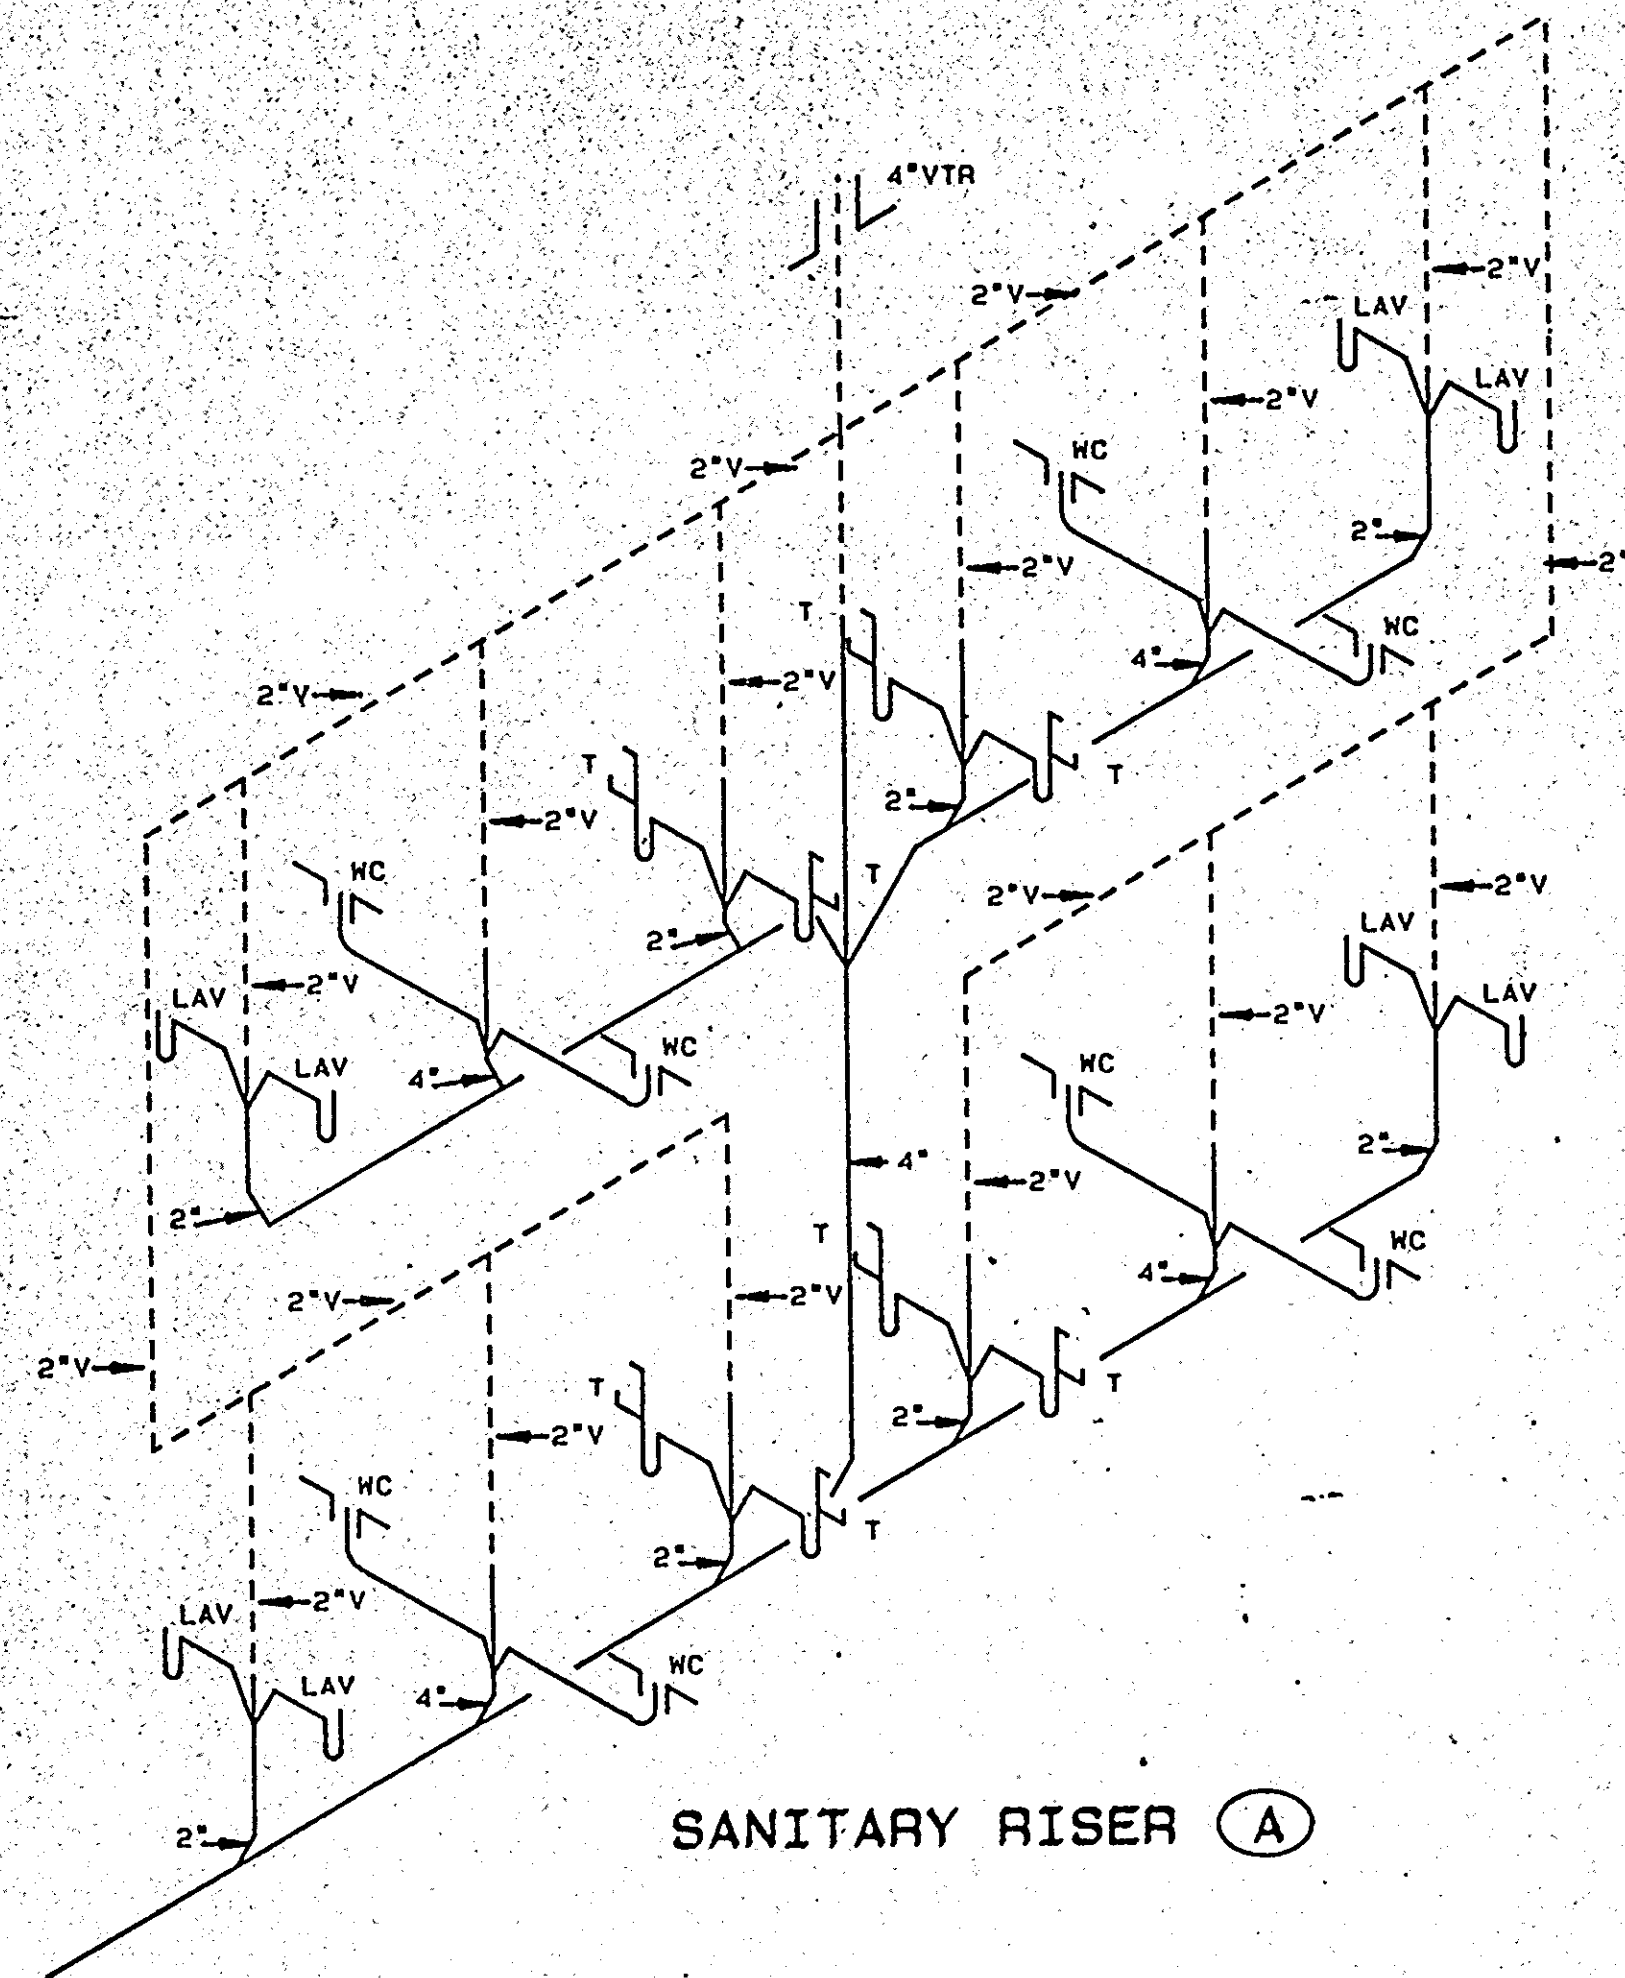

PLUMBING RISERS AND DETAILS	HAMPTON INN MONROE, LA		DESIGN CONSORTIUM HOTEL CONSULTANTS MEMPHIS, TENNESSEE	
	DATE	3-10-93	P-4	
	SCALE			
	JOB NO.			

PLUMBING LEGEND

SYMBOL	DESCRIPTION
-----	SOIL OR WASTE (S OR W)
-----	VENT (V)
-----	DOMESTIC COLD WATER (CW)
-----	DOMESTIC HOT WATER 110° (HW)
-----	DOMESTIC HOT WATER RETURN 110° (HWR)
-----	160° DOMESTIC HOT WATER (160° HW)
160°	SHUT-OFF VALVE
160°	CHECK VALVE
160°	UNION
FD	WADE SERIES W-1100-3" C.I. FL. DRAIN W/ 2" NICKEL BRONZE STRAINER W/ P-TRAP
FDI	WADE SERIES W-1100-4" C.I. FL. DRAIN W/ SEDIMENT BUCKET & TYPE "K" STRAINER W/ P-TRAP & INTEGRAL CLEANOUT

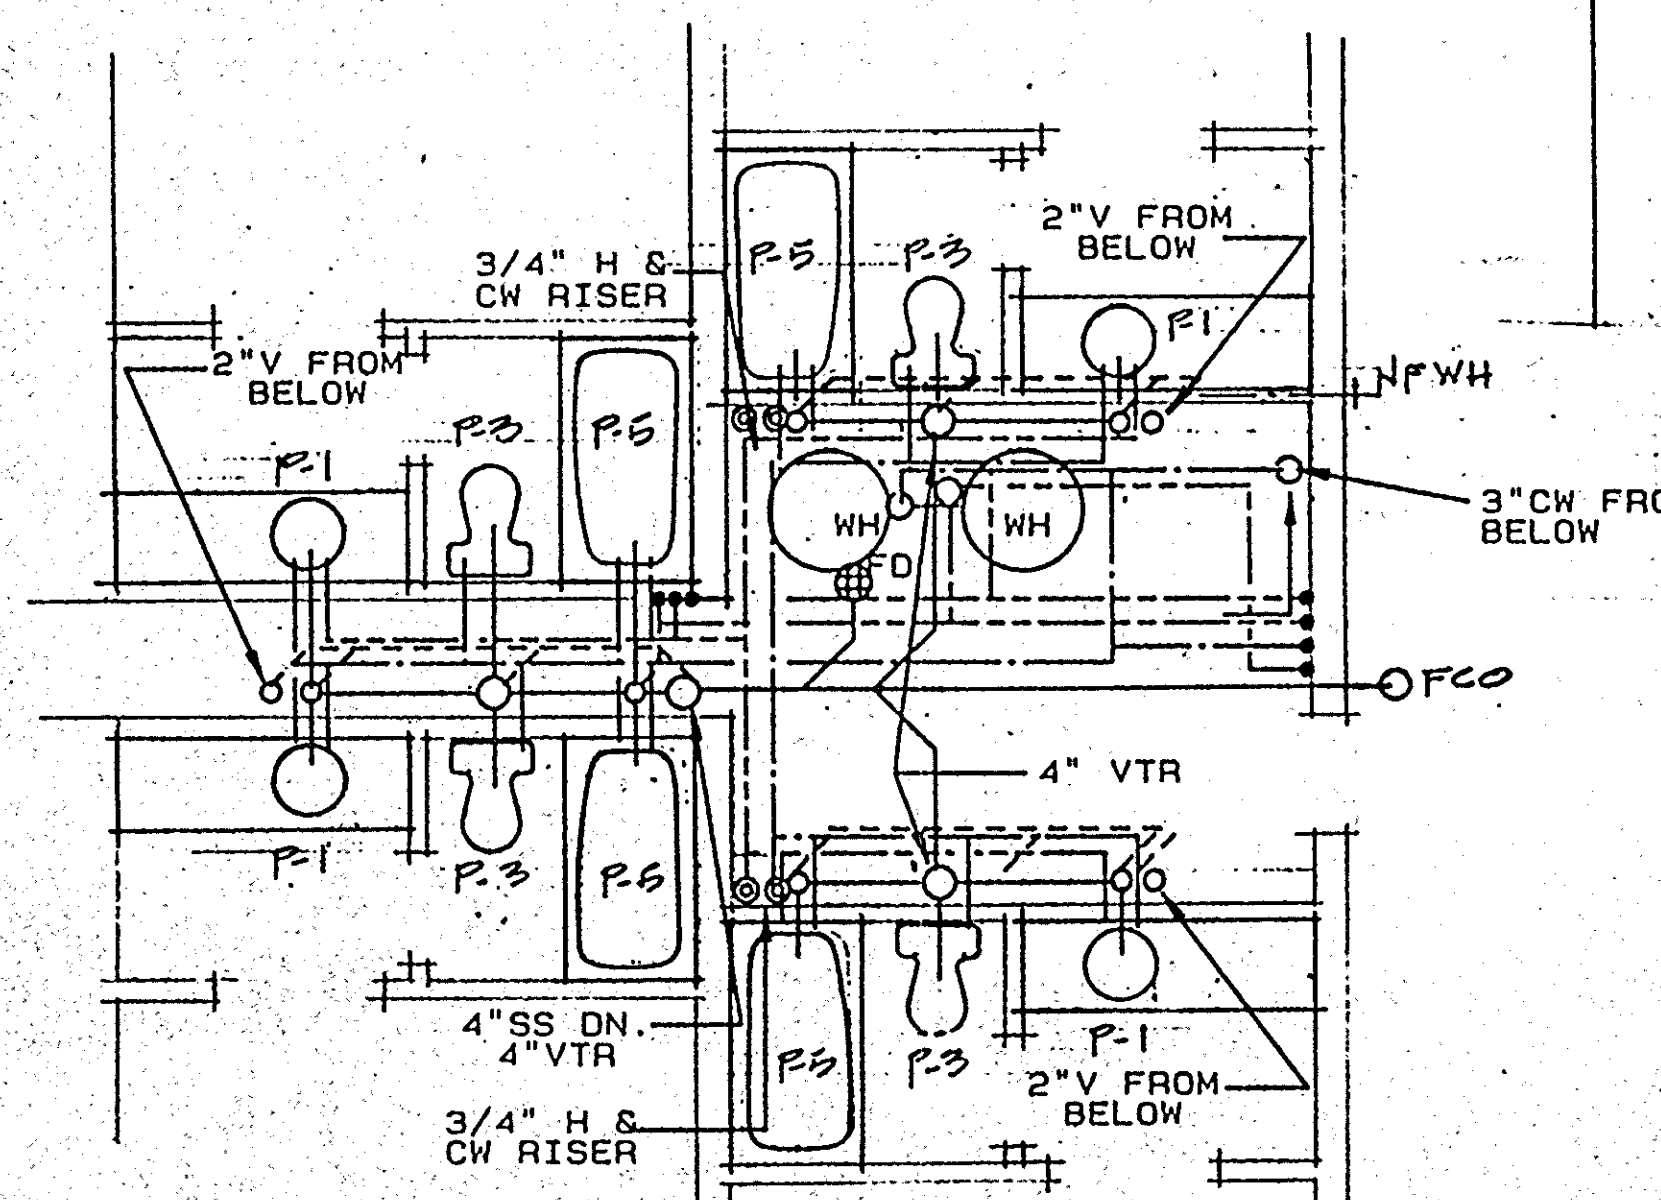

SECOND FLR. SINGLE SUITE AND MECH. ROOM PLANS

LEGEND (CONT'D)

FCO	WADE W-6030 C.I. FL. CLEANOUT W/ SECURED SCORATED COVER. PROVIDE LOCATOR IN CARPETED AREAS.
GCO	WADE W-6030-2 C.I. CLEANOUT W/ LOOSE DET. TRACTOR TOP SET IN 12x12x6" CONC. PAD.
WCO	WALL CLEANOUT
VTR	VENT THRU ROOF
NFWH	NON-FREEZE WALL HYDRANT

GENERAL NOTES


1. INSTALL MAIN WATER SHUTOFF VALVE IN RISER AFTER ENTERING THE BUILDING.
2. TRAPEZE HANGERS MAY BE USED WHEN GROUPING PIPES.
3. INSTALL UNIONS AT ALL CONNECTIONS TO WATER HEATER.
4. SET SLEEVES UNDER DIRECTION OF GENERAL CONTRACTOR.
5. PIPING LAYOUT IS ONLY SCHEMATIC. EXACT LOCATION OF PIPES TO BE COORDINATED WITH BUILDING STRUCTURE AND WORK OF OTHER CONTRACTORS.
6. CONCEAL PIPING WHEREVER POSSIBLE.
7. PROVIDE HEAT TRACE CABLE ON ALL WATER PIPE IN EXTERIOR WALLS & EXTERIOR CHASES W/ THERMOSTATIC CONTROL.
8. RUN ALL WATER LINES LEVEL.
9. SUPPORT ALL SANITARY AND WASTE PIPING NOT IN EARTH, ON 5 FT. CENTERS; ALL STEEL PIPING ON 10 FT. CENTERS; COPPER PIPING ON 8 FT. CENTERS.
10. ALL FIXTURES TO BE EQUIPPED WITH STOP VALVES IN ACCESSIBLE LOCATIONS.
11. ROUGH IN ALL PIPING THRU FACE OF WALL WHERE POSSIBLE, EXCEPT IN OUTSIDE WALLS.
12. WORK SHALL BE INSTALLED IN ACCORDANCE WITH ALL STATE AND LOCAL AUTHORITIES HAVING JURISDICTION.
13. SHOCKS STOPS AS MANUFACTURED BY WADE SHALL BE FURNISHED AND INSTALLED BY THE PLUMBING CONTRACTOR ON ALL WATER RISERS ACCORDING TO MANUFACTURER'S RECOMMENDATIONS OR EQUAL OF 18" RISERS AT EACH HOT AND COLD WATER RISER.
14. PROVIDE SHUTOFF VALVE FOR EVERY GUEST RM.
15. PROVIDE CONDENSATE DRAIN SYSTEM FOR HC UNITS. SEE DET.

PLUMBING FIXTURE, DRAIN & CLEANOUT SCHEDULE


SYMBOL	FIXTURE	MANUF/ MODEL	BRASS	TRAP	SUPPLY	DESCRIPTION
P-1	LAVATORY	WENOR COUNRTOP W/ INTEGRAL BOWL	DELTA 524 MPU	1-1/4" CP	3/8"	INTEGRAL COUNTERTOP & BOWL W/FRONT OVERFLOW, FURNISH POP-UP ASSEMBLY, 1-1/4" TAILPIECE, SUPPLIES, STOPS AND ESCUTCHEONS.
P-2	LAVATORY	AMERICAN STANDARD	SYMMONS 6-90-1	1-1/4" CP	3/8"	0.5551012 20x12" VITREOUS CHINA WALL HUNG W/W-520 CONCEALED ARM LAV CARRIER
P-3	WATER CLOSET	PRICCO 4718	BRASS CRAFT	4"	3/8"	WHITE VITREOUS CHINA ELONGATED SIPHON-JET BOTTOM OUTLET WATER CLOSET. OPEN FRONT SOLID PLASTIC SEAT W/ LID, SUPPLY, STOP AND ESCUTCHEONS.
P-4	H.C. WATER CLOSET	PRICCO 4718	BRASS CRAFT	4"	3/8"	HANDICAPPED SIPHON-JET WATER CLOSET. OPEN FRONT SOLID PLASTIC SEAT, SUPPLY, STOP AND ESCUTCHEONS.
P-5	BATH TUB & SHOWER	ELJER 013-0325 013-0320	SYMMONS S96-2-X	1-1/2"	1/2"	WHITE-ENAMELED CAST IRON TUB/SHOWER UNIT. W/DIVERTER SPOUT, 515-0100 POP-UP WASTE/OVERFLOW, SCREWDRIVER STOPS, 36PM WATER PIX HEAD ESCUTCHEONS.
P-6	HANDI-CAP BATH TUB & SHOWER	ELJER 013-0325 013-0320	SYMMONS S96-400-V-8-24-X	1-1/2"	1/2"	SAME TUB ABOVE EXCEPT WITH FBA-035 FLEXIBLE SHOWER HOSE ASSEMBLY W/ ADJUSTABLE HAND SPRAY & WALL BRACKET.
P-7	LAUNDRY SINK	JUST NSF8-290	JS48TA-1	1-1/2"	1/2"	2-COMPARTMENT STAINLESS STEEL LAUNDRY TUB SINK W/ STAND, STRAINERS, SUPPLIES, STOPS & ESCUTCHEONS. 1/2" VENT.
P-8	2-COMPART SINK	ELKAY	L.K.	1-1/2" CP	1/2"	PCH-15-C ST. STL. SINK W/ LK FAUCET
P-9	KITCHEN SINK	ELKAY	L.K.	1-1/2" CP	1/2"	SINGLE ST. STL. SINK W/ GARBAGE DISPOSAL UNIT AS SEL. BY OWNER
P-10	ELECTRIC DRINKING FOUNTAIN	HALSEY TAYLOR BFC7F		1-1/4"	3/8"	WALL HUNG ELECTRIC DRINKING FOUNTAIN WATER COOLER WITH SPOUT MOUNTED AT 36" ABOVE FINISHED FLOOR.
P-11	ICE MACHINE (REF. OVER)				1/2"	ICE MACHINE FURNISHED BY OWNER, INSTALLED BY PLUMBS. CONTR., VERIFY SUPPLY W/ OWNER. 2" INDIRECT WASTE.
P-12	WASHING MACHINE				AS REQ'D	COMMERCIAL WASHER/EXTRACTOR FURNISHED BY OWNER, INSTALLED BY CONTR. PER VENDOR RECOMMENDATIONS.
P-13	H.C. ROLL-IN SHOWER					TRIM SAME AS P-6

SEAT - DEMIG #1990 WHITE

SNIP. RESISTANT BOTTOM

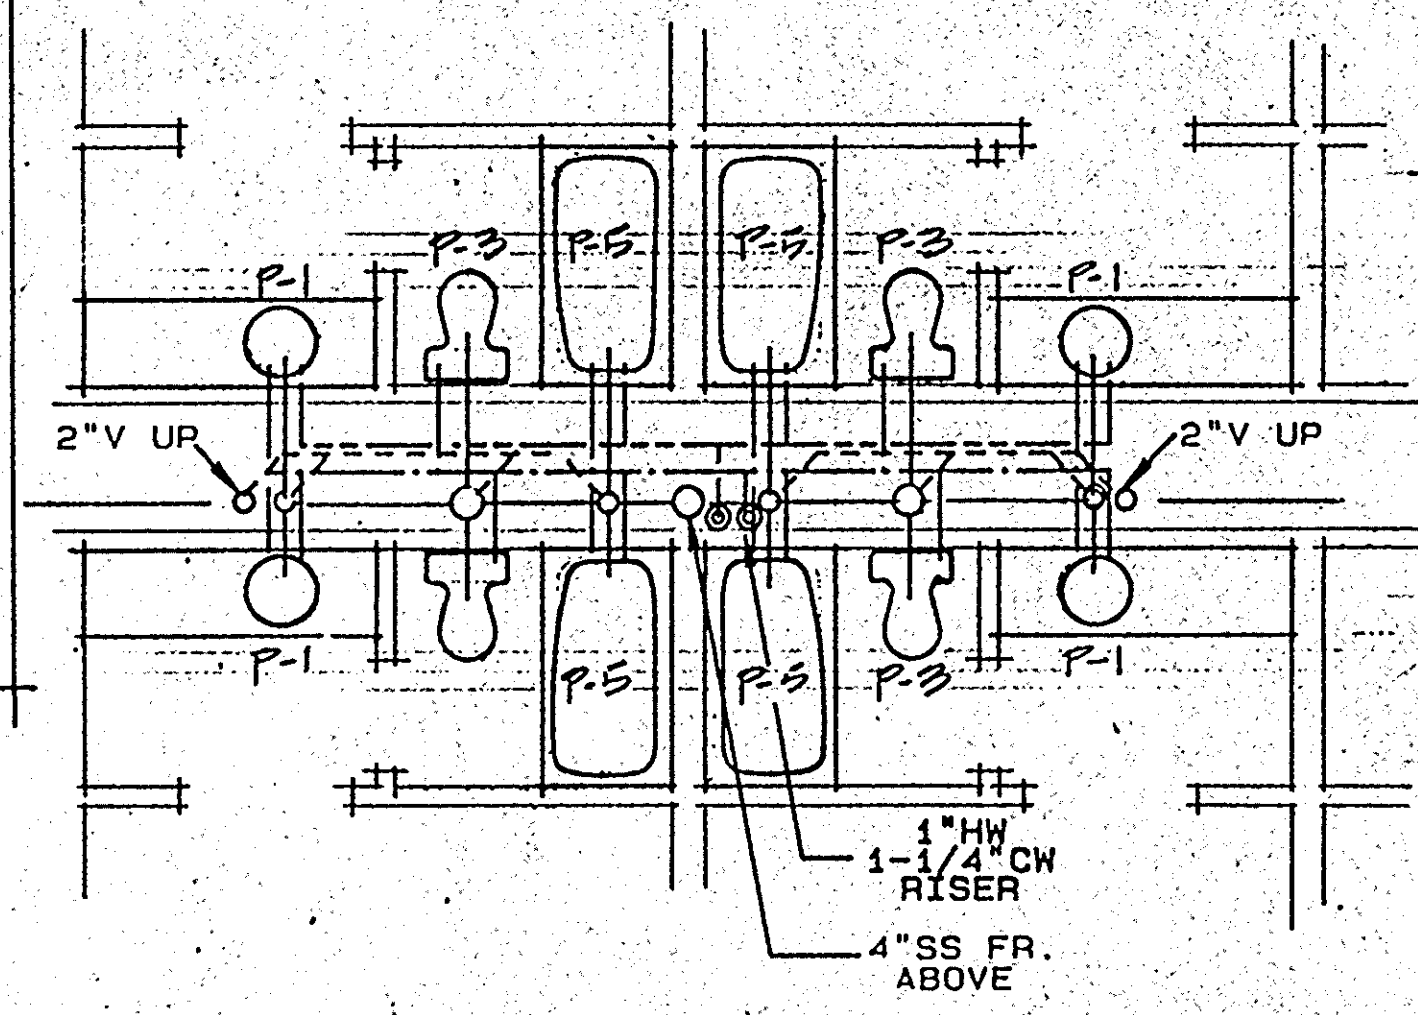

TYPICAL 1st FLR. KING & DOUBLE BACK-BACK SUITES

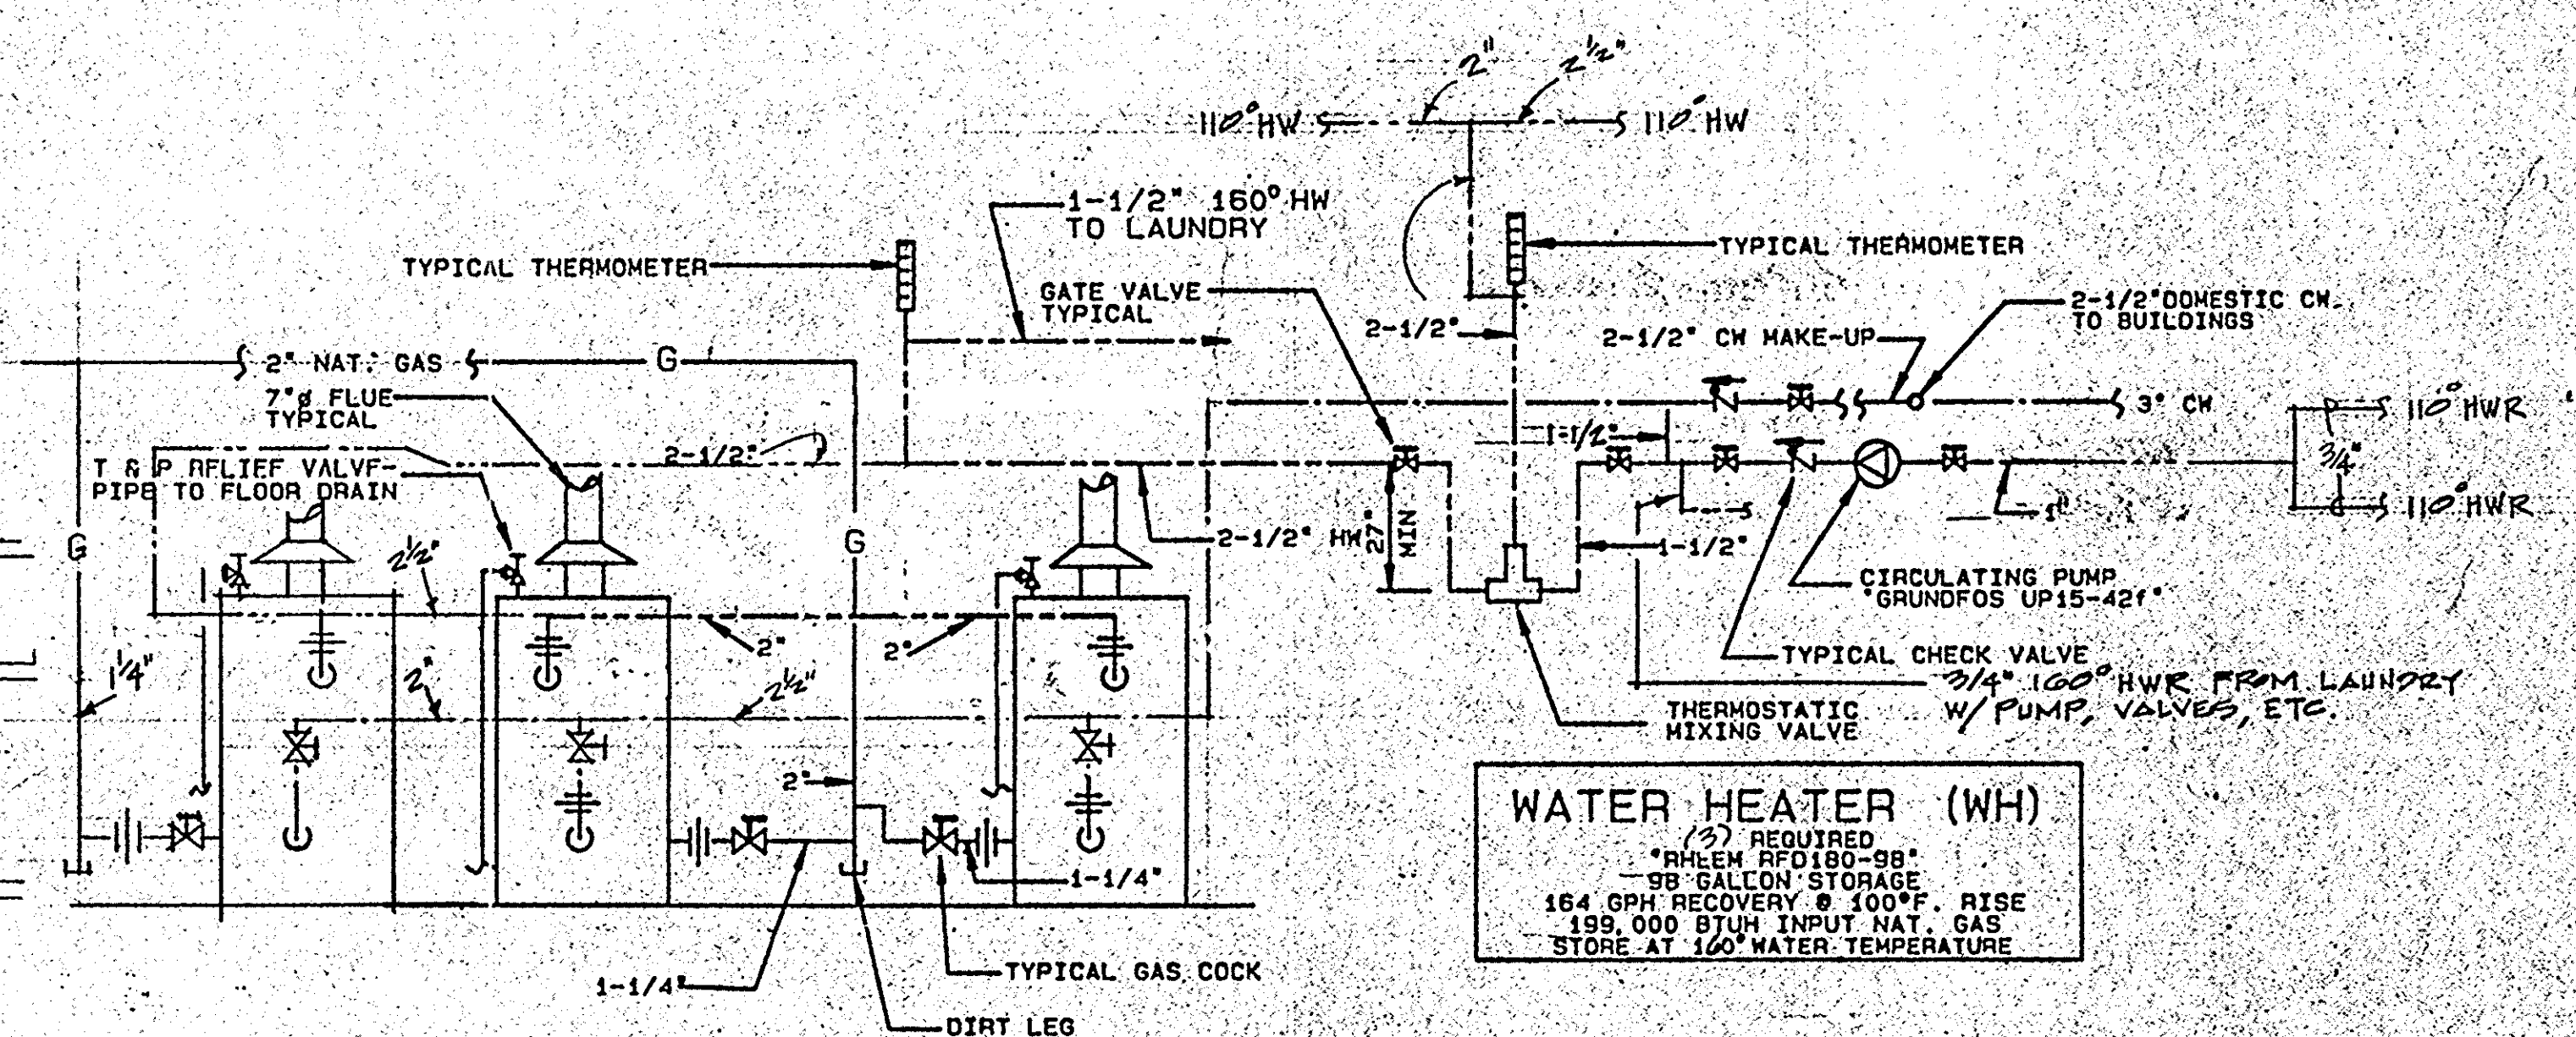


WATER HEATER (WH) DETAIL

LARGE SCALE PLUMBING PLANS


SCALE: 1/4" = 1'-0" SMALL SCALE FLOOR PLANS & TYP. ARCH. RM. PLUMB. GOVERN

HAMPTON INN MONROE, LA	DESIGN CONSORTIUM		
	HOTEL CONSULTANTS MEMPHIS, TENNESSEE		
	DATE	3.10.93	P-5
	SCALE		
PLUMBING SCHEDULES AND DETAILS	JOB NO.		

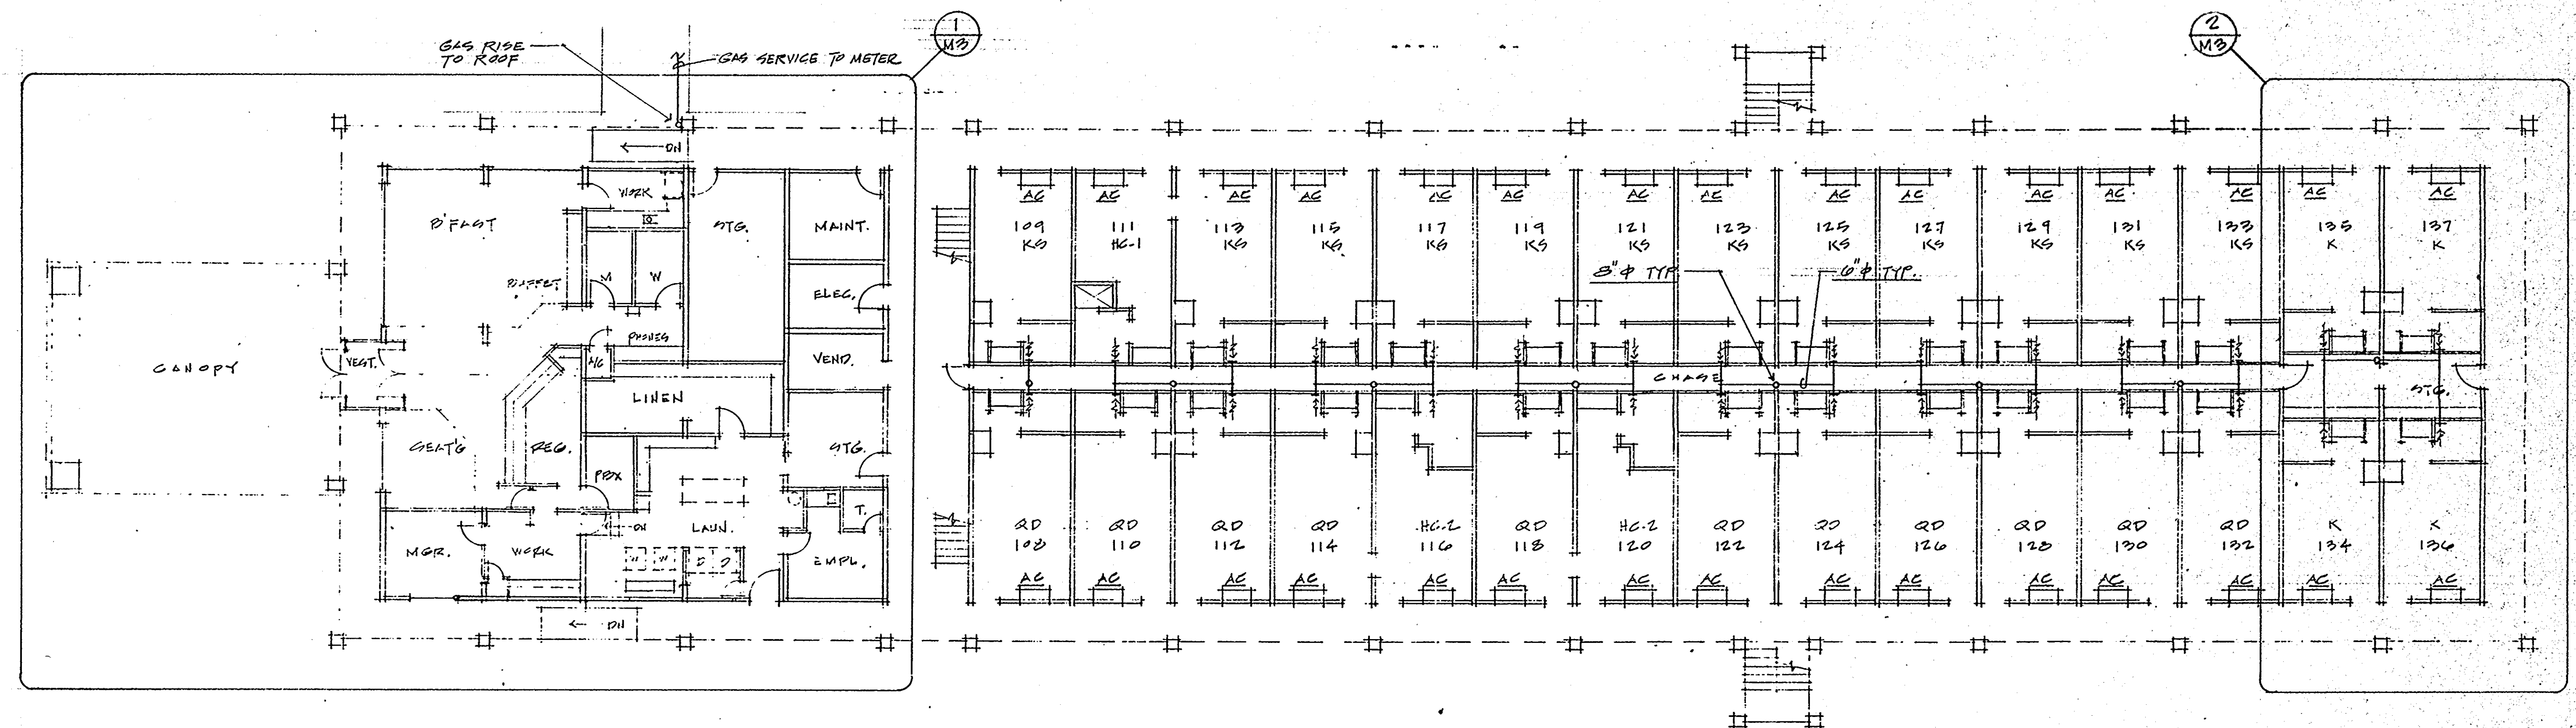


GROUND FLOOR PLAN
3/32" = 1'-0"

HAMPTON INN MONROE, LA	DESIGN CONSORTIUM HOTEL CONSULTANTS MEMPHIS, TENNESSEE		
GROUND FLOOR MECHANICAL PLAN	DATE	3-10-73	M-1
	SCALE		
	JOB NO.		

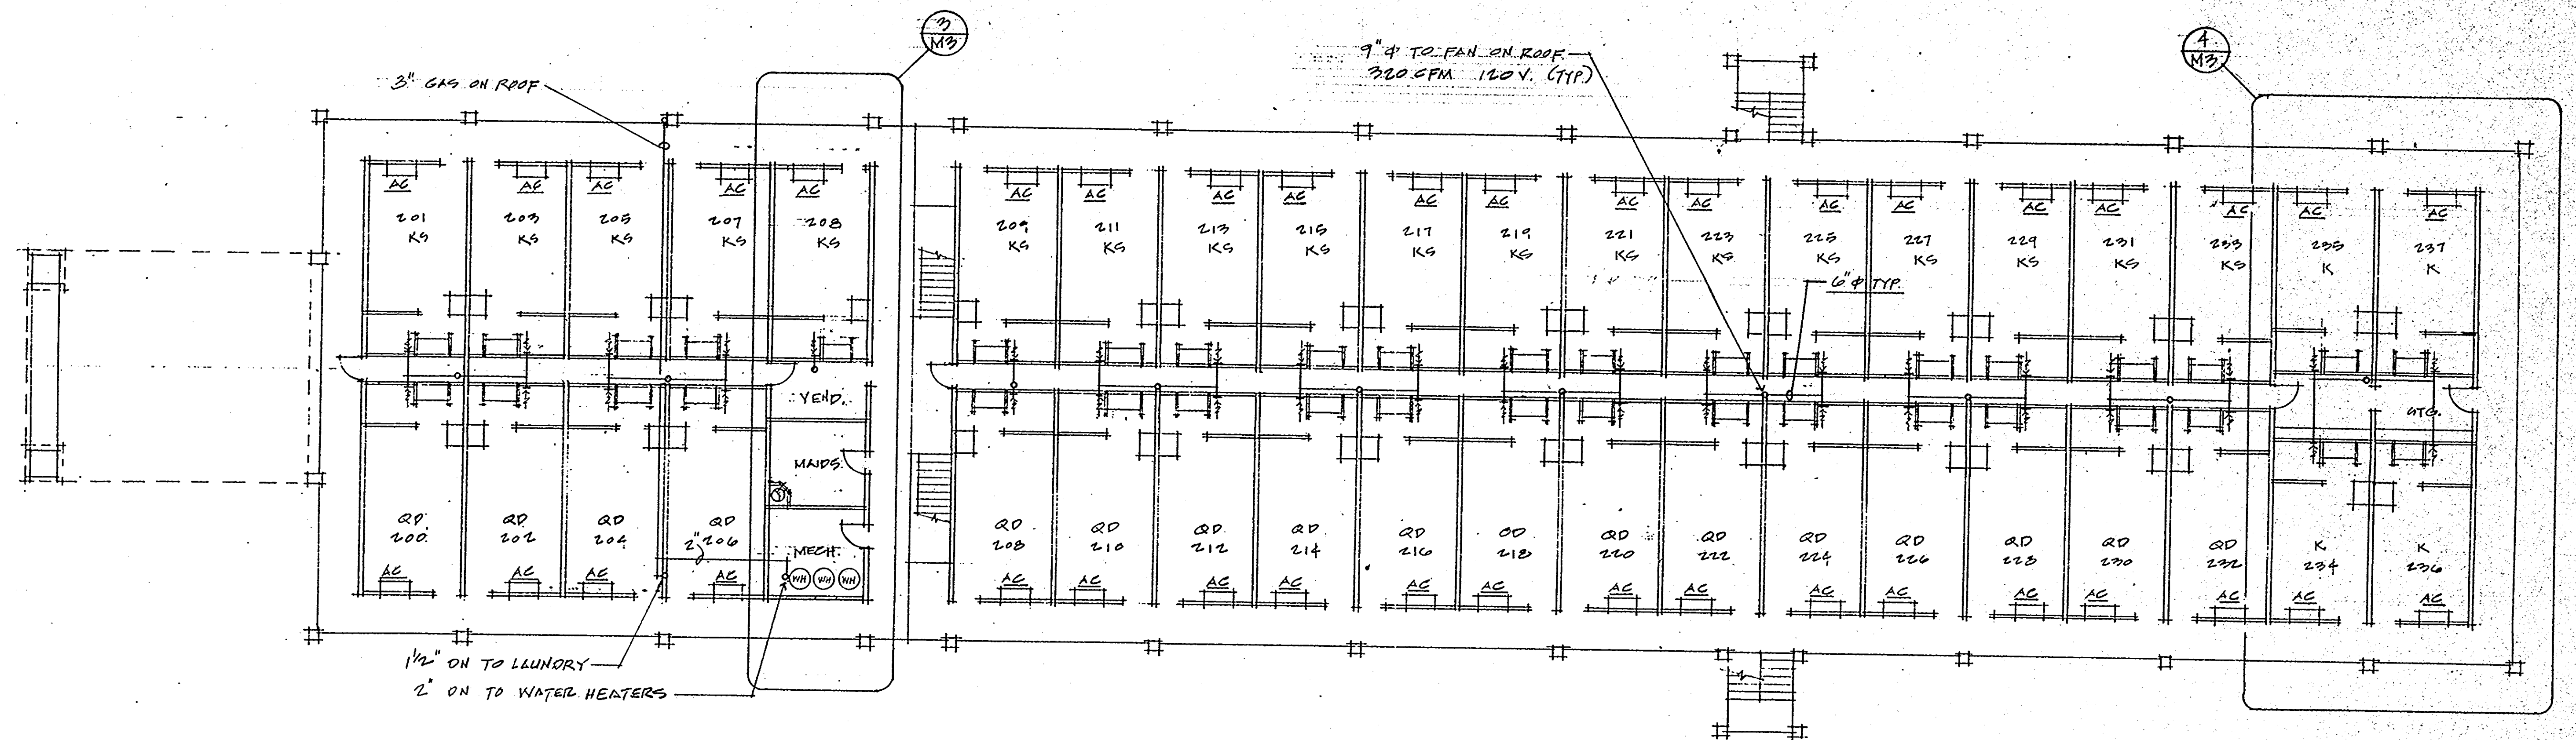


2ND FLOOR PLAN
3/32" = 1'-0"

HAMPTON INN MONROE, LA	DESIGN CONSORTIUM		
	HOTEL CONSULTANTS		
	MEMPHIS, TENNESSEE		
	DATE	3-10-93	
SECOND FLOOR MECHANICAL PLAN	SCALE		
	JOB NO.		
			M-2

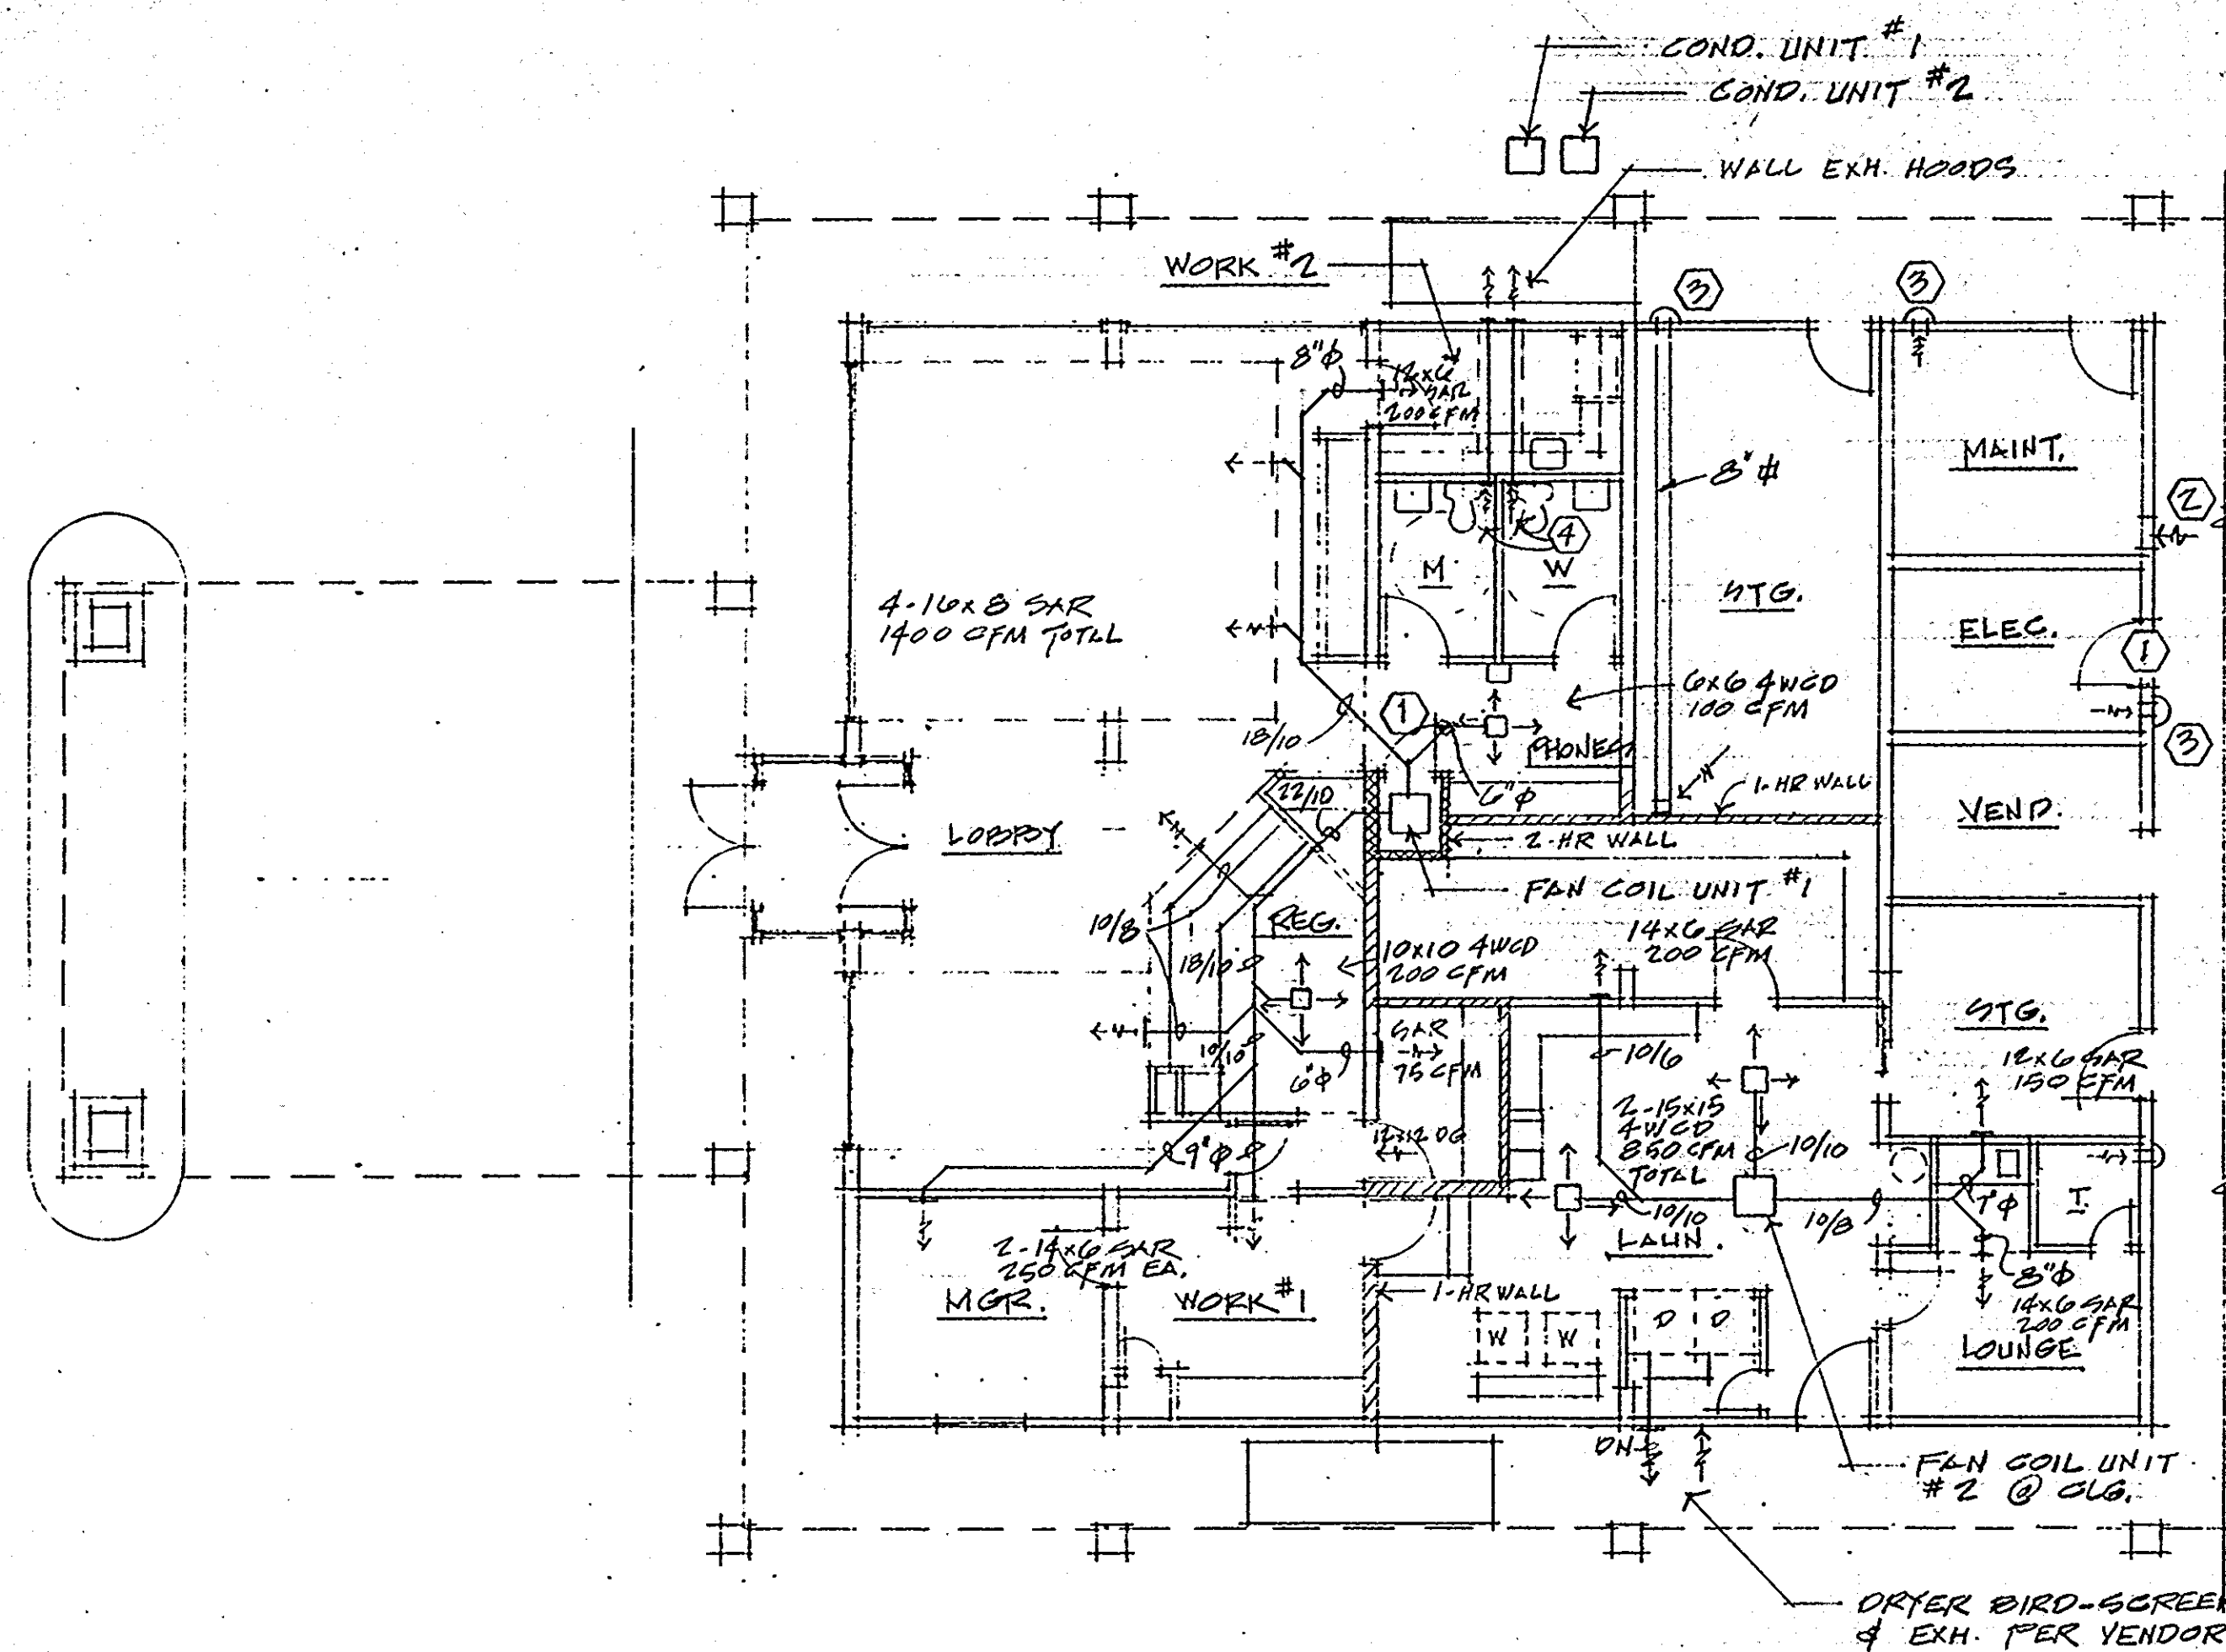

1. PART I. GROUND FLOOR PLANS
1/8" = 1'-0"

- ① FULL LOWER DOOR
- ② THERMOSTICALLY CONTROLLED INTAKE AIR LOUVER
- ③ EXH. FAN W/ THERMOSTAT. ENERGIZE @ 30°F. 150 CFM @ 2.10" S.P. 120 VOLTS.
- ④ BROWN, NUTONE OR EQ. WALL MTD. EXHAUST @ 100 CFM EA.

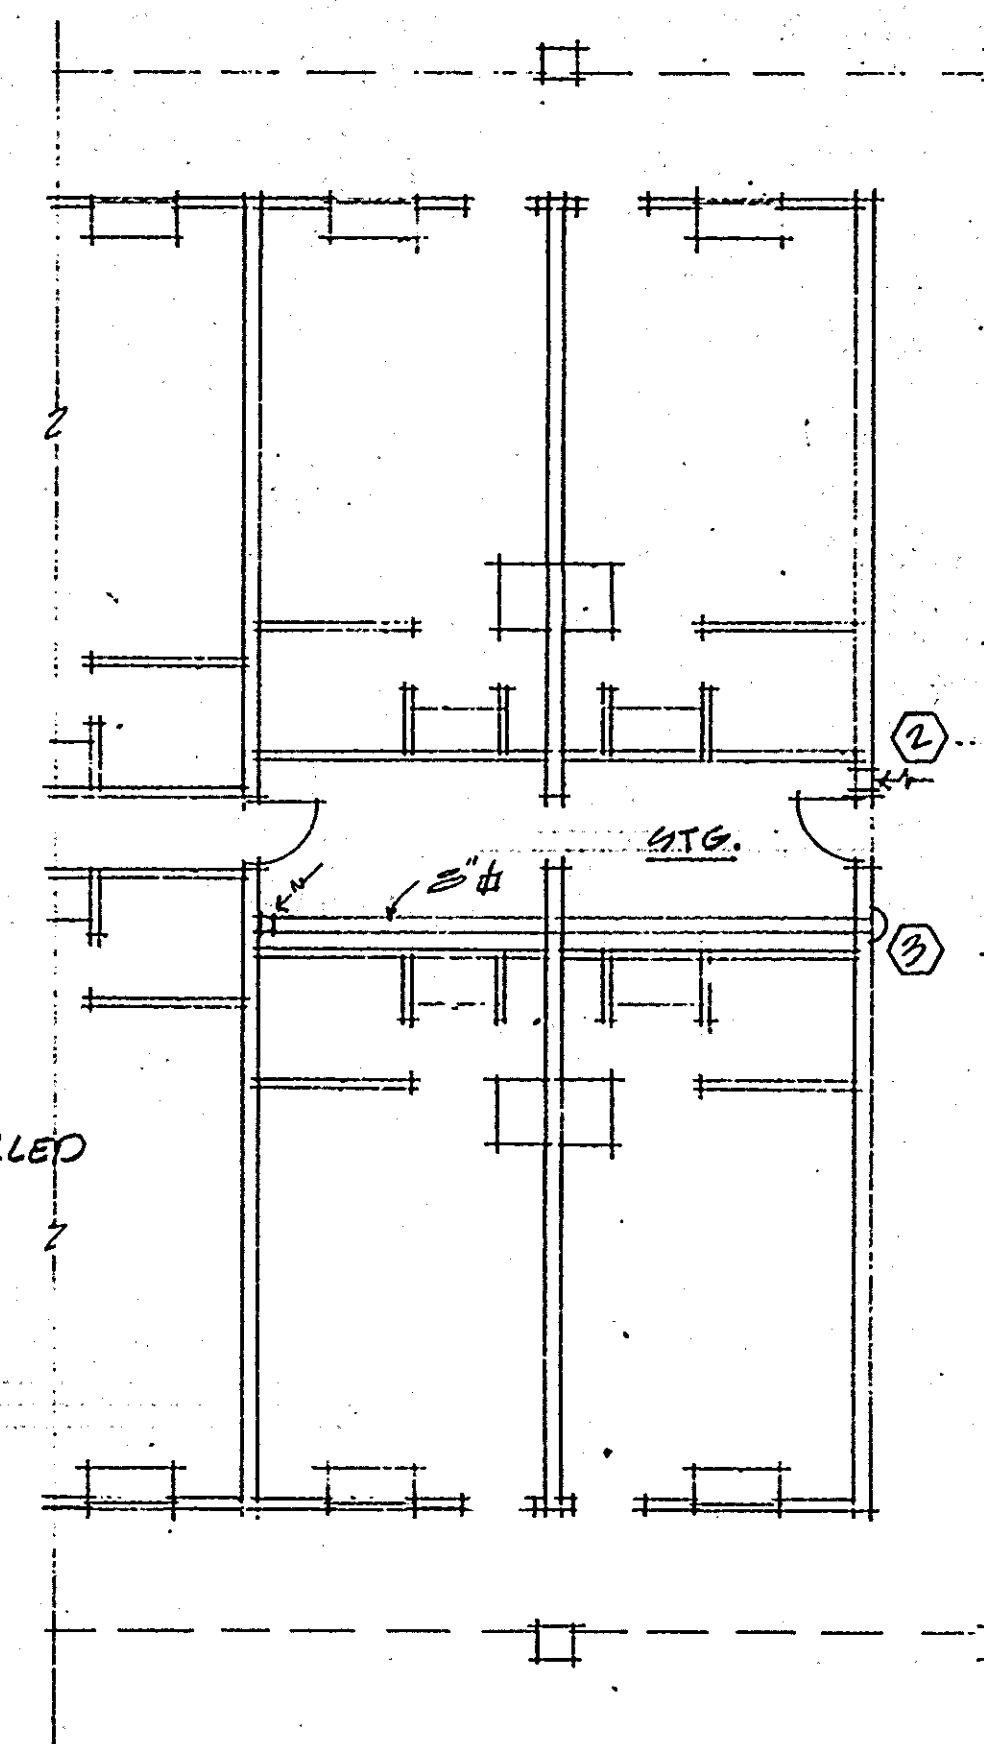

MECH. EQUIP. SCHEDULE

AC = THRU-WALL AIR CONDITIONER, G.E., AMANA OR APPROVED EQUAL; 208/1/60. MAX. BREAKER SIZE 20 AMP. COMPLETE W/ WALL SLEEVE, EXTERIOR GRILLE (SEE ARCH.). UNIT SHALL FIT INTO NOMINAL 2" X 16" WALL SLEEVE. 7000 B.T.U. COOLING CAPACITY, 3 KW. ELEC. RESISTANCE HEATER, PROVIDE TAPPLE SWITCH CONTROL PANEL @ REGISTRATION DESK.


SPLIT SYSTEM = SPLIT SYSTEM CONSISTS OF INTERIOR FAN COIL UNIT & EXTERIOR AIR COOLED CONDENSING UNIT.

SYSTEM #1: COOLING CAPACITY = NOM. 6 TONS @ 1400 CFM EVAP. AIR W/ 1/2 KW. 2 STAGE ELEC. HEATER 208/3/60. EVAP. FAN MOTOR = NOM. 1 HP @ 208/3/60. COND. UNIT = NOM. 2 1/2" X 16" @ 208/3/60. PROVIDE THERMOSTAT W/ LOCK COVER, 1 STAGE COOL, 2 STAGE HEAT.


SYSTEM #2: COOLING CAPACITY = NOM. 3 1/2 TONS @ 1400 CFM EVAP. AIR W/ 1/2 KW. 2 STAGE ELEC. HEATER 208/3/60. EVAP. FAN MOTOR = NOM. 1/2 HP @ 208/3/60. COND. UNIT = NOM. 1 1/2" X 16" @ 208/3/60. PROVIDE THERMOSTAT W/ LOCK COVER, 1 STAGE COOL, 2 STAGE HEAT.

NOTE: SYSTEM #1 SHALL BE PROVIDED W/ RET. AIR SMOKESTAT SHUT-OFF IN ACCORD W/ NFPA

NOTE: PROVIDE 2-HR ULFO @ DUCT PENETRATIONS OF WALLS SURROUNDING FAN COIL UNIT #1 & 1/2 HR FUSIBLE LINK RAS. IN B' LABLE DOOR TO F.C. UNIT #1 RM. (HAMPTON INN REQUIREMENT).

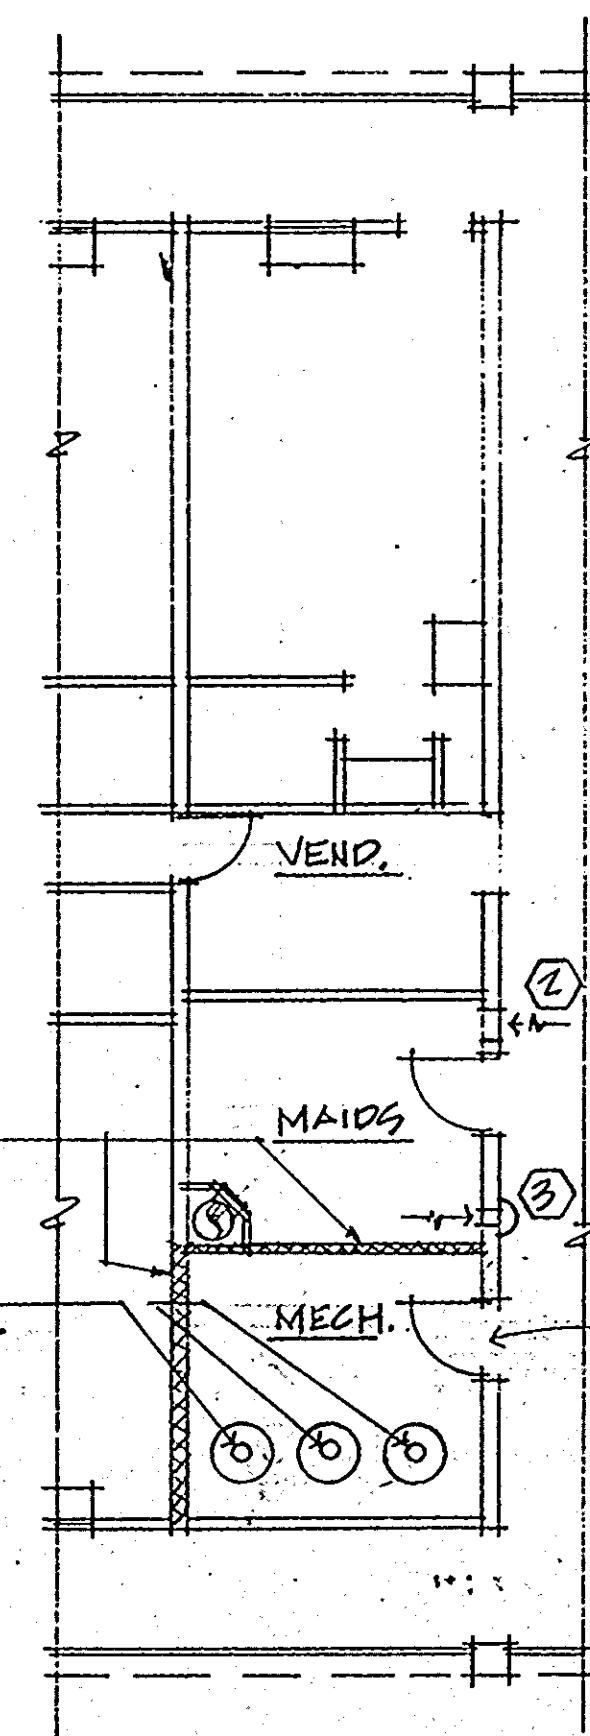


3. PART I. SECOND FLOOR PLANS
1/8" = 1'-0"

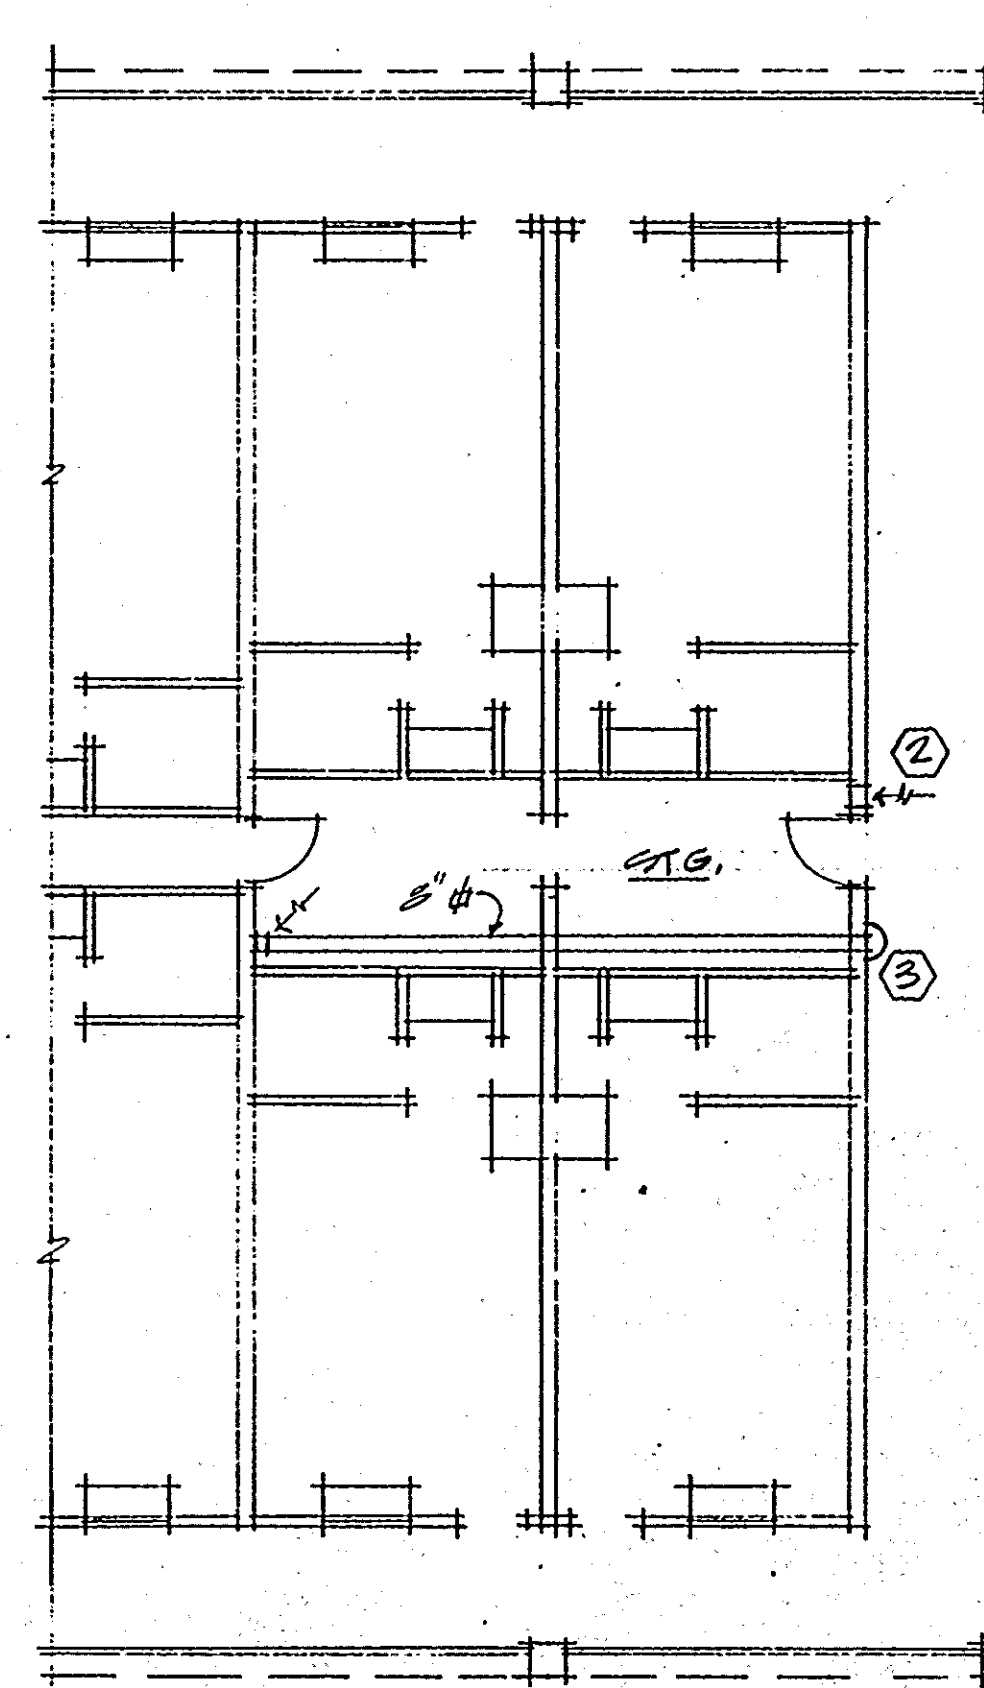

1-23-93
REV. 3-27-93


COMMERCIAL / SERVICE AREA FLOOR PLANS	HAMPTON INN MONROE, LA		DESIGN CONSORTIUM HOTEL CONSULTANTS MEMPHIS, TENNESSEE	
	DATE	3-10-93	M-3	
	SCALE			
	JOB NO.			

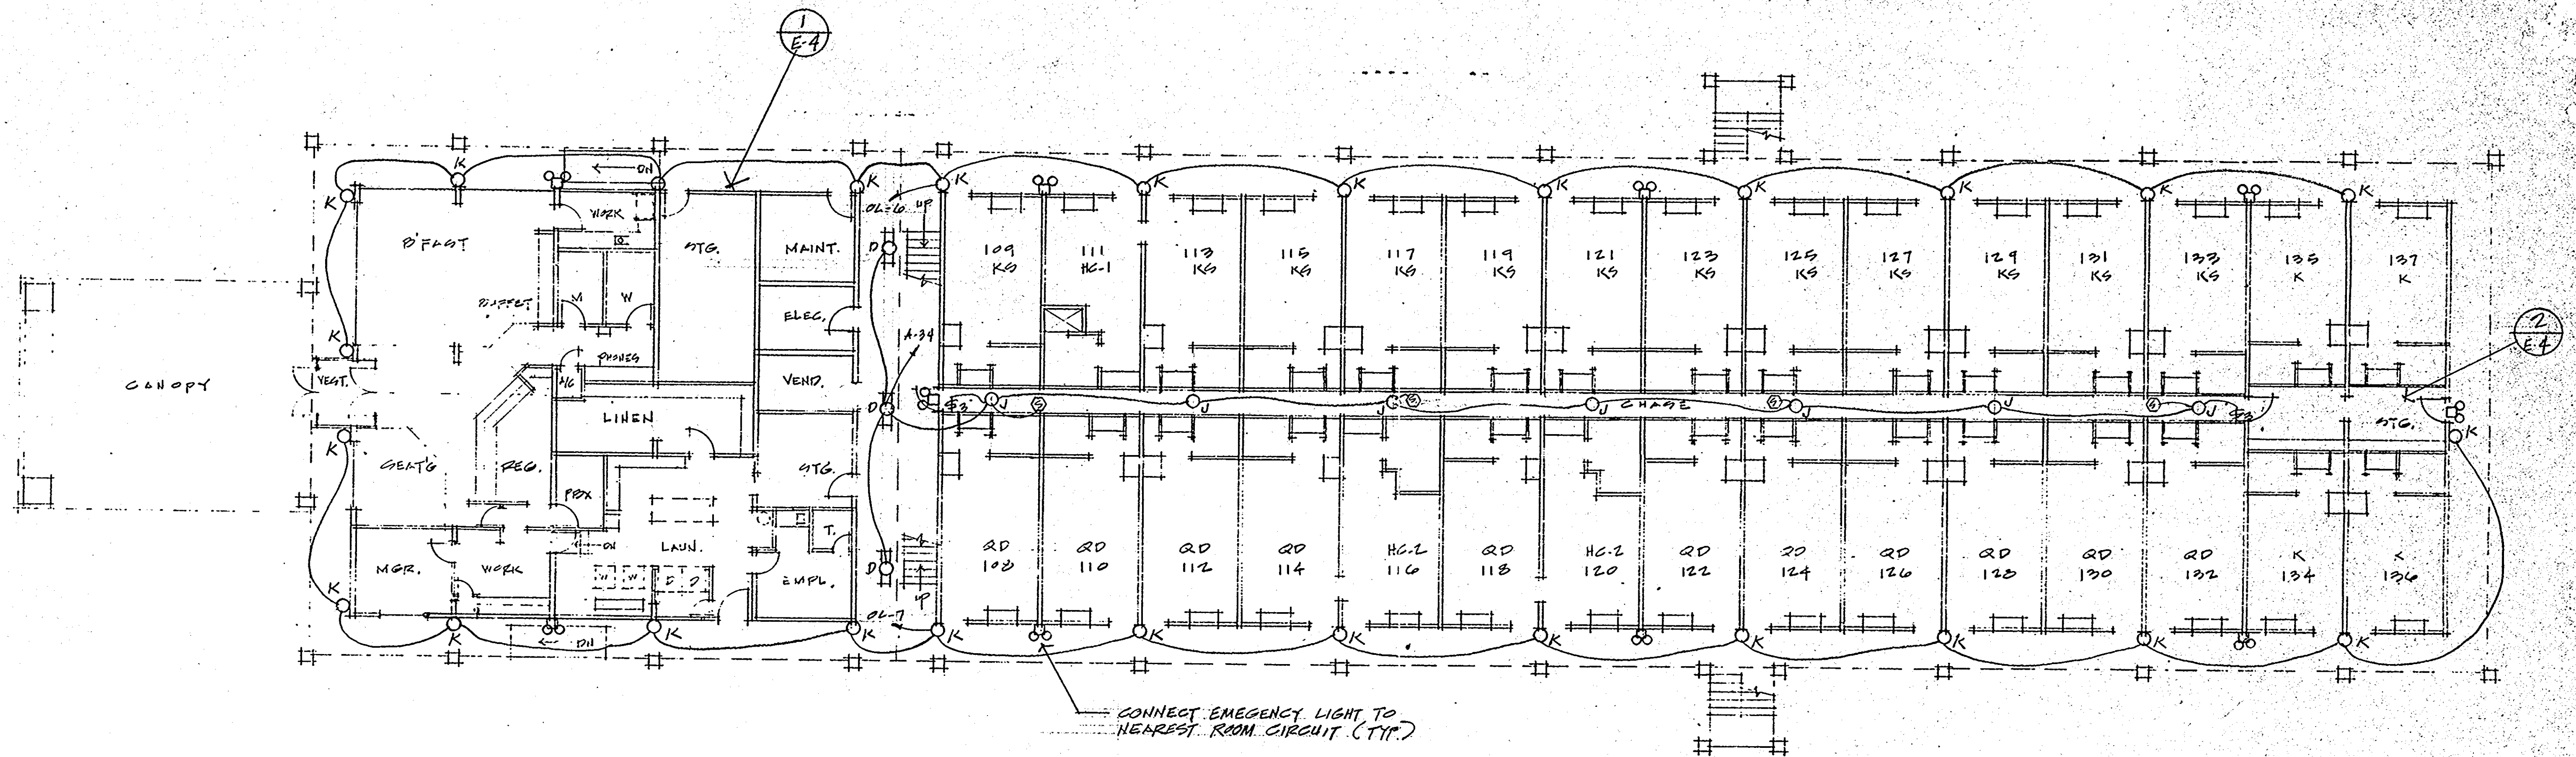

GROUND FLOOR PLAN
LIGHTING 3/32" = 1'-0"


REV. 3-27-93

HAMPTON INN MONROE, LA	DESIGN CONSORTIUM		
	HOTEL CONSULTANTS MEMPHIS, TENNESSEE		
	DATE	3-14-93	E-1
	SCALE		
GROUND FLOOR LIGHTING PLAN	JOB NO.		

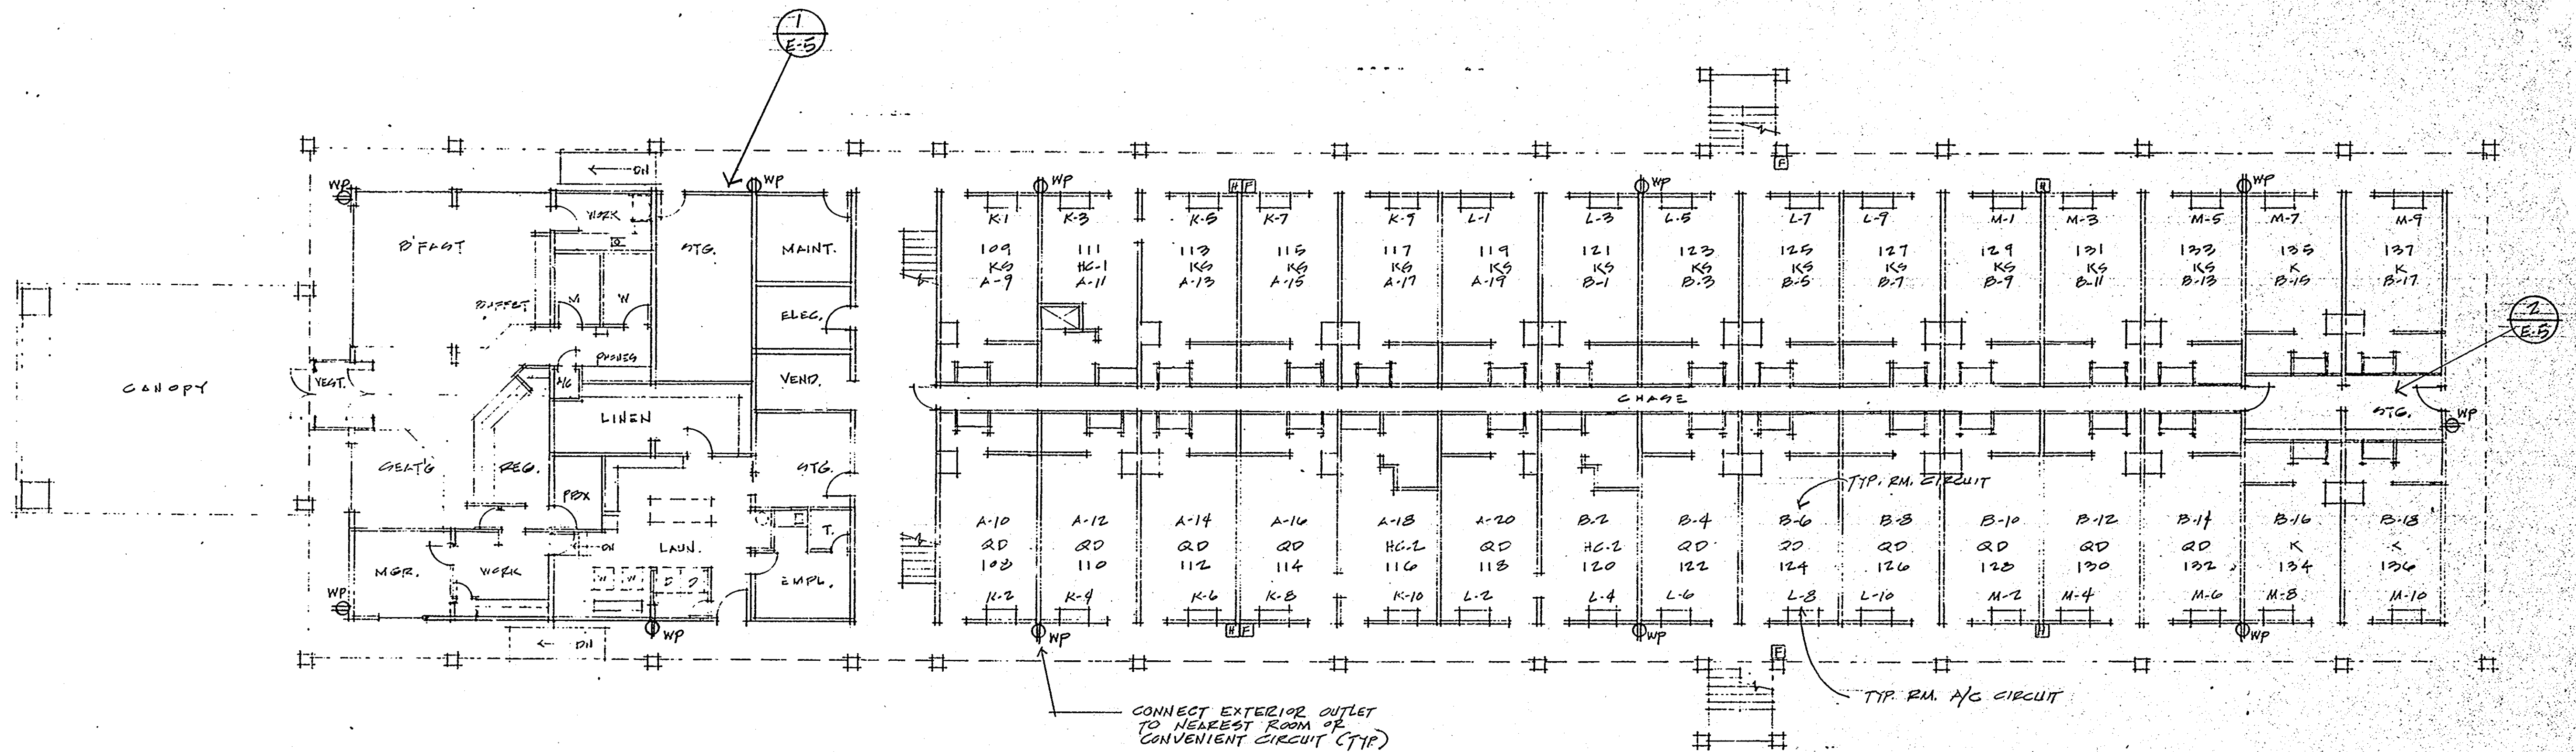

REV. 3-27-93


HAMPTON INN MONROE, LA		DESIGN CONSORTIUM HOTEL CONSULTANTS MEMPHIS, TENNESSEE	
GROUND FLOOR POWER PLAN	DATE	3-10-93	E-2
	SCALE		
	JOB NO.		

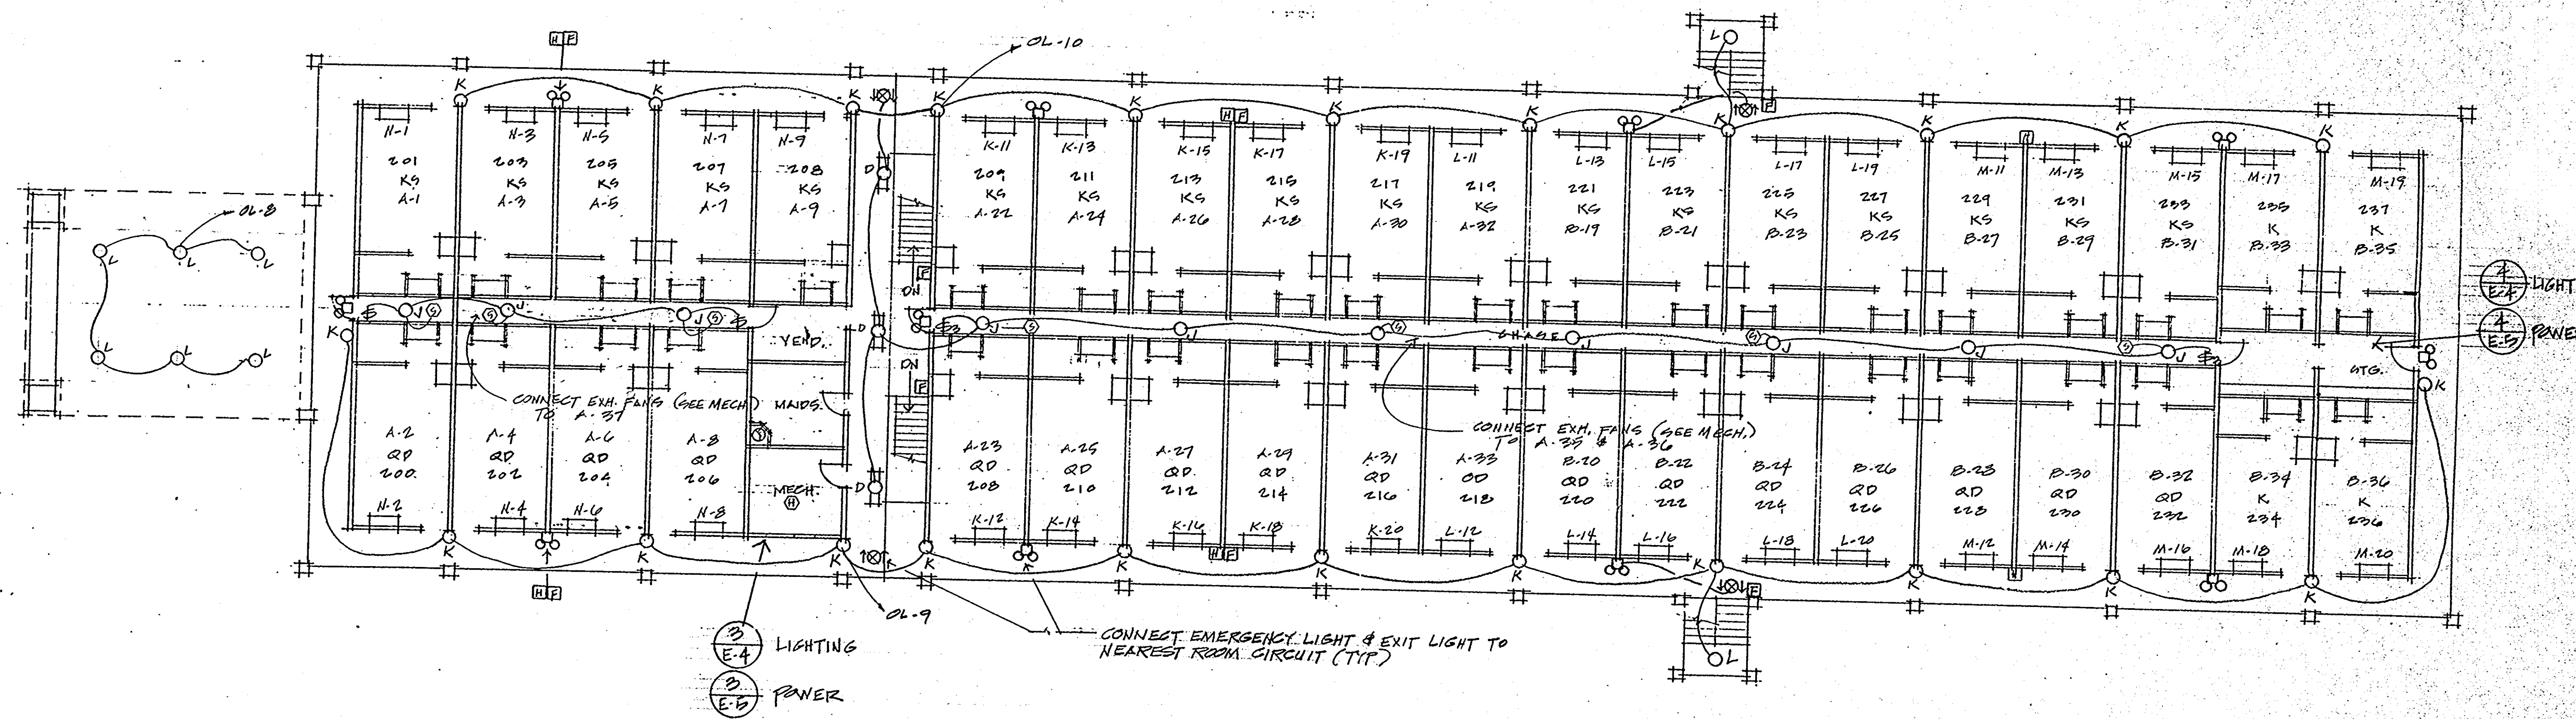



2ND FLOOR PLAN
3/32" = 1'-0"

REV. 3-27-93


HAMPTON INN MONROE, LA		DESIGN CONSORTIUM HOTEL CONSULTANTS MEMPHIS, TENNESSEE	
SECOND FLOOR ELECTRICAL PLAN	DATE	3-10-93	E-3
	SCALE		
	JOB NO.		

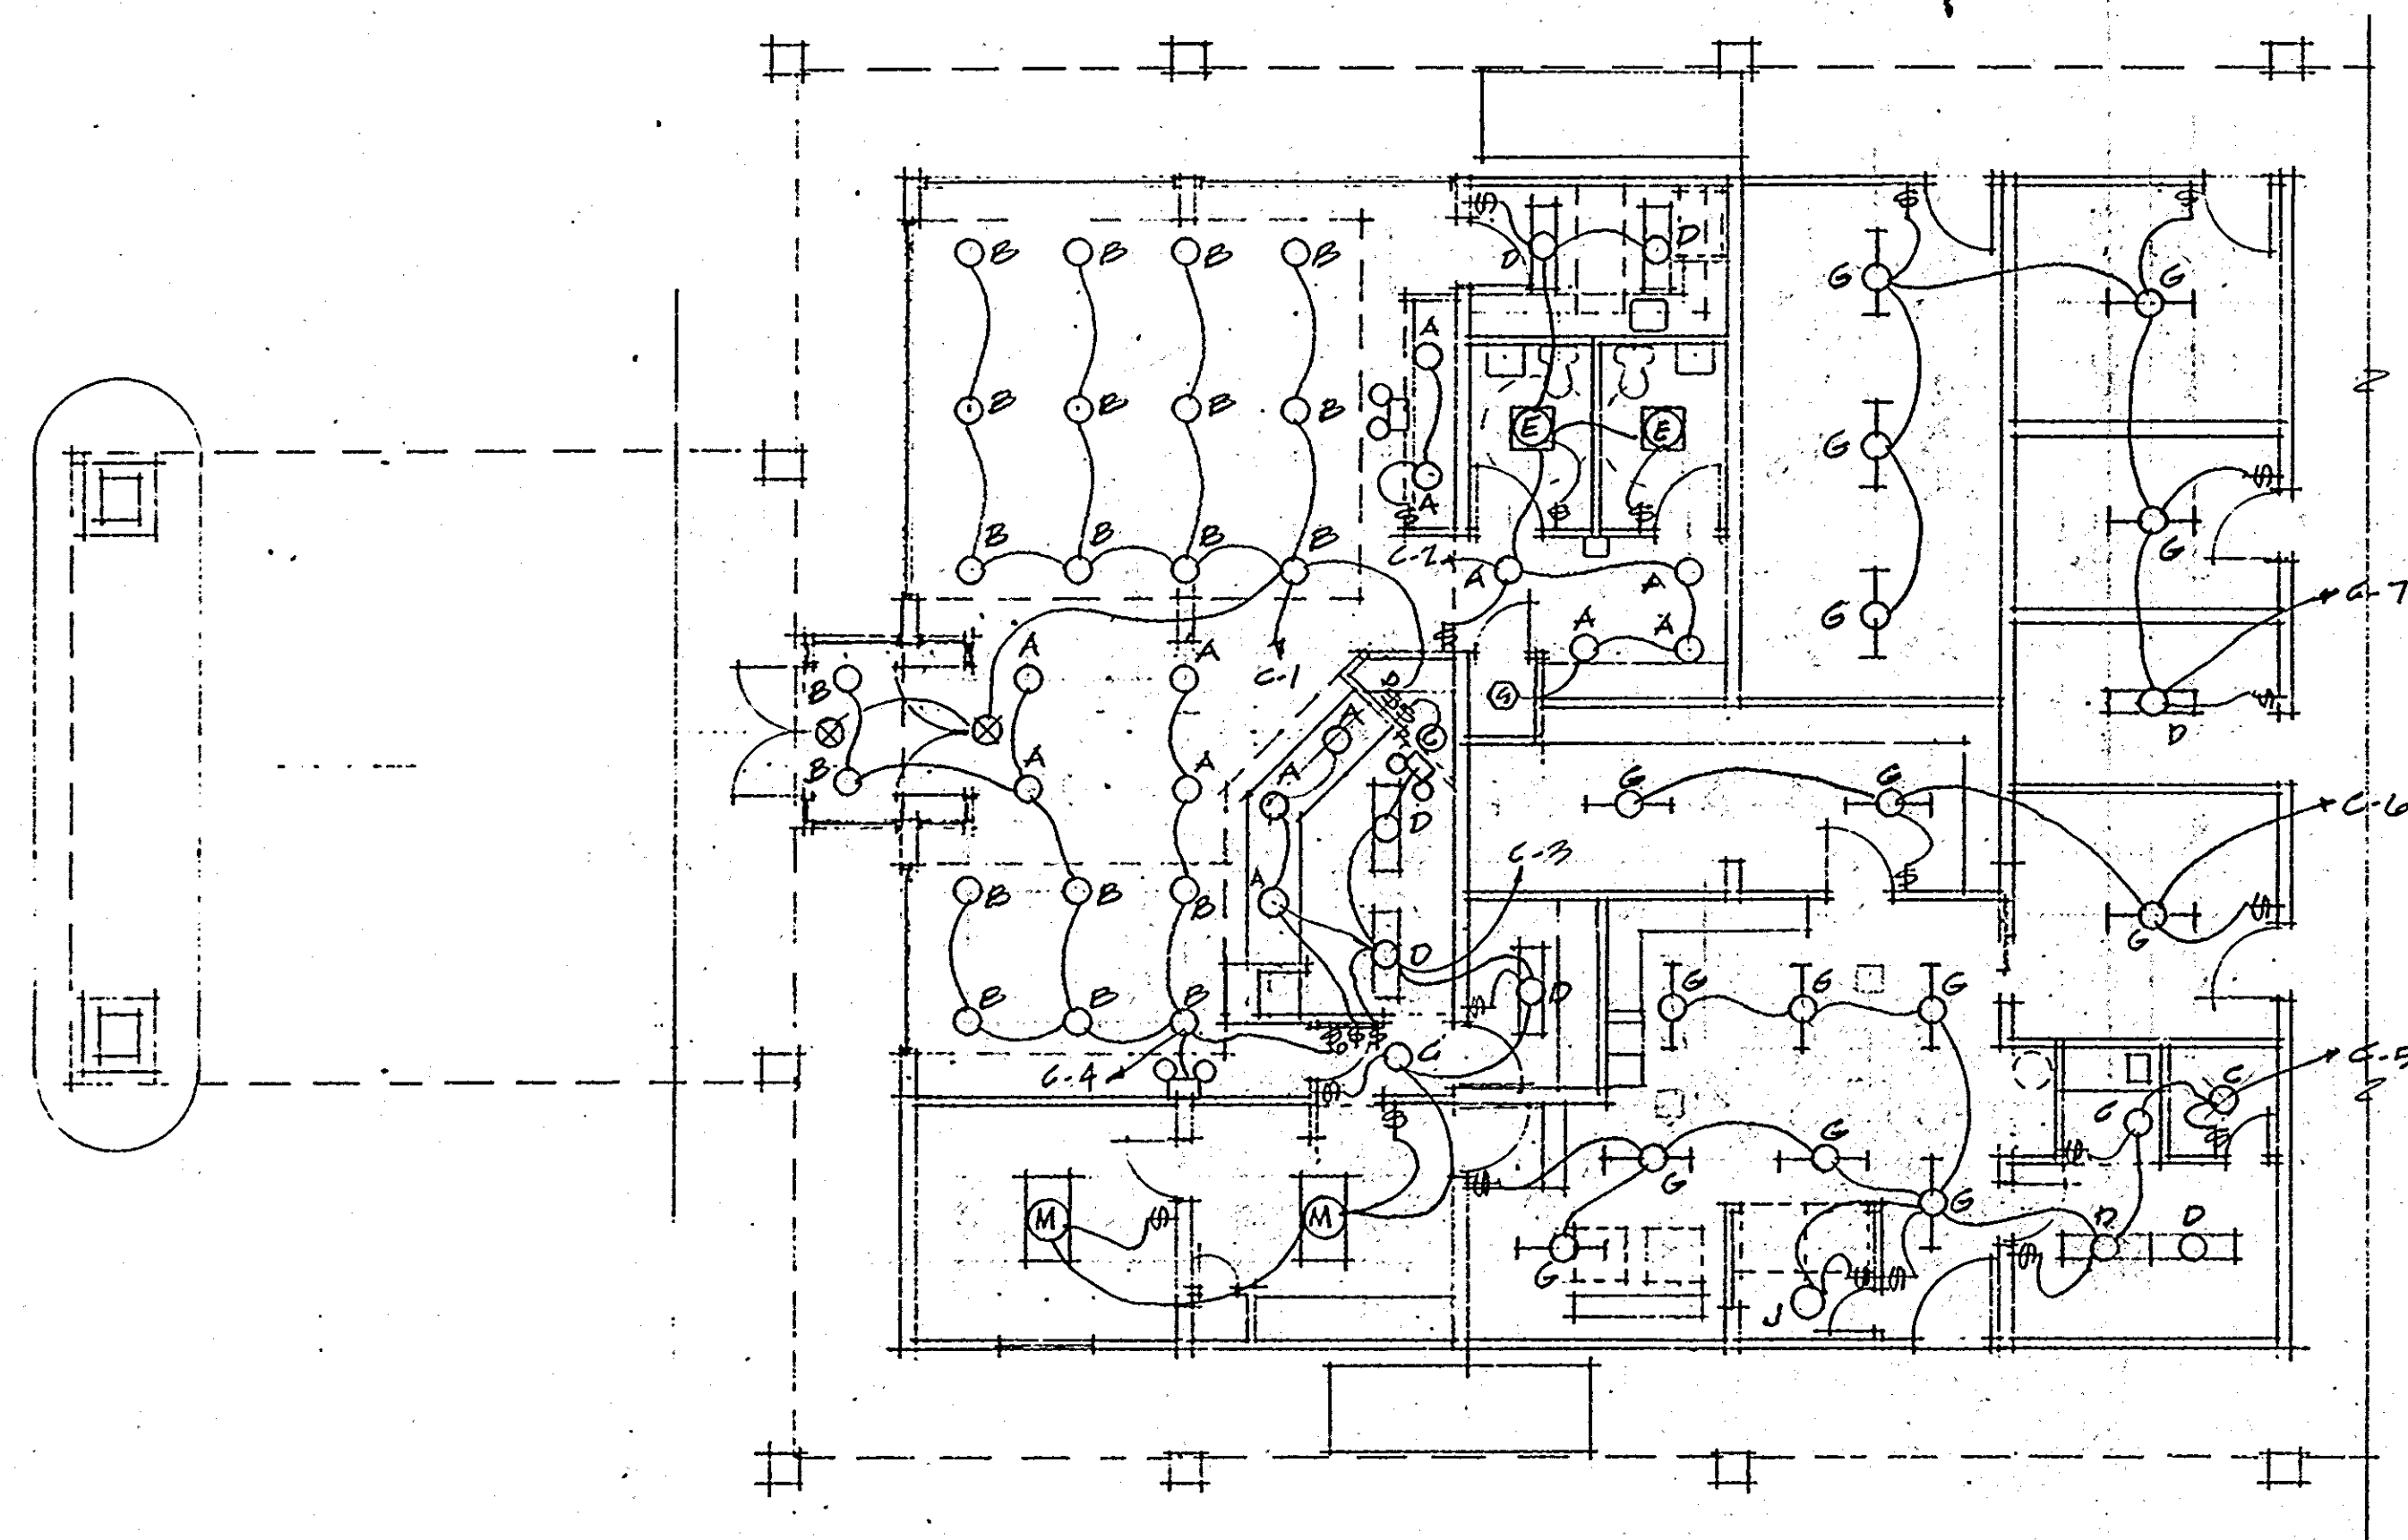

①
PART L GROUND
FLOOR PLANS
1/8" = 1'-0"
LIGHTING ②

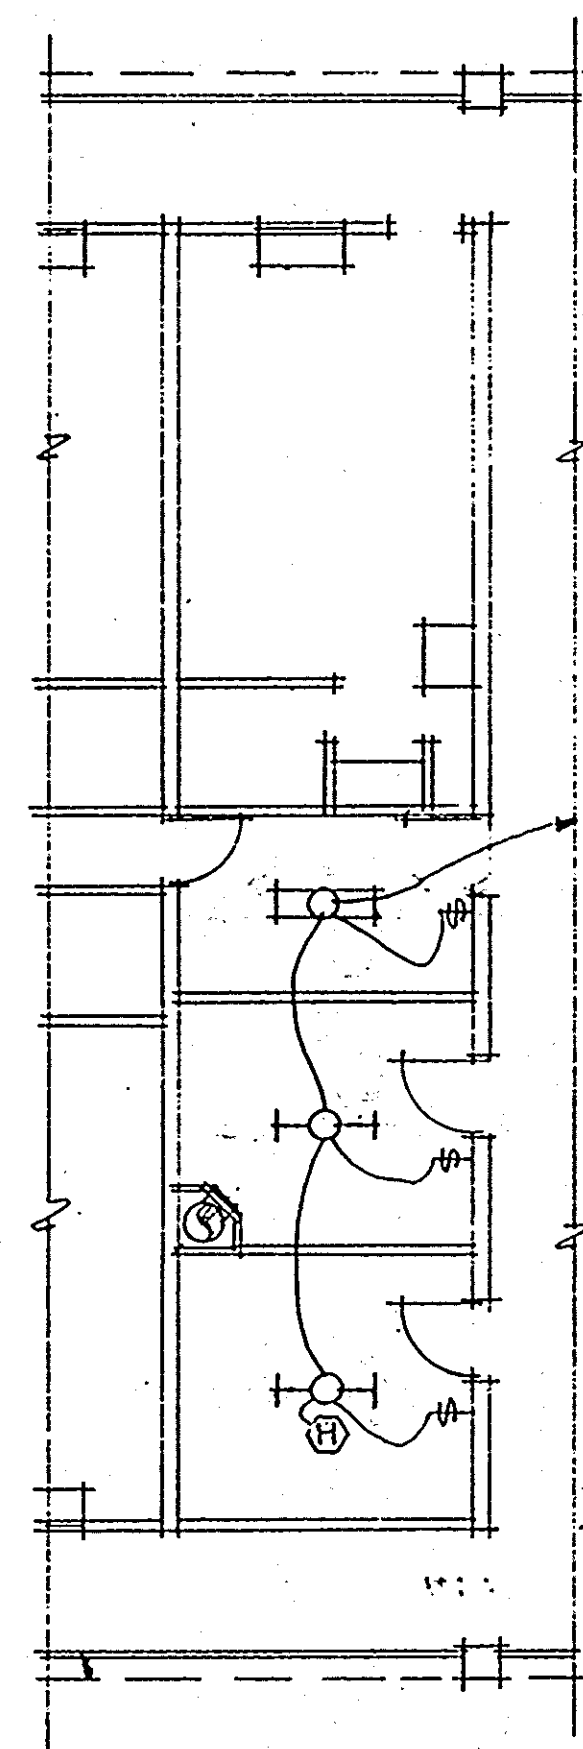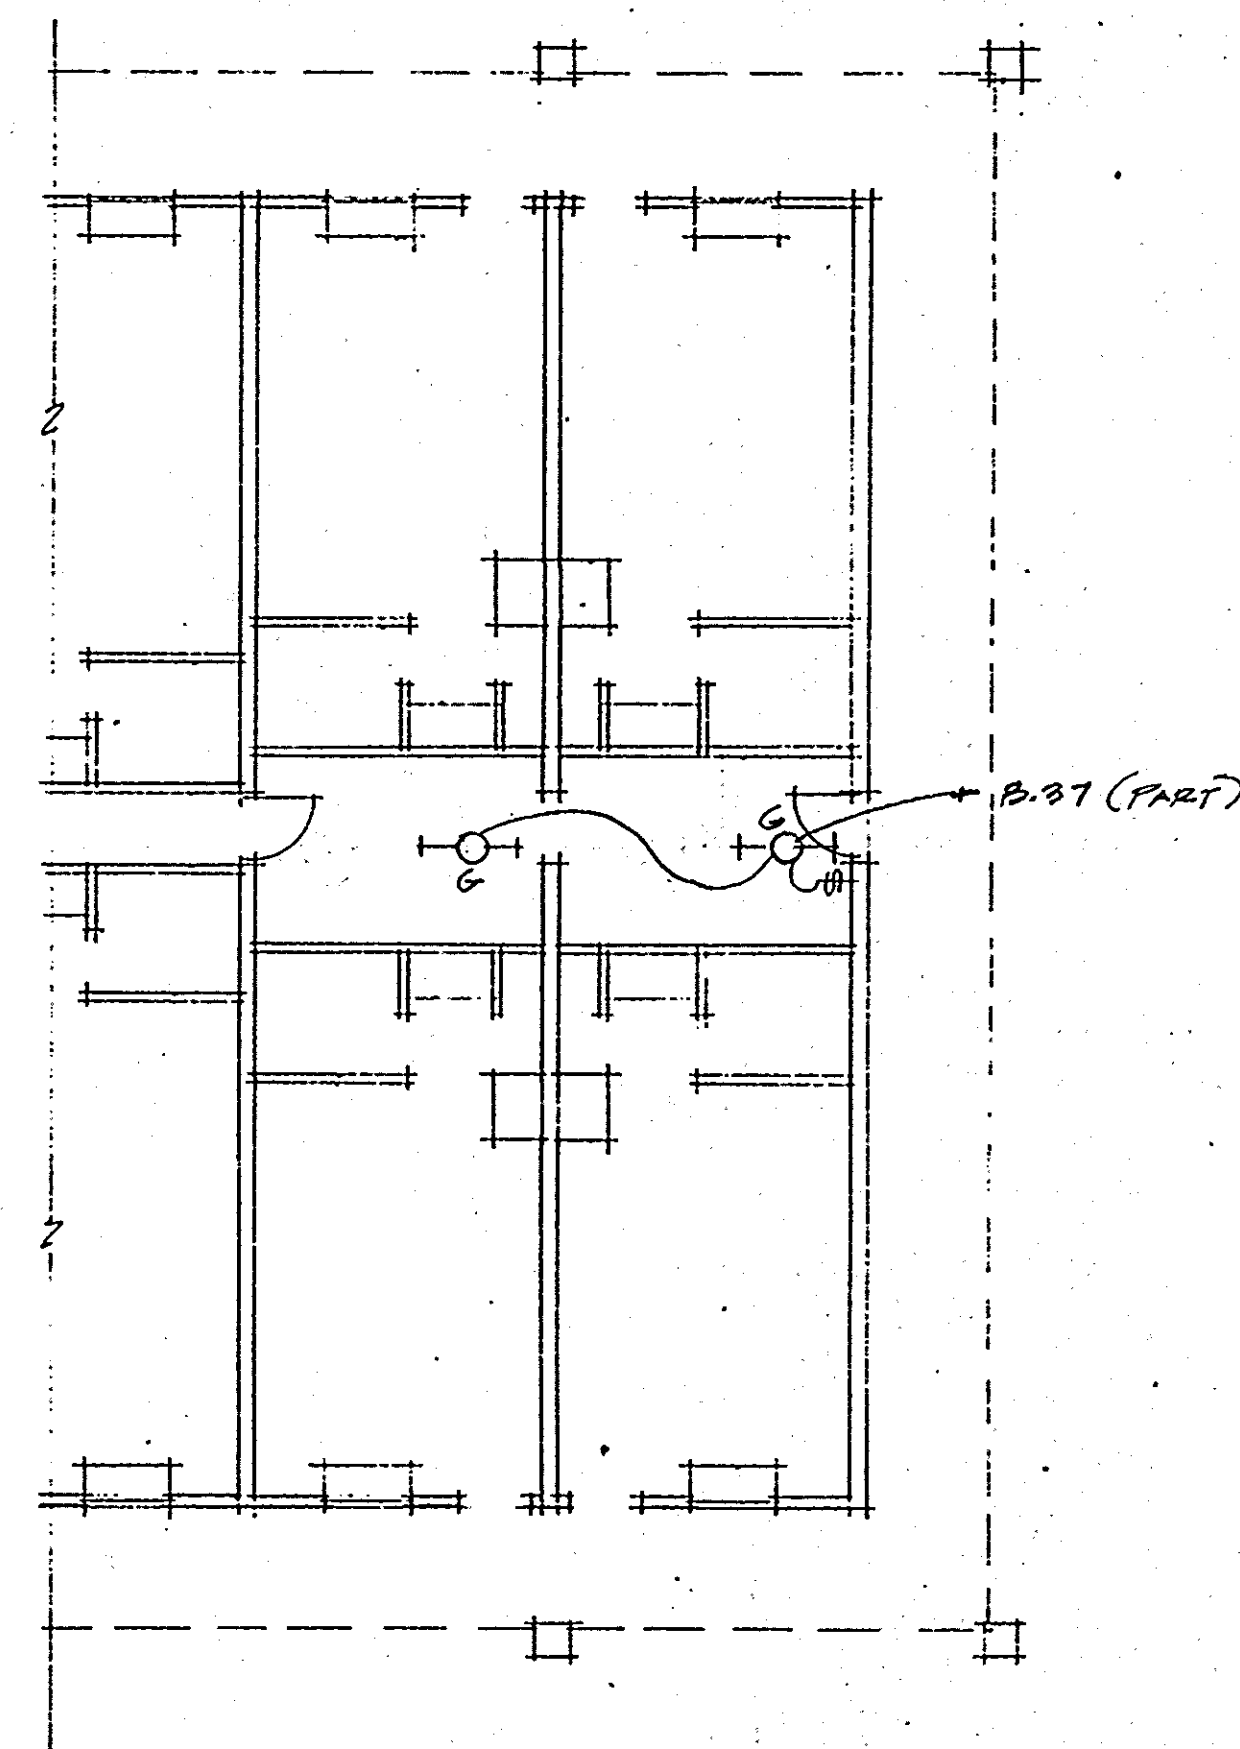


③
PART L SECOND
FLOOR PLANS
1/8" = 1'-0"
LIGHTING ④

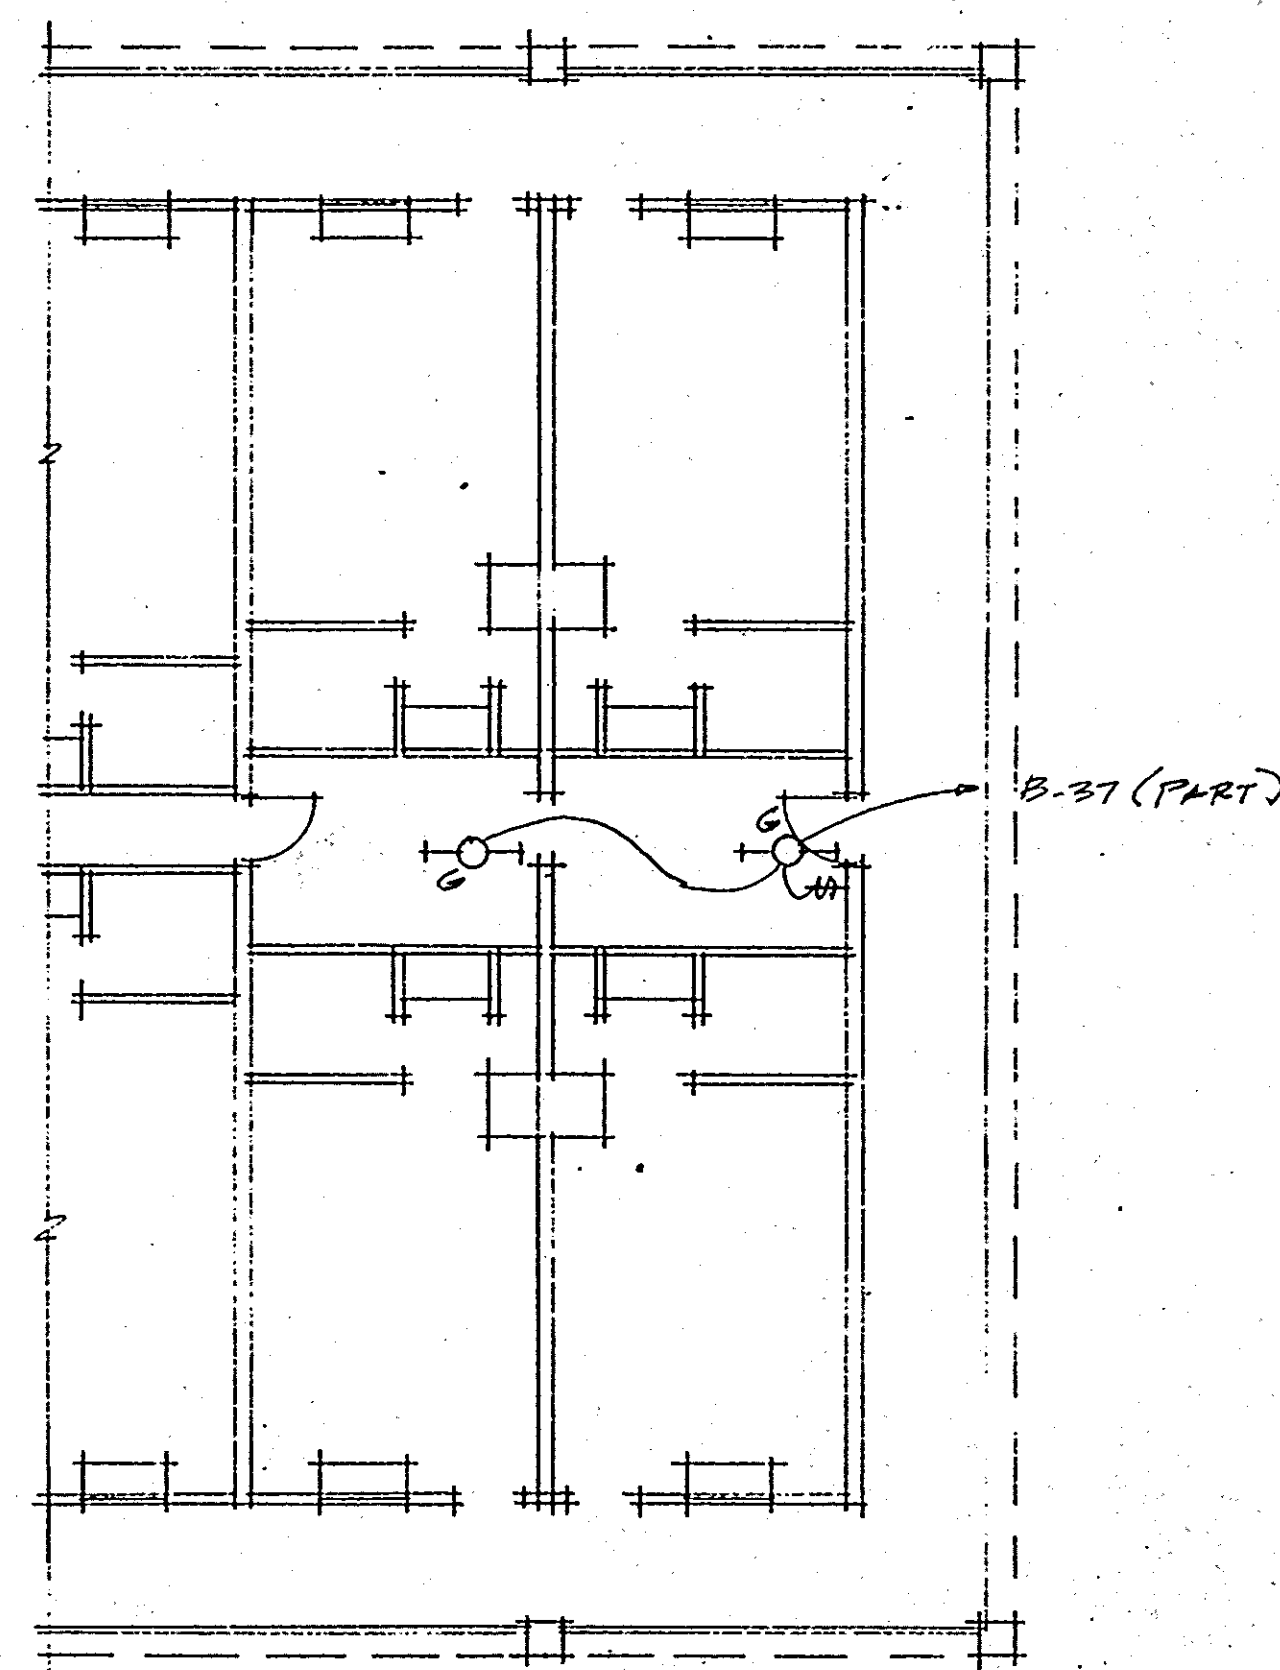


REV. 3-27-93


HAMPTON INN MONROE, LA	DESIGN CONSORTIUM		
	HOTEL CONSULTANTS MEMPHIS, TENNESSEE		
	DATE	3-10-93	E-4
	SCALE		
COMMERCIAL / SERVICE AREA LIGHTING PLAN	JOB NO.		

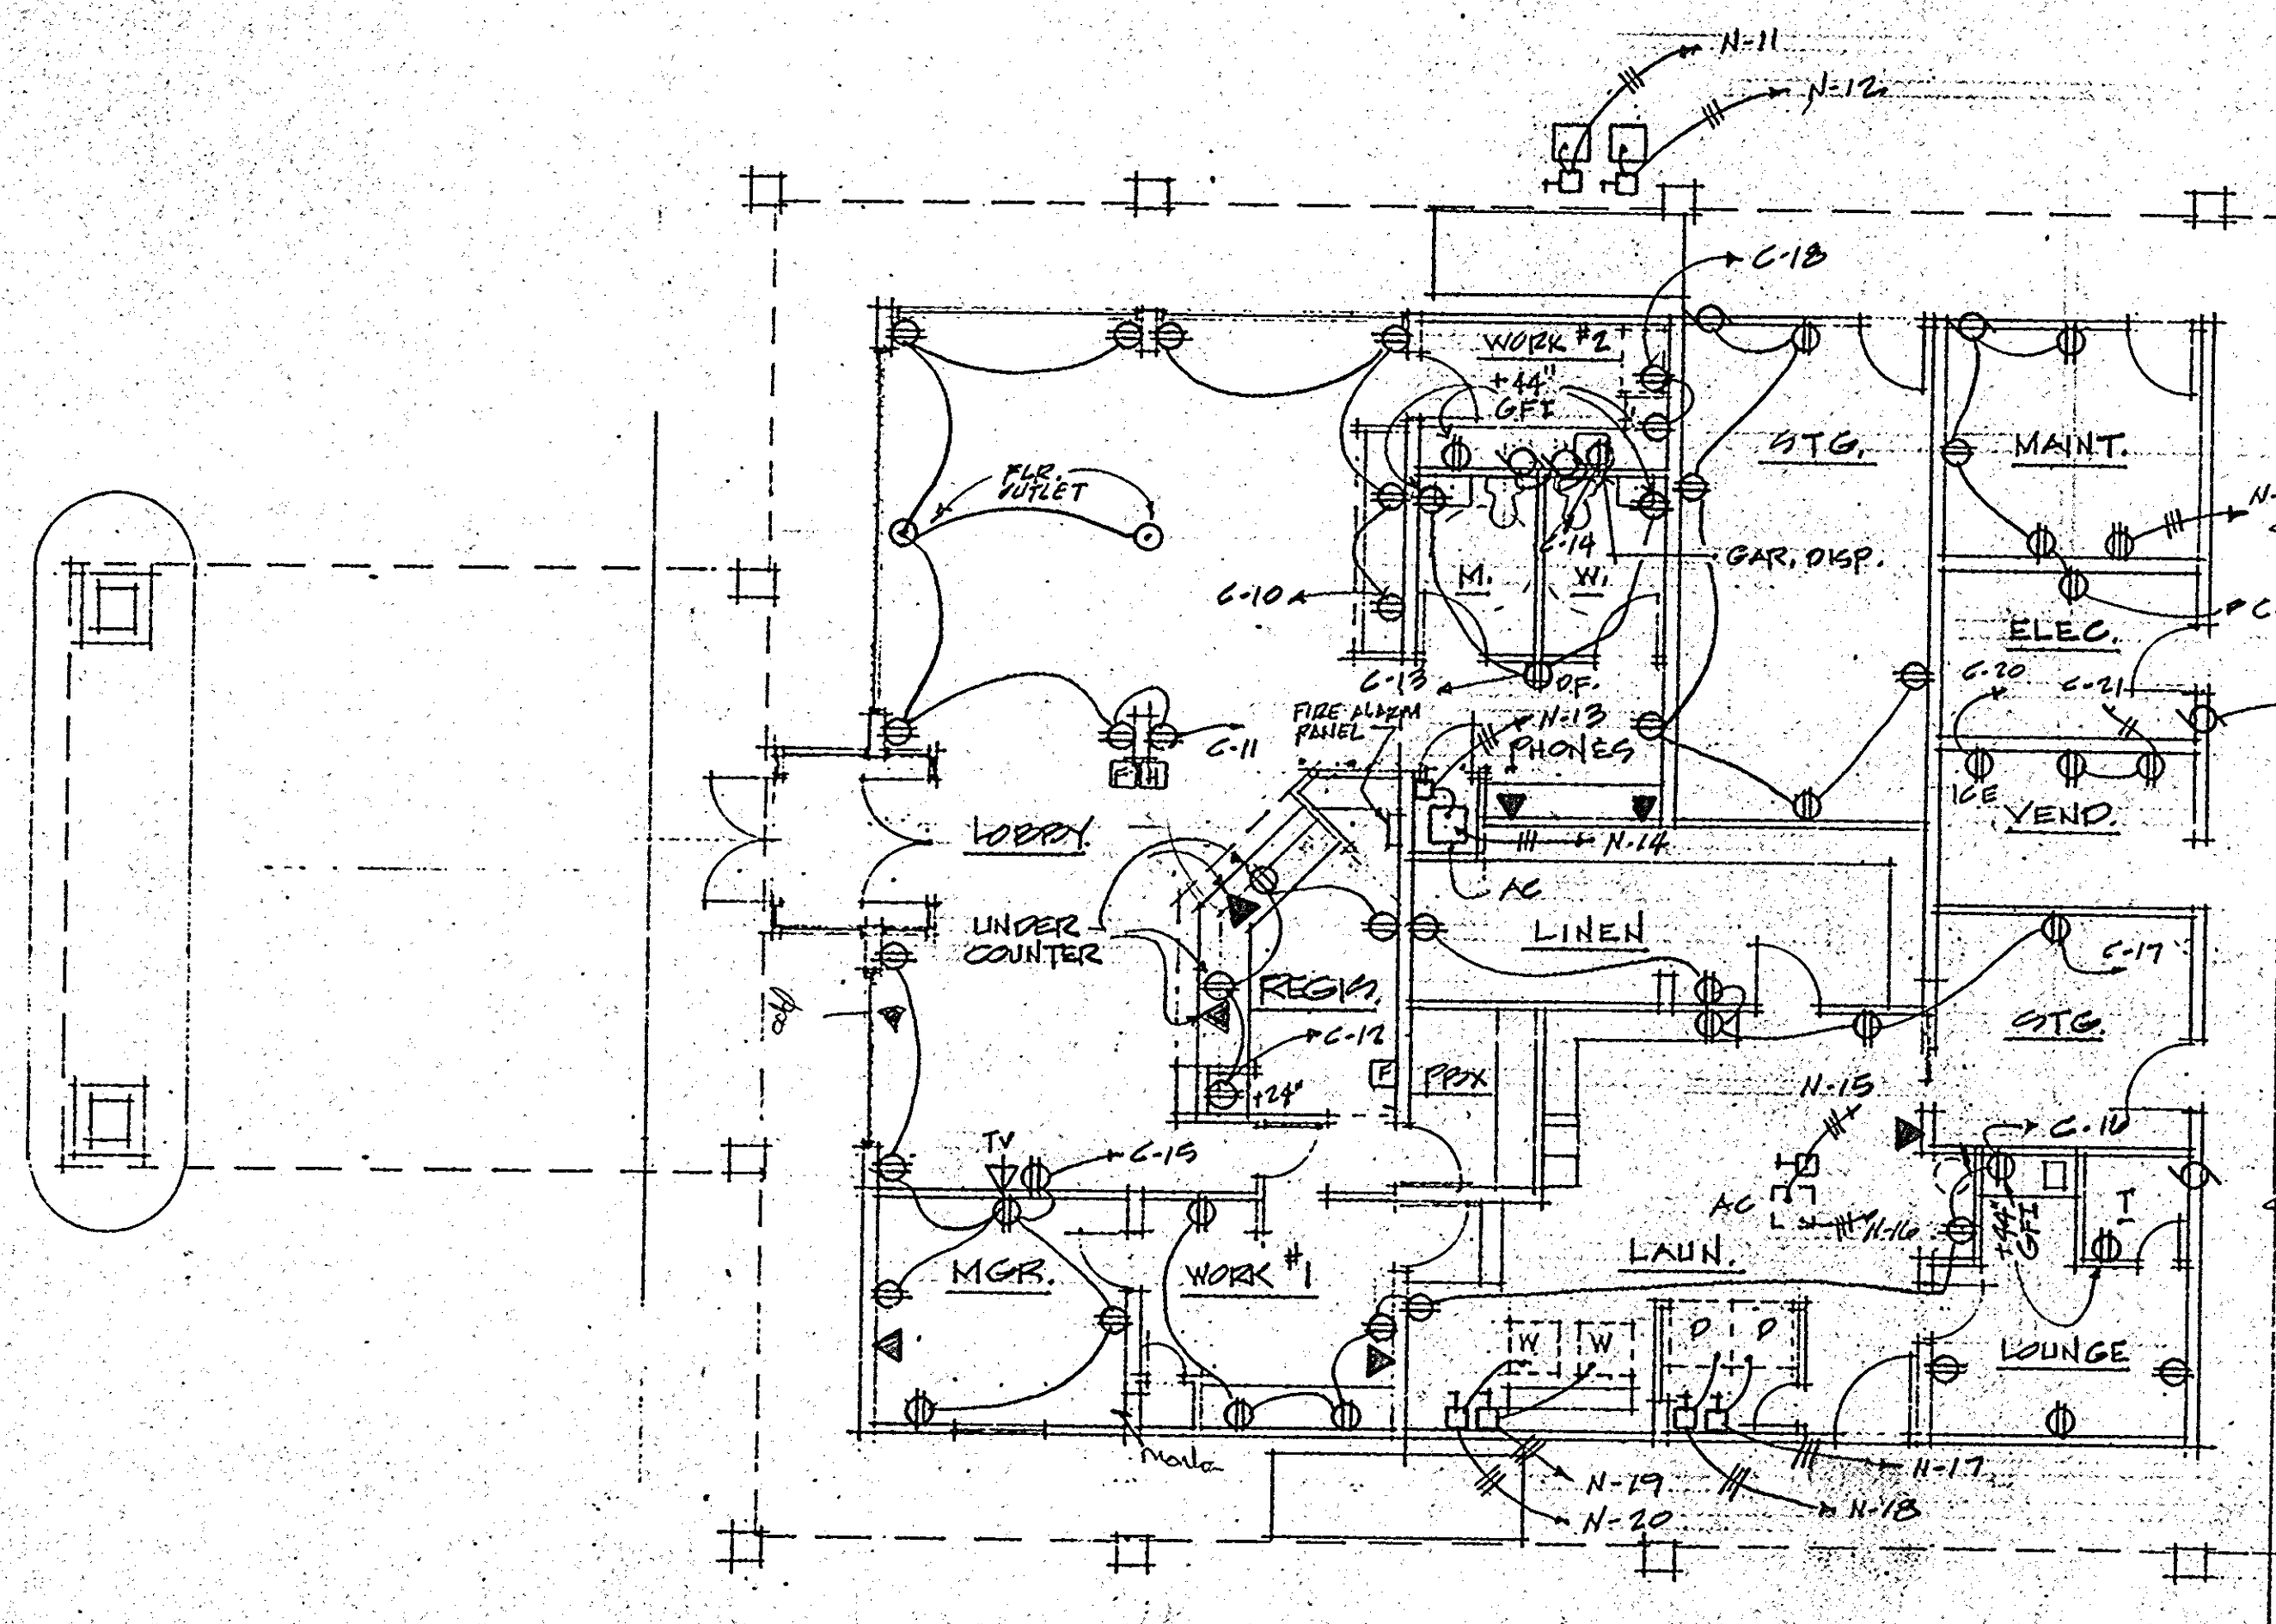

1
PART 'L' GROUND
FLOOR PLANS
1/8" = 1'-0"
POWER

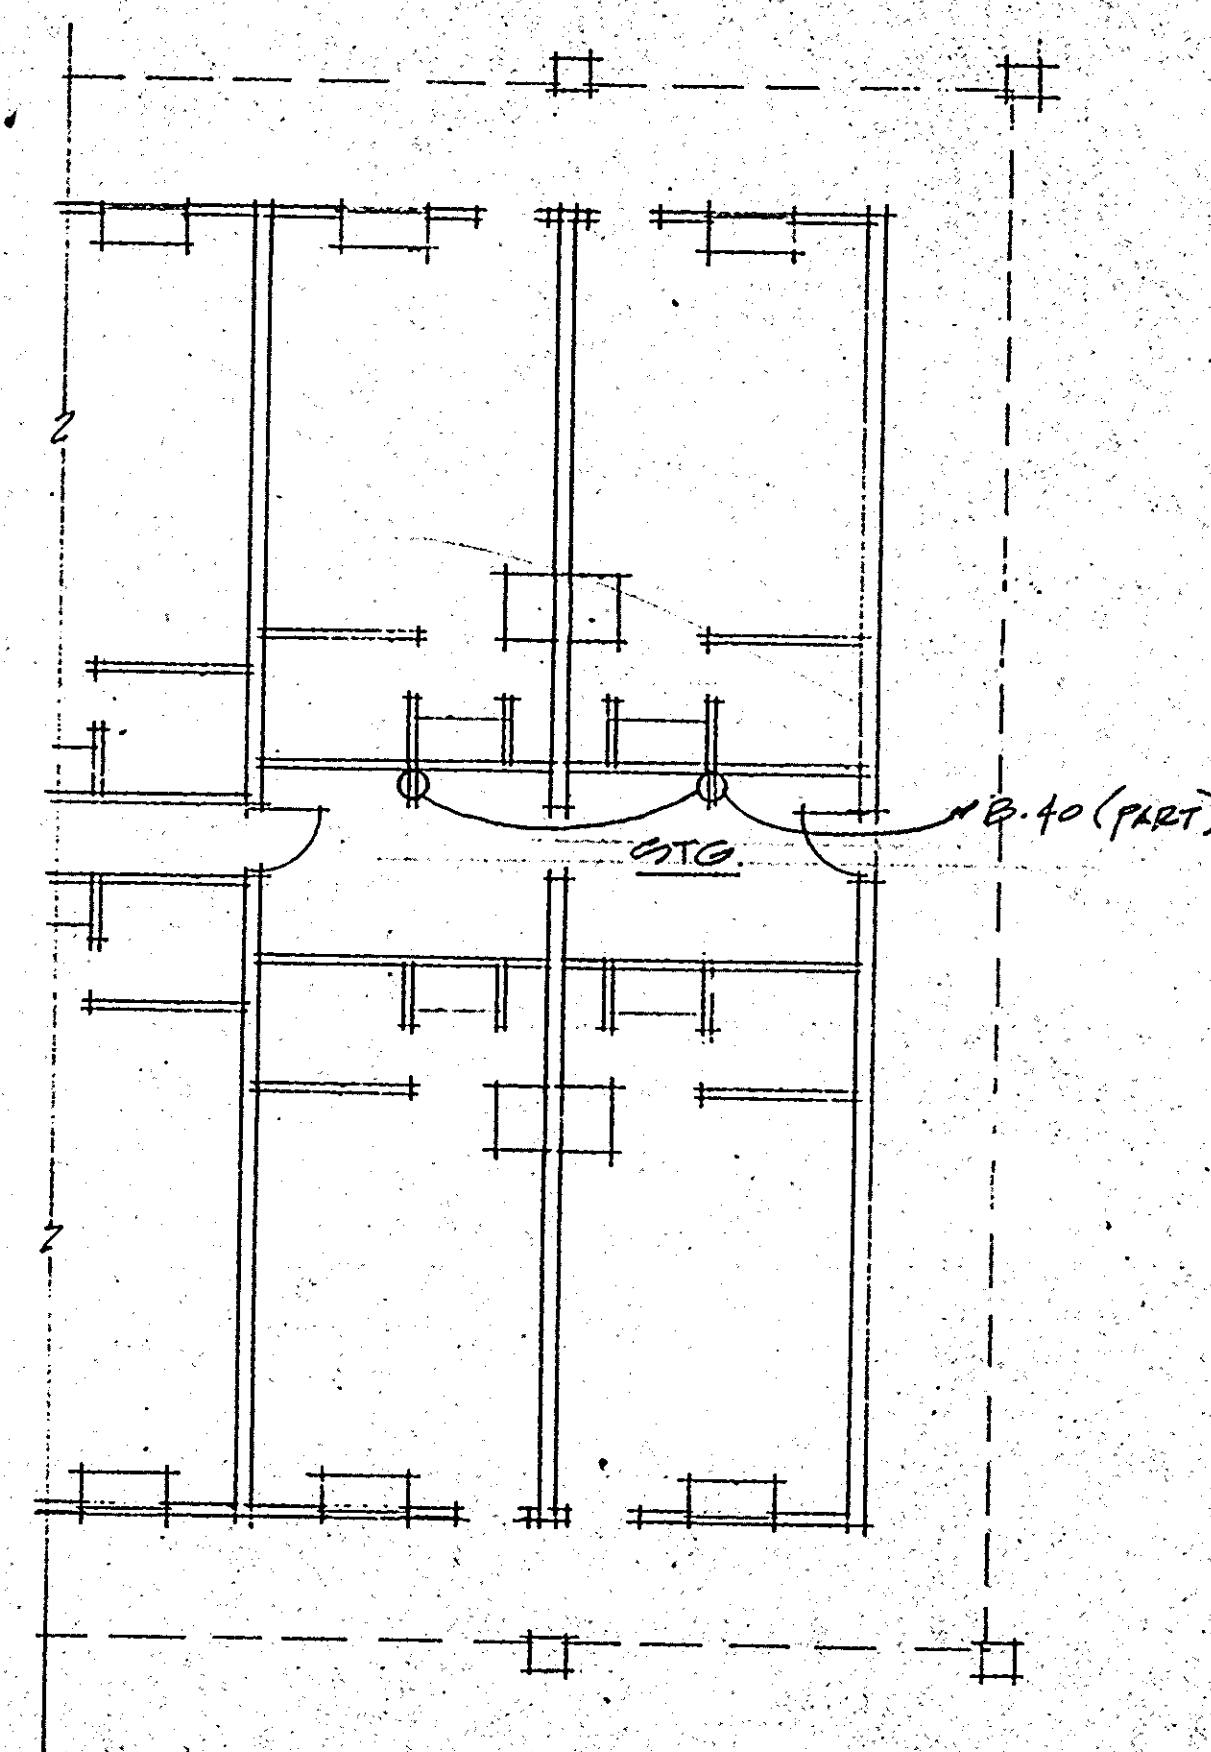


3
PART 'L' SECOND
FLOOR PLANS
1/8" = 1'-0"
POWER

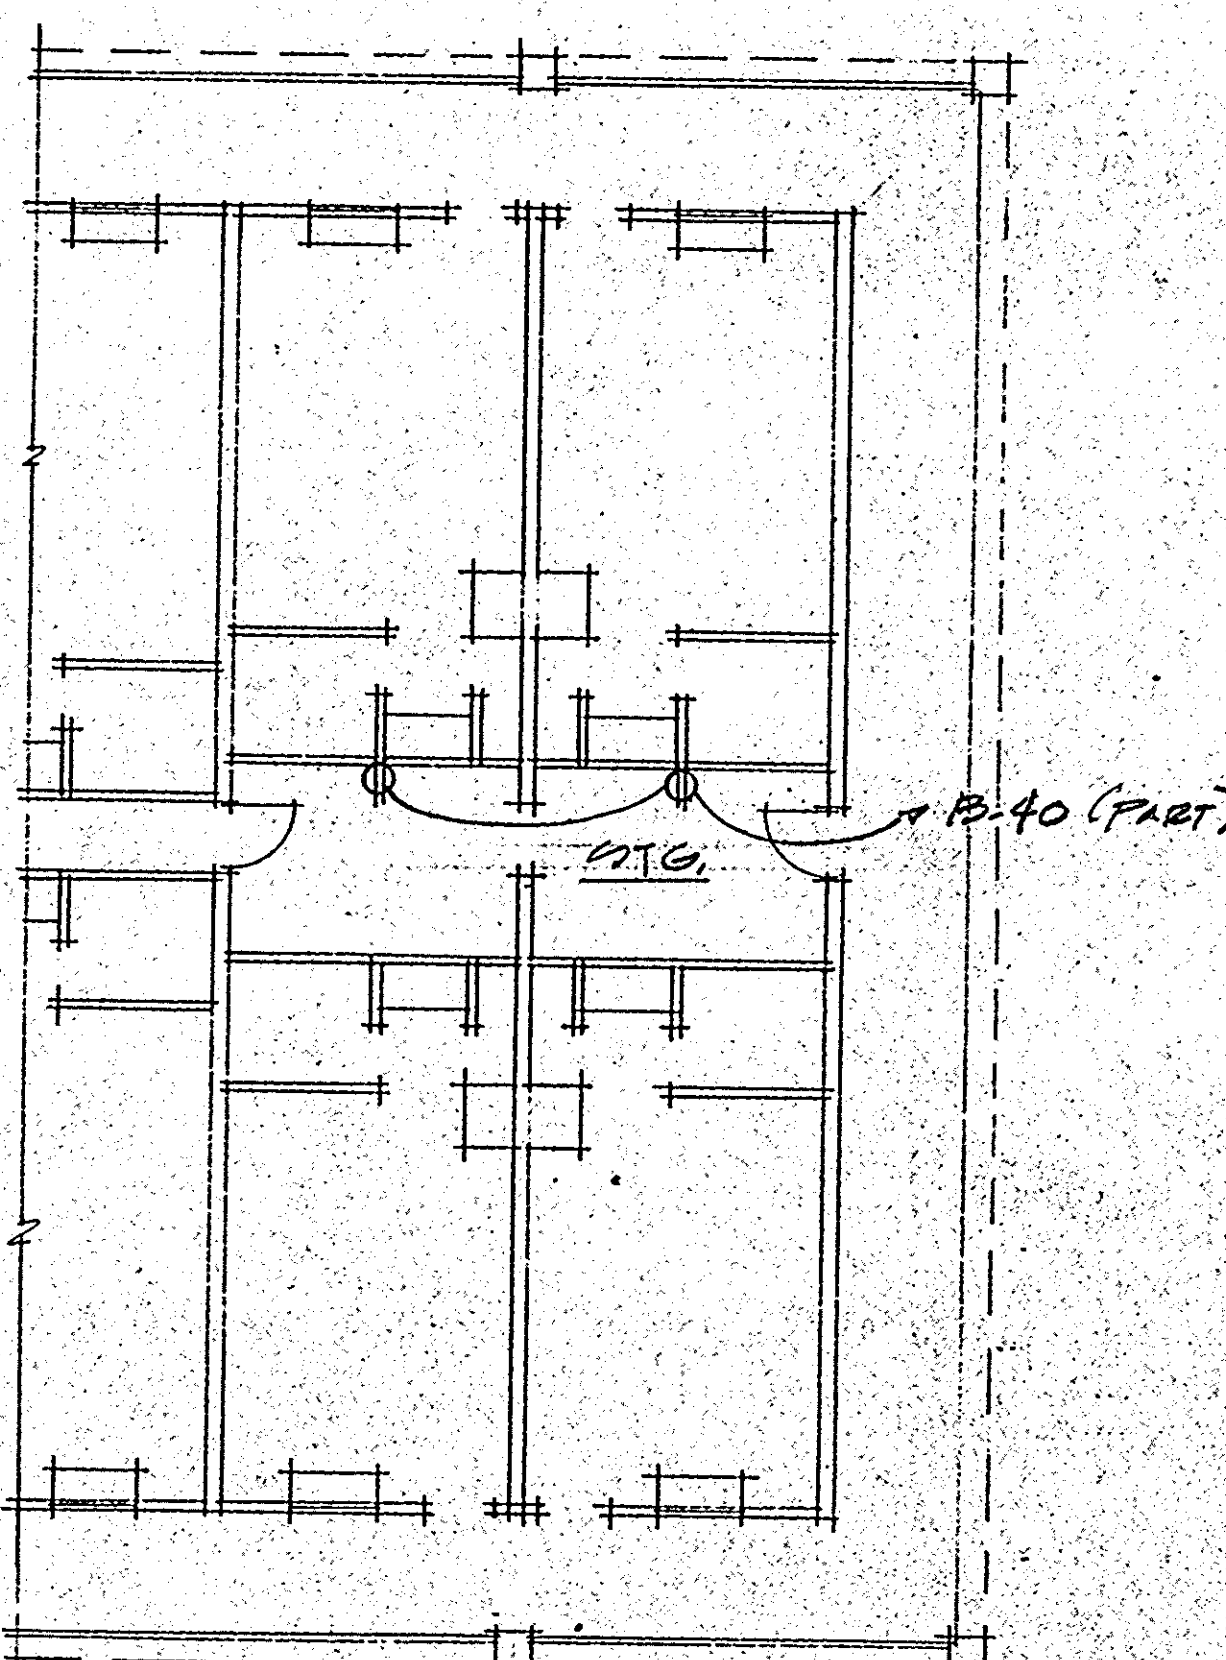

NOTE:


CONF. W/ OWNER & VERIFY CONN. OUTLETS, TELEPHONES
& T.V. LOCATIONS IN LOBBY AREA, & REG. VERIFY ANY
OTHER OWNER REQUIREMENTS FOR REGISTRATION,
REG. WORK, ETC.
ELEC. CONTR. TO PROVIDE ISOLATED ELEC.
SERVICE FOR COMPUTER & RESERVATION
SYSTEM.

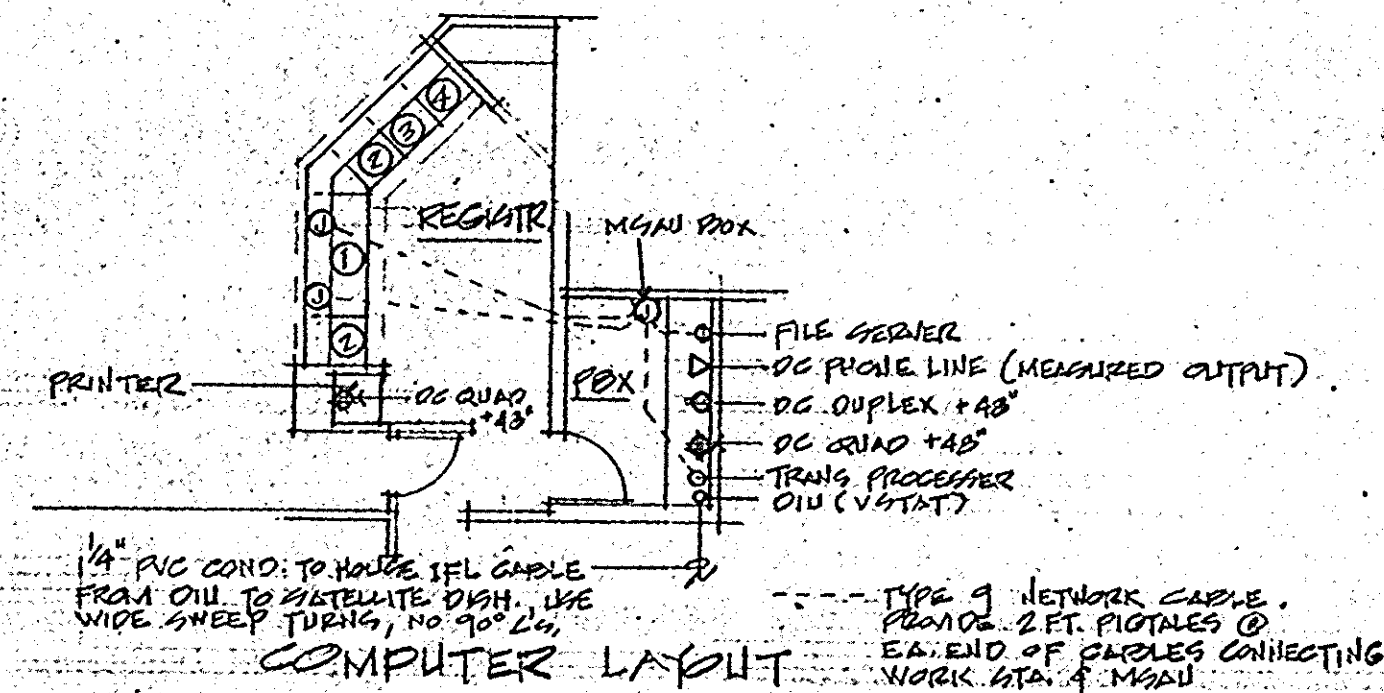


- 1 DIAL WORK STATION
2 CRT MODULE
3 PRINTER MODULE
4 PHONE CONSOLE MODULE
- OWNER TO INFORM CALL ACCOUNTING
SYS. VENDOR THAT HE WILL BE
INTERFACING W/ HMS.

REV. 3-27-73


COMMERCIAL/SERVICE AREA POWER PLAN	HAMPTON INN MONROE, LA		DESIGN CONSORTIUM HOTEL CONSULTANTS MEMPHIS, TENNESSEE	
	DATE	3-10-73	E-5	
	SCALE			
	JOB NO.			

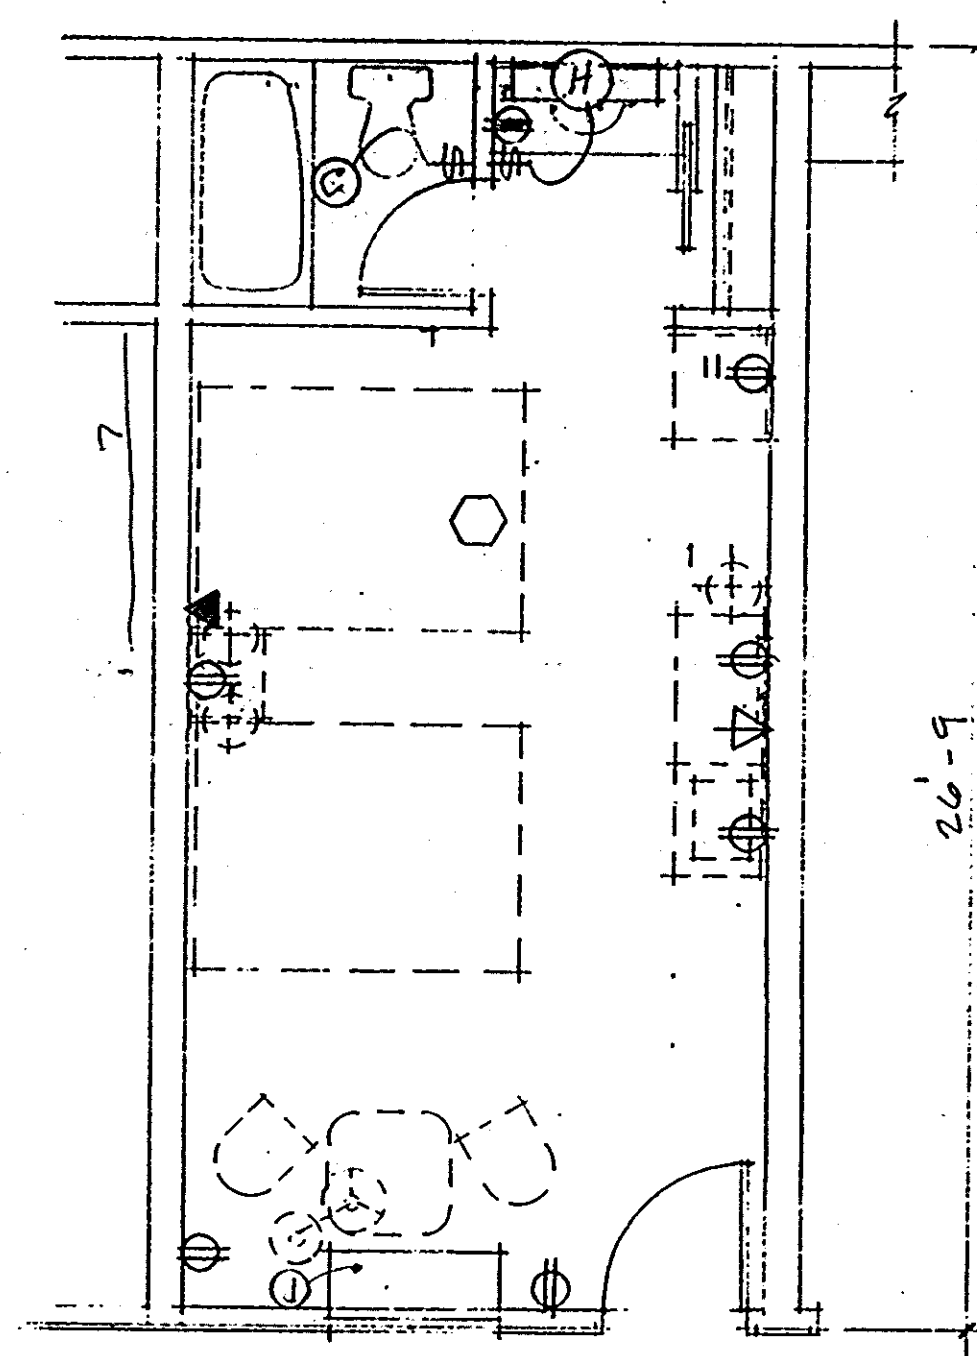


TYP. QUEEN - DBL. RM. (QD)
1/4" = 1'-0"

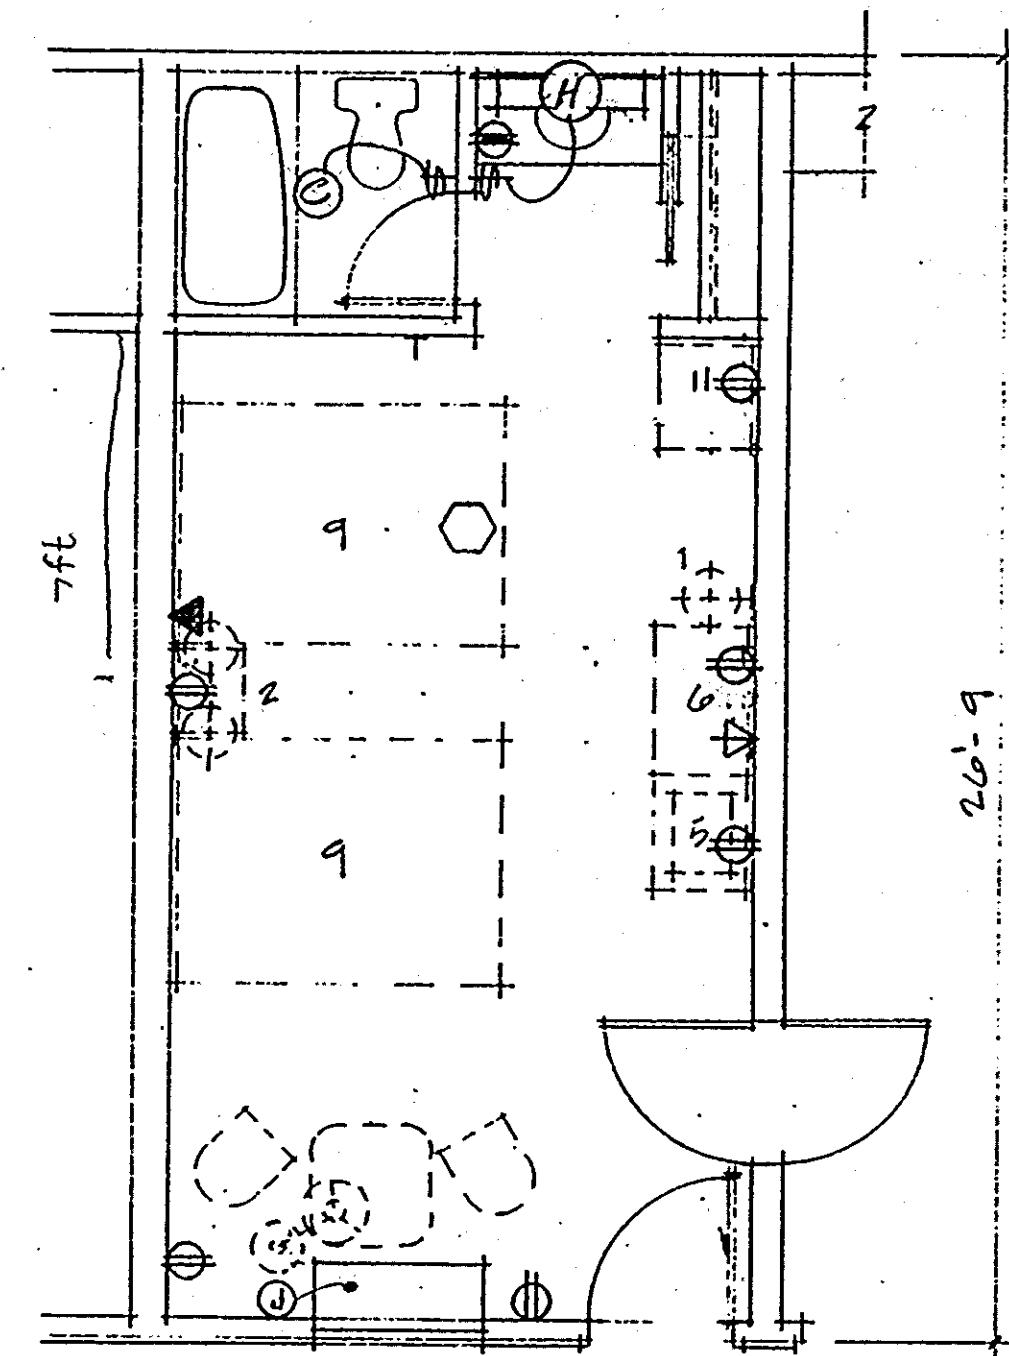


QUEEN-DBL. RM. (QD)
1/4"

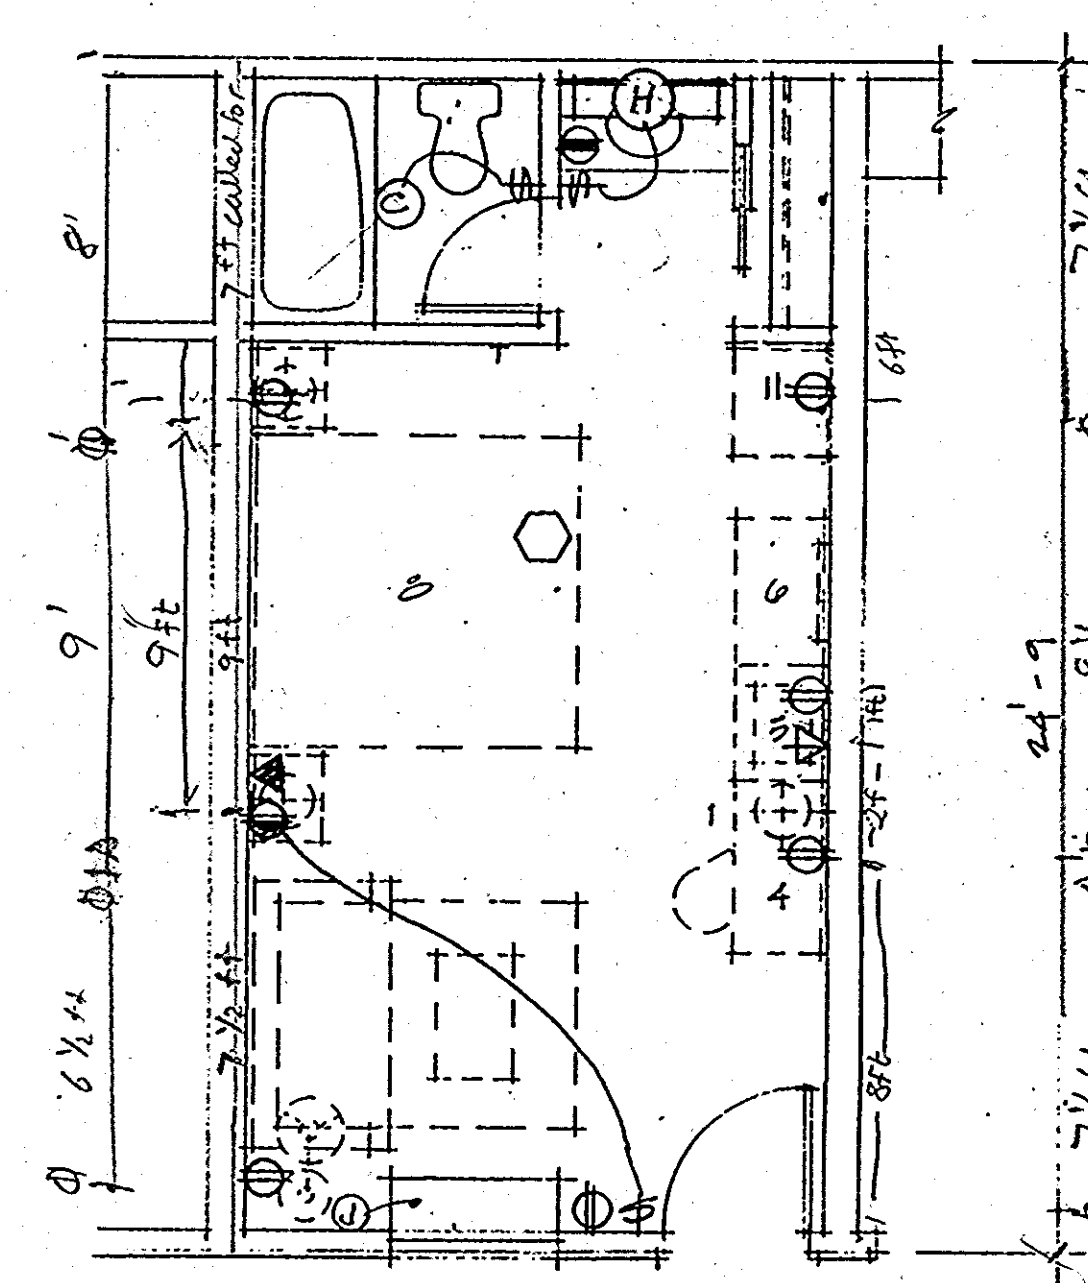


TYP. KING-SOFA RM. (KS)
1/4"

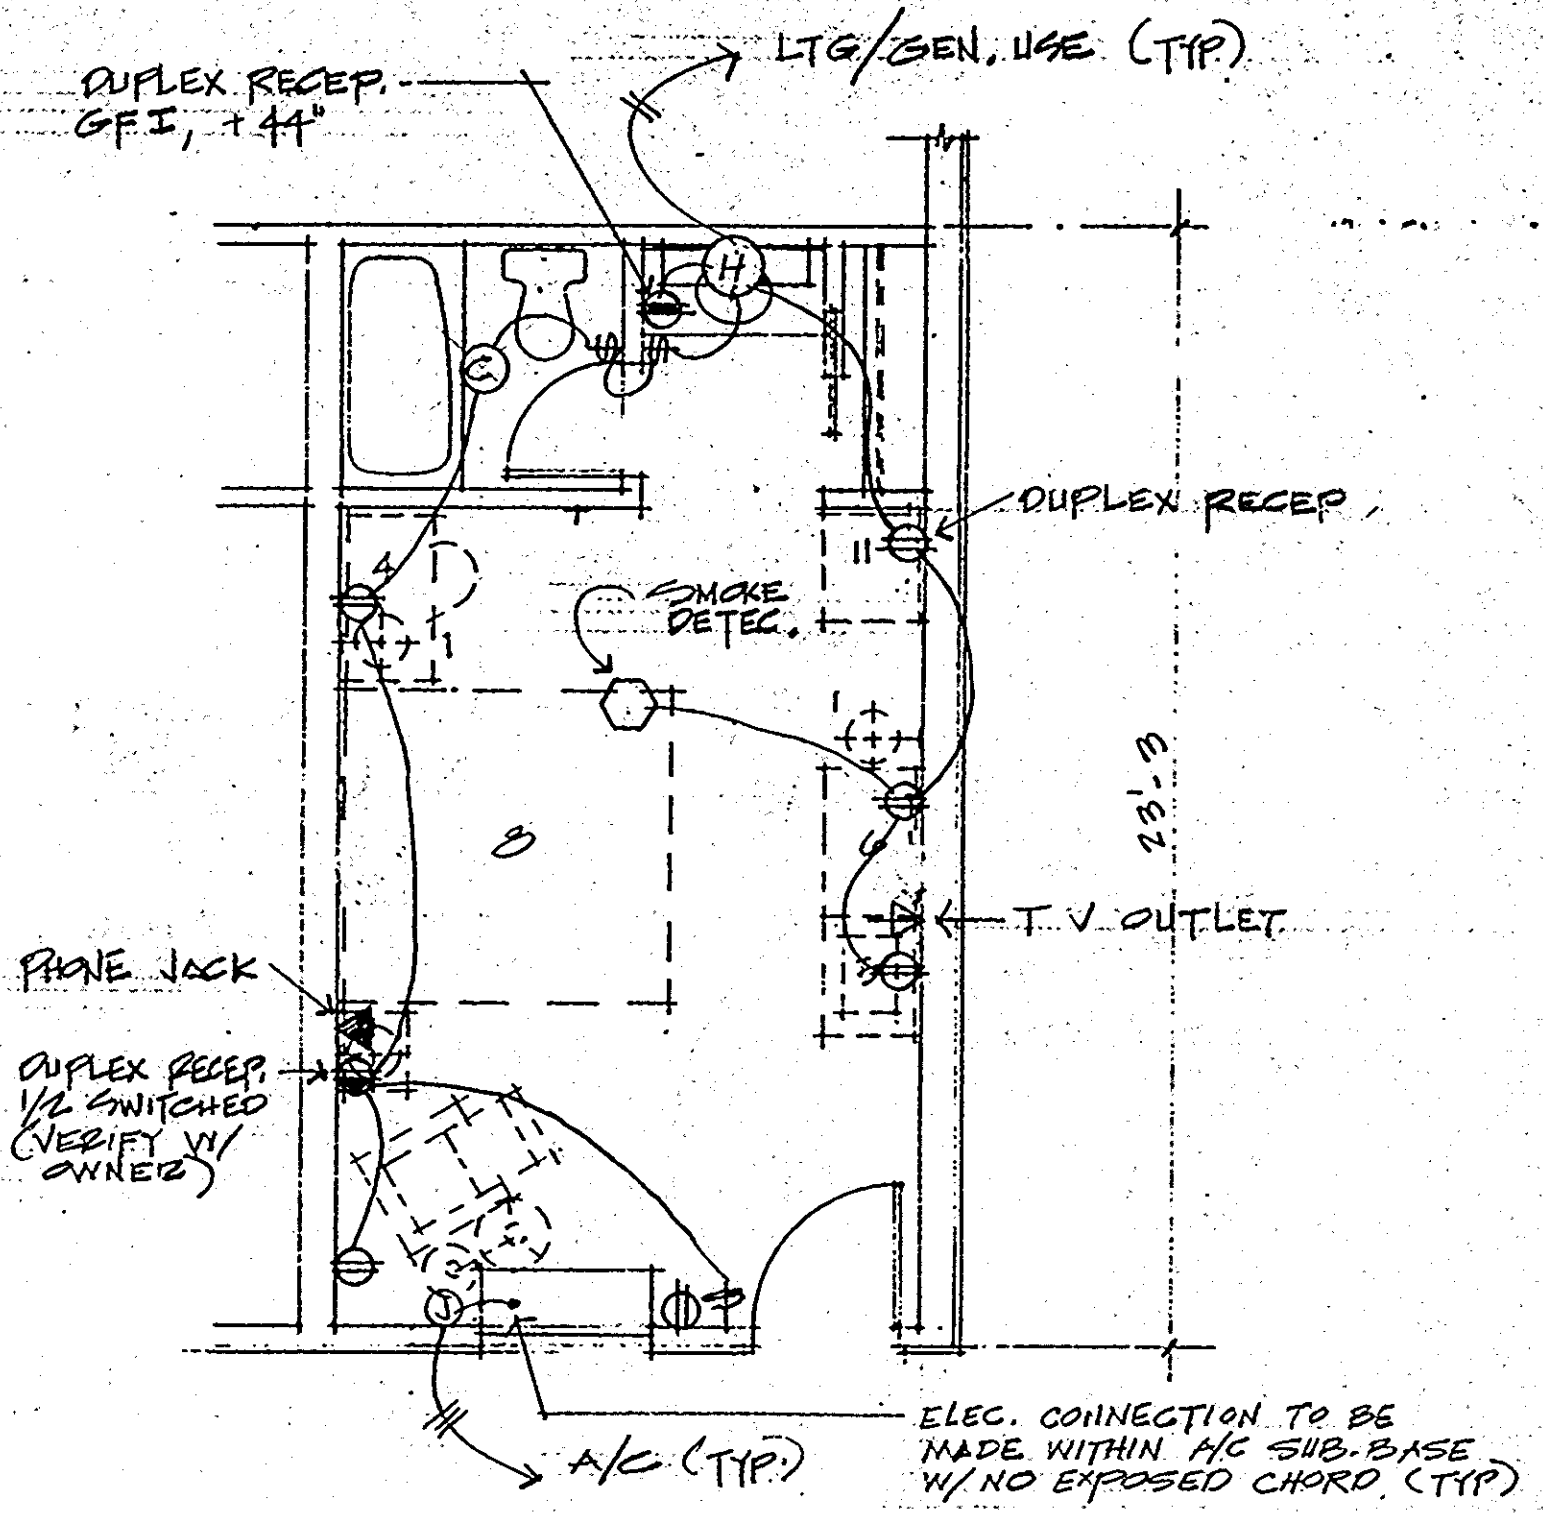

TYP. KING RM. (K)
1/4"

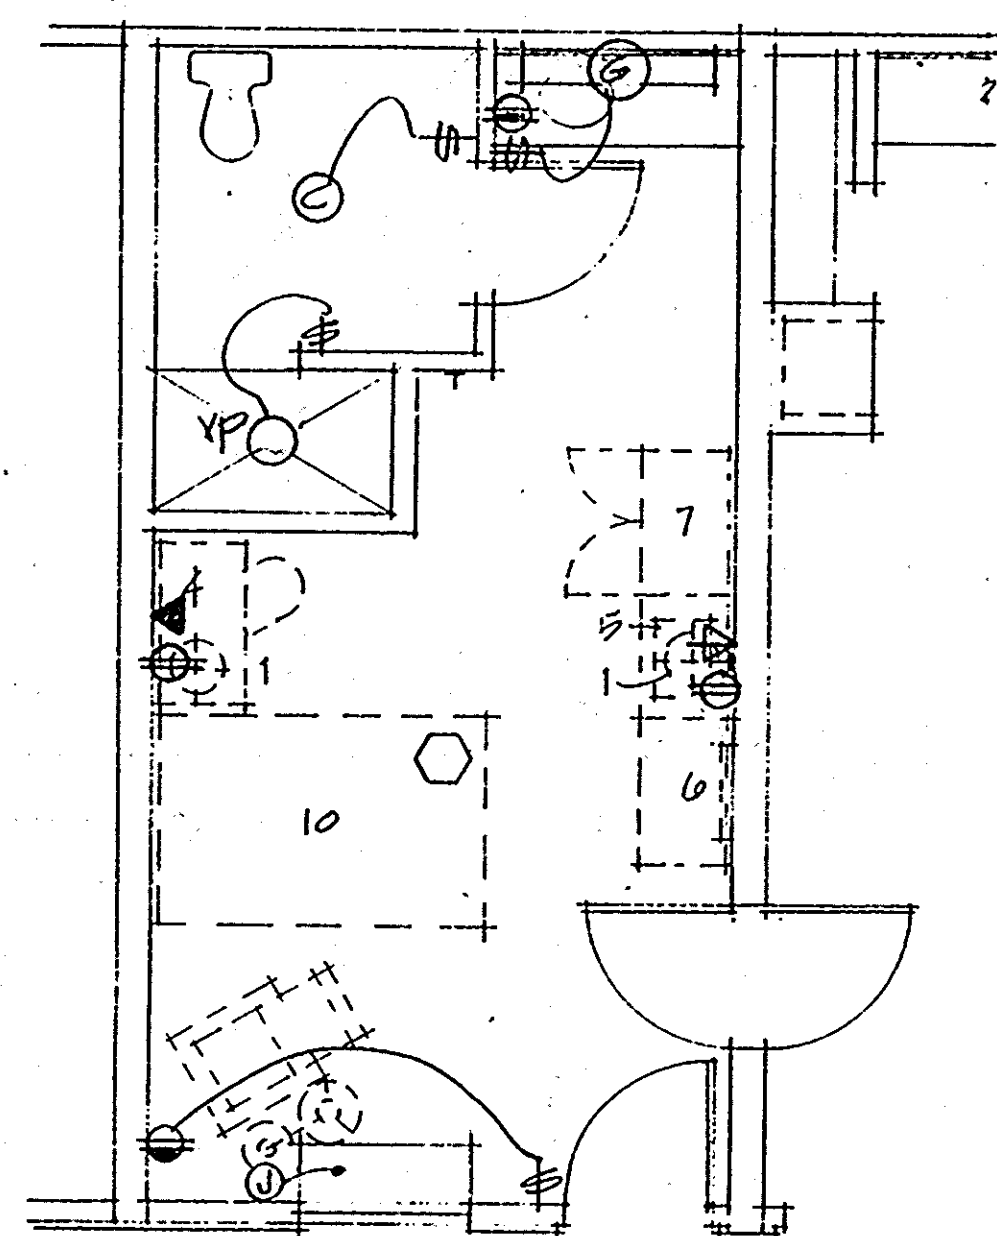

TYP. HANDICAP RM.
TYPE 1 (HC-1)
1/4"

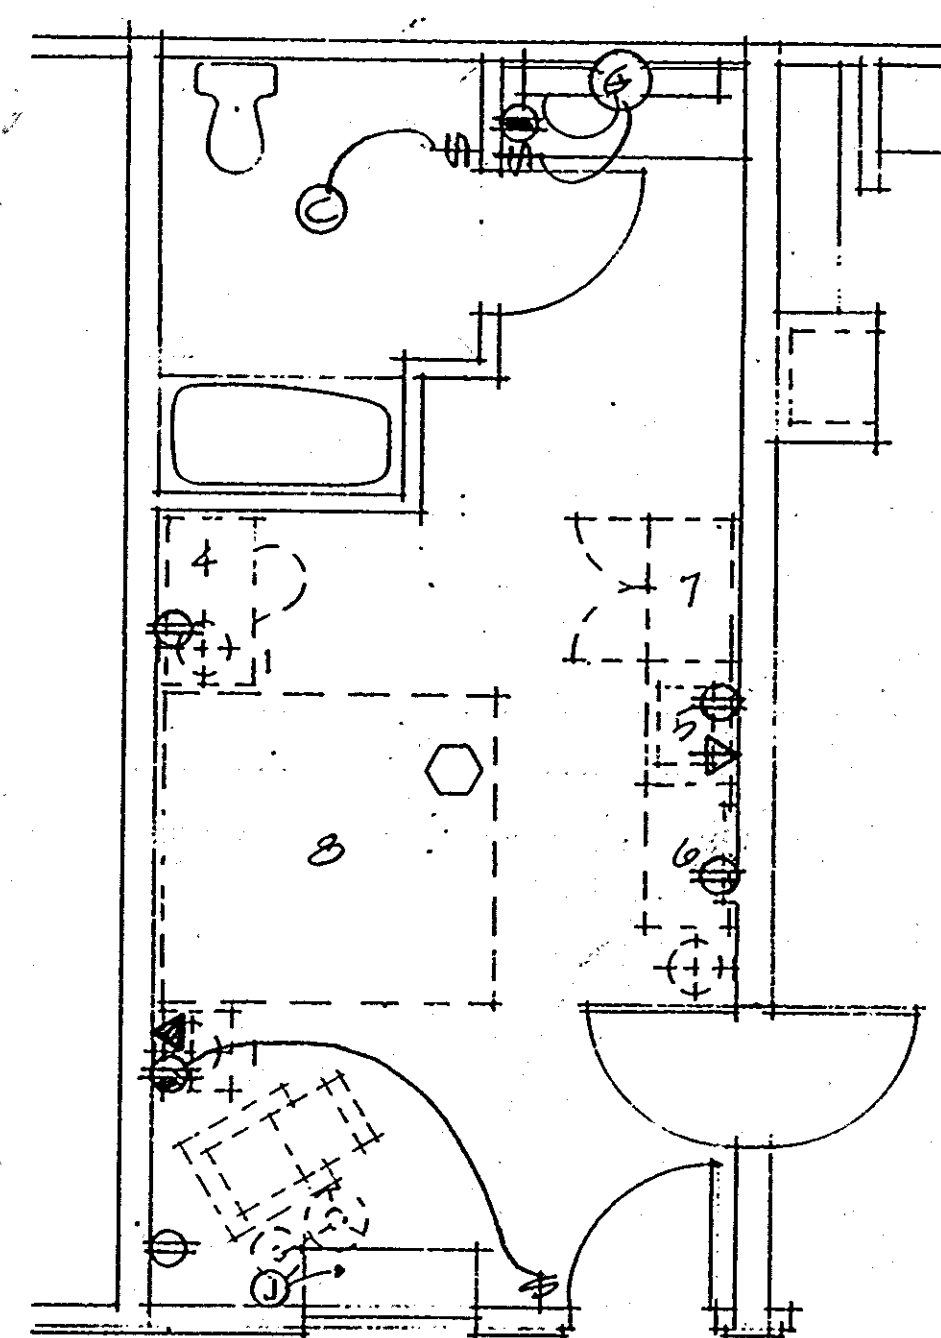

TYP. HANDICAP RM.
TYPE 2 (HC-2)
1/4"

FURNITURE LEGEND

1. WALL MTD. SINGLE LAMP
2. WALL MTD. DOUBLE LAMP
3. DESK LAMP
4. DESK
5. CHEST W/ TV ON TOP
6. LUGGAGE BENCH & WALL MIRROR
7. WARDROBE
8. KING BED
9. QUEEN BED
10. DOUBLE BED
11. CAB. FOR MIN. OVEN & REFR.

REV. 3-27-93

TYPICAL GUEST ROOMS	HAMPTON INN MONROE, LA			DESIGN CONSORTIUM HOTEL CONSULTANTS MEMPHIS, TENNESSEE	
	DATE	3-10-93		E-6	
	SCALE				
	JOB NO.				

ELECTRICAL NOTES

- ALL ELECTRICAL WORK SHALL BE PERFORMED IN STRICT ACCORDANCE WITH THE LATEST EDITION OF THE NATIONAL ELECTRICAL CODE AND ALL STATE AND LOCAL CODES.
- FIRE ALARM SYSTEM SHALL CONSIST OF VIBRATING HORNS PRODUCING 101 DB AT 10 FT. SMOKE DETECTORS PRODUCING 85 DB AT 10 FT. PULL STATIONS, CONTROL PANEL, 4 ZONE ANNUNCIATOR PANEL, AND STANDBY POWER SUPPLY WITH RECHARGEABLE BATTERIES. ALL COMPONENTS SHALL BE MONACO, OR EQUAL.
- THE INSTALLATION OF THE PROPOSED FIRE ALARM SYSTEM SHALL BE IN ACCORDANCE WITH NFPA #72A, 79 EDITION. WORKING DRAWINGS INCLUDING A COPY OF THE MANUFACTURER'S SPECIFICATION LITERATURE AND A DIAGRAM OF THE ANNUNCIATOR FACE PLATE WITH ZONING NOMENCLATURE, SHALL BE SUBMITTED PRIOR TO INSTALLATION, AND APPROVED BY ALL STATE & LOCAL FIRE MARSHALLS OFFICE.
- THE BUILDING FIRE ALARM SYSTEM SHALL BE CLEARLY HEARD THRU-OUT THE PROPOSED TENANT SPACE, REGARDLESS OF THE NORMAL NOISES OF OCCUPANCY.
- PROPOSED SPOT TYPE SMOKE DETECTORS FOR EACH ROOM SHALL BE INSTALLED IN ACCORDANCE WITH NFPA #72E, 1978 EDITION.
- CONTRACTOR SHALL COORDINATE WITH INTERIOR DESIGN DRAWINGS FOR EXACT LOCATION OF ALL RECEPTACLES AND LIGHT FIXTURES. ALL LIGHT FIXTURES SHALL BE AS SELECTED BY INTERIOR DESIGNERS.
- GROUNDING OF TELEPHONE EQUIPMENT SHALL BE MINIMUM 8'-0" ROD IN GROUND AND COMPLY WITH ALL CODES.
- CONTRACTOR SHALL PROVIDE ALL CONDUIT NECESSARY FOR ALL SERVICES INCLUDING TELEPHONE, TELEVISION, & FIRE ALARM.
- CONTRACTOR SHALL SUBMIT WIRING DIAGRAMS FOR APPROVAL PRIOR TO INSTALLATION.
- ALL EXTERIOR LIGHTS SHALL BE CONTROLLED FROM THE FRONT DESK AREA.
- ELECTRICAL CONTRACTOR SHALL PROVIDE & INSTALL ALARM SYSTEM FOR ALL TELEVISIONS AND ENTRY DOORS AS REQUIRED.
- ELECTRICAL CONTRACTOR SHALL CONFER W/ALL TRADES REGARDING ELECTRICAL REQUIREMENTS & COORDINATE AS NECESSARY.
- ALL LIGHT FIXTURES TO BE SELECTED & APPROVED BY OWNER. MODEL NOS. ARE FOR INTENT & BIDDING ONLY.
- CONVENIENCE OUTLETS LOCATED IN BATHROOMS, AT KITCHEN COUNTERS, IN LAUNDRY & OUTSIDE, & ALL OTHER WET LOCATIONS SHALL BE G.F.I.


LIGHT FIXTURE SCHEDULE

MARK	DESCRIPTION	TYP. LOCATION
A	RECESSED DOWNLIGHT, LITHONIA AG-AR, CLEAR ALZAK REFL. W/ 1-75W INCAND. LAMP	LOBBY (0120)
B	SURFACE MTD. CYLINDER DOWNLIGHT, LIGHTOLIER 1013 AG CLEAR ALZAK REFL. W/ 1-75W. INCAND. LAMP	LOBBY, REGISTRAR'S
C	SURFACE MTD. CIRCLINE FLUORESCENT. PROGRESS PT110-10 W/ 1 PL-13	GUEST RM. BATH
D	SURFACE MTD. 1'x4' FLUORESCENT. METALUX 44 240-120V-LE3	REGISTRAR'S, BREEZEWAY
E	RECESSED 2'x2' FLUORESCENT. METALUX 242UGA-120V-LE3-LCWM-A3/B-2/130	PUBLIC TEL. OFFICE LOUNGE
F	SURFACE MTD. 2'x2' FLUORESCENT. METALUX 242UGA-120V-LE3	PUBLIC TEL. OFFICE LOUNGE
G	4' STRIP FLUORESCENT. TRU-LITE 4-240R	UTILITY, LAUNDRY, EGG CRATE @ VANITY
H	3' STRIP FLUORESCENT. TRU-LITE 3-230T	VANITY
I	4' WALL MOUNTED DECORATIVE FLUORESCENT. TRU-LITE B-339-240-PB	CHARGE
J	INCAND. KEYLESS SOCKET, 100 W.	EXTERIOR WALKWAY
K	WALL MOUNTED 6'x12" FLUORESCENT. AMERICAN FLUORESCENT CO. TP4013	ENT. CANOPY, STAIR
L	RECESSED DOWNLIGHT, JUNO H705 HPS 70-1030, 70W HPS E17/B17	SUPPIT. (15'14" OC)
M	SURFACE MTD. 2'x4' FLUORESCENT. TRU-LITE DE-440R24-FL	WORK AREA, OFFICE
N	FLOODLIGHT, MCGRAW-EDISON WS 240-1-B2-LL	PARKING, DRIVES, FEATURED AREAS
O	AREA LIGHT, MUIRFIELD MUX-400 MH 30' # ALUM. POLE W/ BRONZE PAINTED FINISH	PARKING & DRIVES
P	POST-TOP LIGHT, W.F. HARRIS 1050-0W-FZ-30 HPS - HPF-120V	FENCE POSTS
X	CEILING MTD. EXIT LIGHT, SURE-LITES UN-1-SRW (RED LETTERS)	
10	EMERGENCY LIGHT/BATTERY PACK, HALO/SURE-LITES CU-1	
20	SMOKE DETECTOR	INTERLOCK W/ FIRE ALARM SYSTEM
40	HEAT DETECTOR	

2.0. 69

PANELBOARD SCHEDULE

PANEL	BUSS/MAINS	BREAKERS	NO.	LOAD
A	225 A 208/30 4W	20/1	40	RM. LIGHTING & GEN. USE
B	225 A 208/30 4W	20/1	40	RM. LIGHTING & GEN. USE
C	225 A 208/30 4W	20/1 20/2 30/3 60/3	16 4 6 1	COMM'L. LIGHTING, GEN. & EQUIP., OUTSIDE LIGHT
OL	100 A 208/30 4W	20/2 20/1	2 10	OUTSIDE LIGHTING
K, L, M	225 A 208/30 3W	20/2	20	H.V.A.C.
N	225 A 208/30 4W	20/2 30/3	12 2	H.V.A.C. & EQUIP.
MOP	1200 A 208/30 4W	400/3 225/3	2 2	PANELS

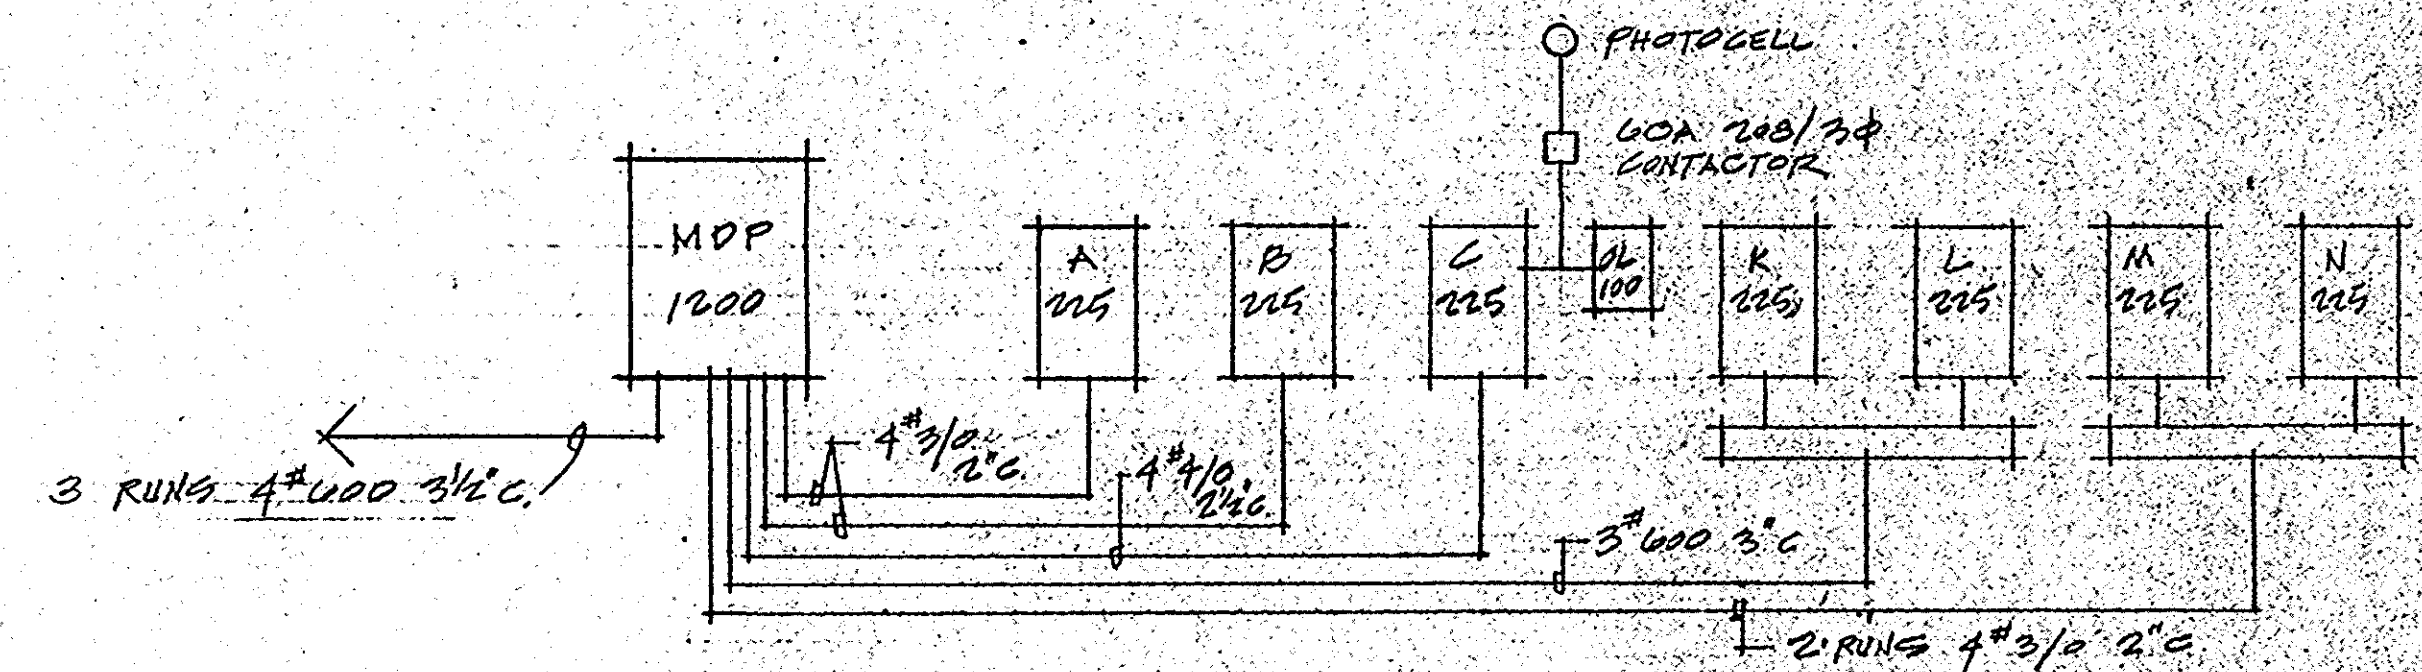

ELECTRICAL RISER DIAGRAM

PROVIDE SEPARATE PANEL (NOT SHOWN) FOR COMPUTER SYSTEM. DEDICATED CIRCUITS @ FRONT DESK.

REV. 3-27-93

HAMPTON INN MONROE, LA		DESIGN CONSORTIUM HOTEL CONSULTANTS MEMPHIS, TENNESSEE	
NOTES, SCHEDULES AND PANEL DIAGRAM	DATE	3-10-93	E-7
	SCALE		
	JOB NO.		