

OWNER

H.L. PATEL
CONTACT: VIJAY PATEL
1133 PEBBLEWOOD WAY
SAN MATEO, CA 94403
TEL: (415) 570 6970

PROJECT

PROPOSED 37-UNIT MOTEL
2834 EL CAMINO REAL
REDWOOD CITY, CA 94063

SHEET TITLE

SECOND FLOOR
PLUMBING PLAN

SHEET NO.

P-3

DF

DRWN

A. ARRILLO

CHKD

A. CABRERA

SCALE

1/8"=1'-0"

DATE

SEP 15, 1992

JOB NO.

92002

FILE NAME

RCA-23

SEAL OF THE STATE OF CALIFORNIA
ARTURO O. CABRERA
P.E.
010569

ARTURO O. CABRERA, P.E.
2116 W. Main Street, Ste. 1
San Mateo, California 94403
Professional Engineer

I HAVE REVIEWED THE CURRENT CALIFORNIA ENERGY
CONSERVATION STANDARDS FOR RESIDENTIAL
BUILDINGS. IN MY PROFESSIONAL JUDGEMENT, THE
DESIGN ON THIS SET OF PLANS AND SPECIFICATIONS
WILL CONFORM SUBSTANTIALLY WITH TITLE 24
SUBCHAPTER 7 & 8, SECTIONS 150 & 151.

PLUMBING LEGEND

SOIL AND WASTE PIPING

SANITARY VENT PIPING (C.W.)

COLD WATER PIPING (C.W.)

HOT WATER PIPING (H.W.)

GAS PIPING

PIPE ELBOWS-HORIZ.

PIPE ELBOWS-HORIZ. DOWN UP

FLOOR DRAIN

CLEANOUT

HUB DRAIN-OPEN RECEPTACLE

W. FUNNEL


VENT THRU ROOF

GATE VALVE


GATE VALVE INVERTICAL

FLOOR SINK

SECOND FLOOR PLAN
PLUMBING PLAN

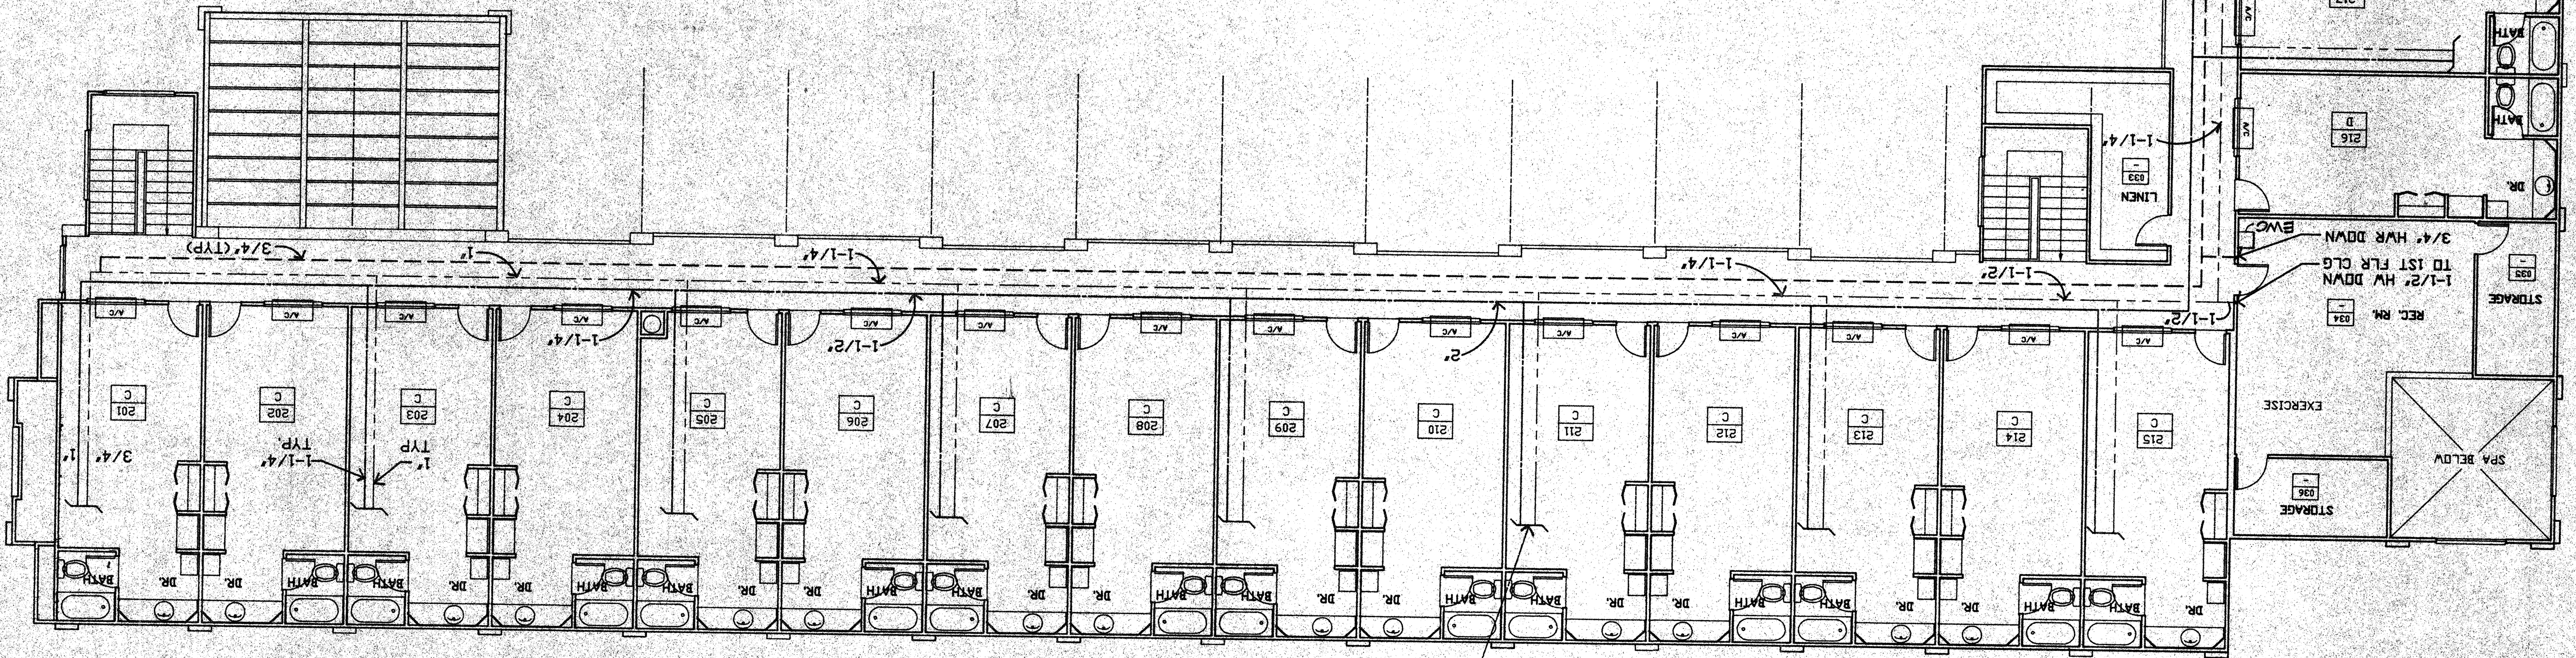

SEE 1/4\"/>

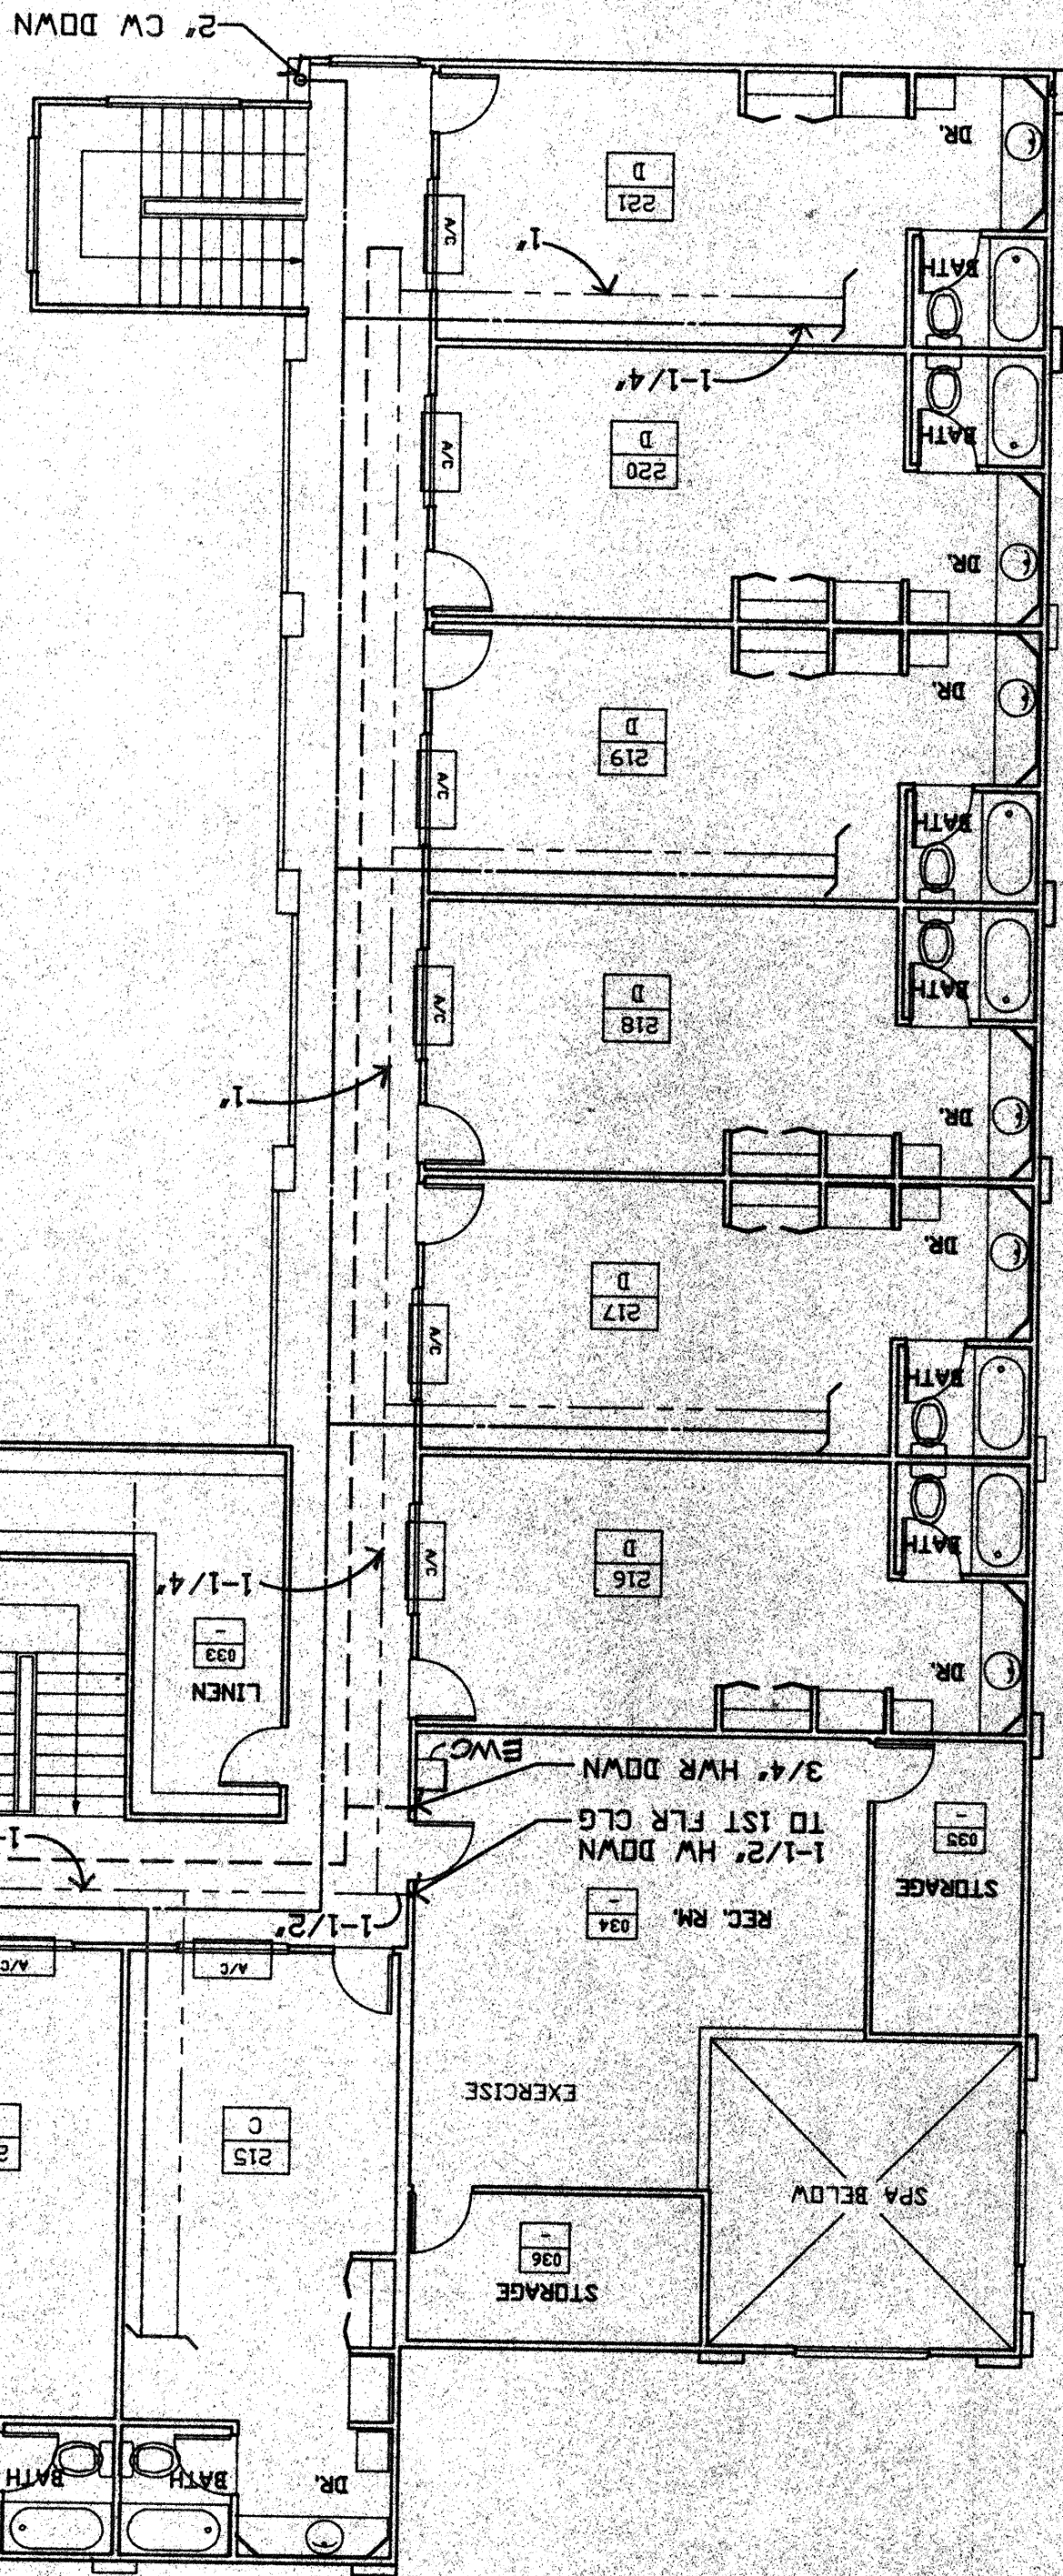

SHEET NOTES

LEGEND