



MARK	FIXTURE	CW	HW	W	VT	DESCRIPTION
WC/1	WATER CLOSET	1"	-	3"	2"	AM. STD. #2293, 203, WHITE, SIBON JET, ELONGATED, OLSONITE#34 SEAT, FITTINGS, GASKET, SUPPLY
WC/2	HANDICAP WTR CLOSET	1"	-	3"	2"	AM. STD. #2168, 128, WHITE, SIBON JET, ELONGATED, OLSONITE#34 SEAT, FITTINGS, GASKET, SUPPLY
LAV/1	LAVATORY	1"	1"	2"	2"	SEE ARCHITECTURAL PLANS FOR DETAILS
LAV/2	LAVATORY	1"	1"	2"	2"	AM. STD. BENTLY#0373, 050, WHITE, MOEN LEGEND #4400 SINGLE LEVER, FITTINGS, SUPPLIES, CONCEALED ARM
T/S	TUB SHOWER	1"	1"	2"	2"	AM. STD. #2605, SER/2607, SER, ACID RESIST, SLIP RESIST, FITTINGS, MOEN#3181 SHOWER VAL, FITTINGS, DRAIN, SPOUT, LOW FLOW HEAD
SHR	SHOWER (HANDICAP)	1"	1"	2"	2"	FLORESTONE #148-52, 1/2" ONE PIECE SHOWER STALL, COMPLETE W/ PRESSURE BALANCE MIX VALS, HAND HEED SHOWER SEAT, GRAB BAR
SINK	SINK	1"	1"	2"	2"	ELKAY#PSR1918, 1-COMPL, SELF RIMMING, ELKAY FAUCET#4162, 20 GA FITTINGS, SUPPLIES, DRAIN
LS	LAUNDRY SINK	1"	1"	2"	2"	AM. STD. #7602, 055, 1/2" ACID RESIST, #8340, 242 FAUCET, #7602, 030 FRAME, #8303, 026 DRAIN, FITTINGS, SUPPLIES
WH	WATER HEATER	1-1/2"	-	-	-	TELEDYNE TANKS#W4400C, 400,000 BTUH INPUT, COMPLETE W/235 GAL. TANK ASME APPROVED, B/G 2" IN-LINE PUMPS
FD	FLOOR DRAIN	2"	-	-	2"	JR SMITH#2010A-P, NICKEL BRONZE STRAINER, CAST IRON BODY
FS	FLOOR SINK	2"	-	-	2"	ZURN#ZN-1810 CAST IRON FLOOR SINK W/ NICKEL BRONZE GRATE 1/2 GRATE
HB	HOSE BIBB	1/2"	-	-	-	WOODFORD #14CP W/ WATTS 8B NON-REMOVABLE VACUUM BREAKER, FREEZE PROOF

TYPICAL PLUMBING PLAN - TYPE 1
NON-HANDICAP UNITS

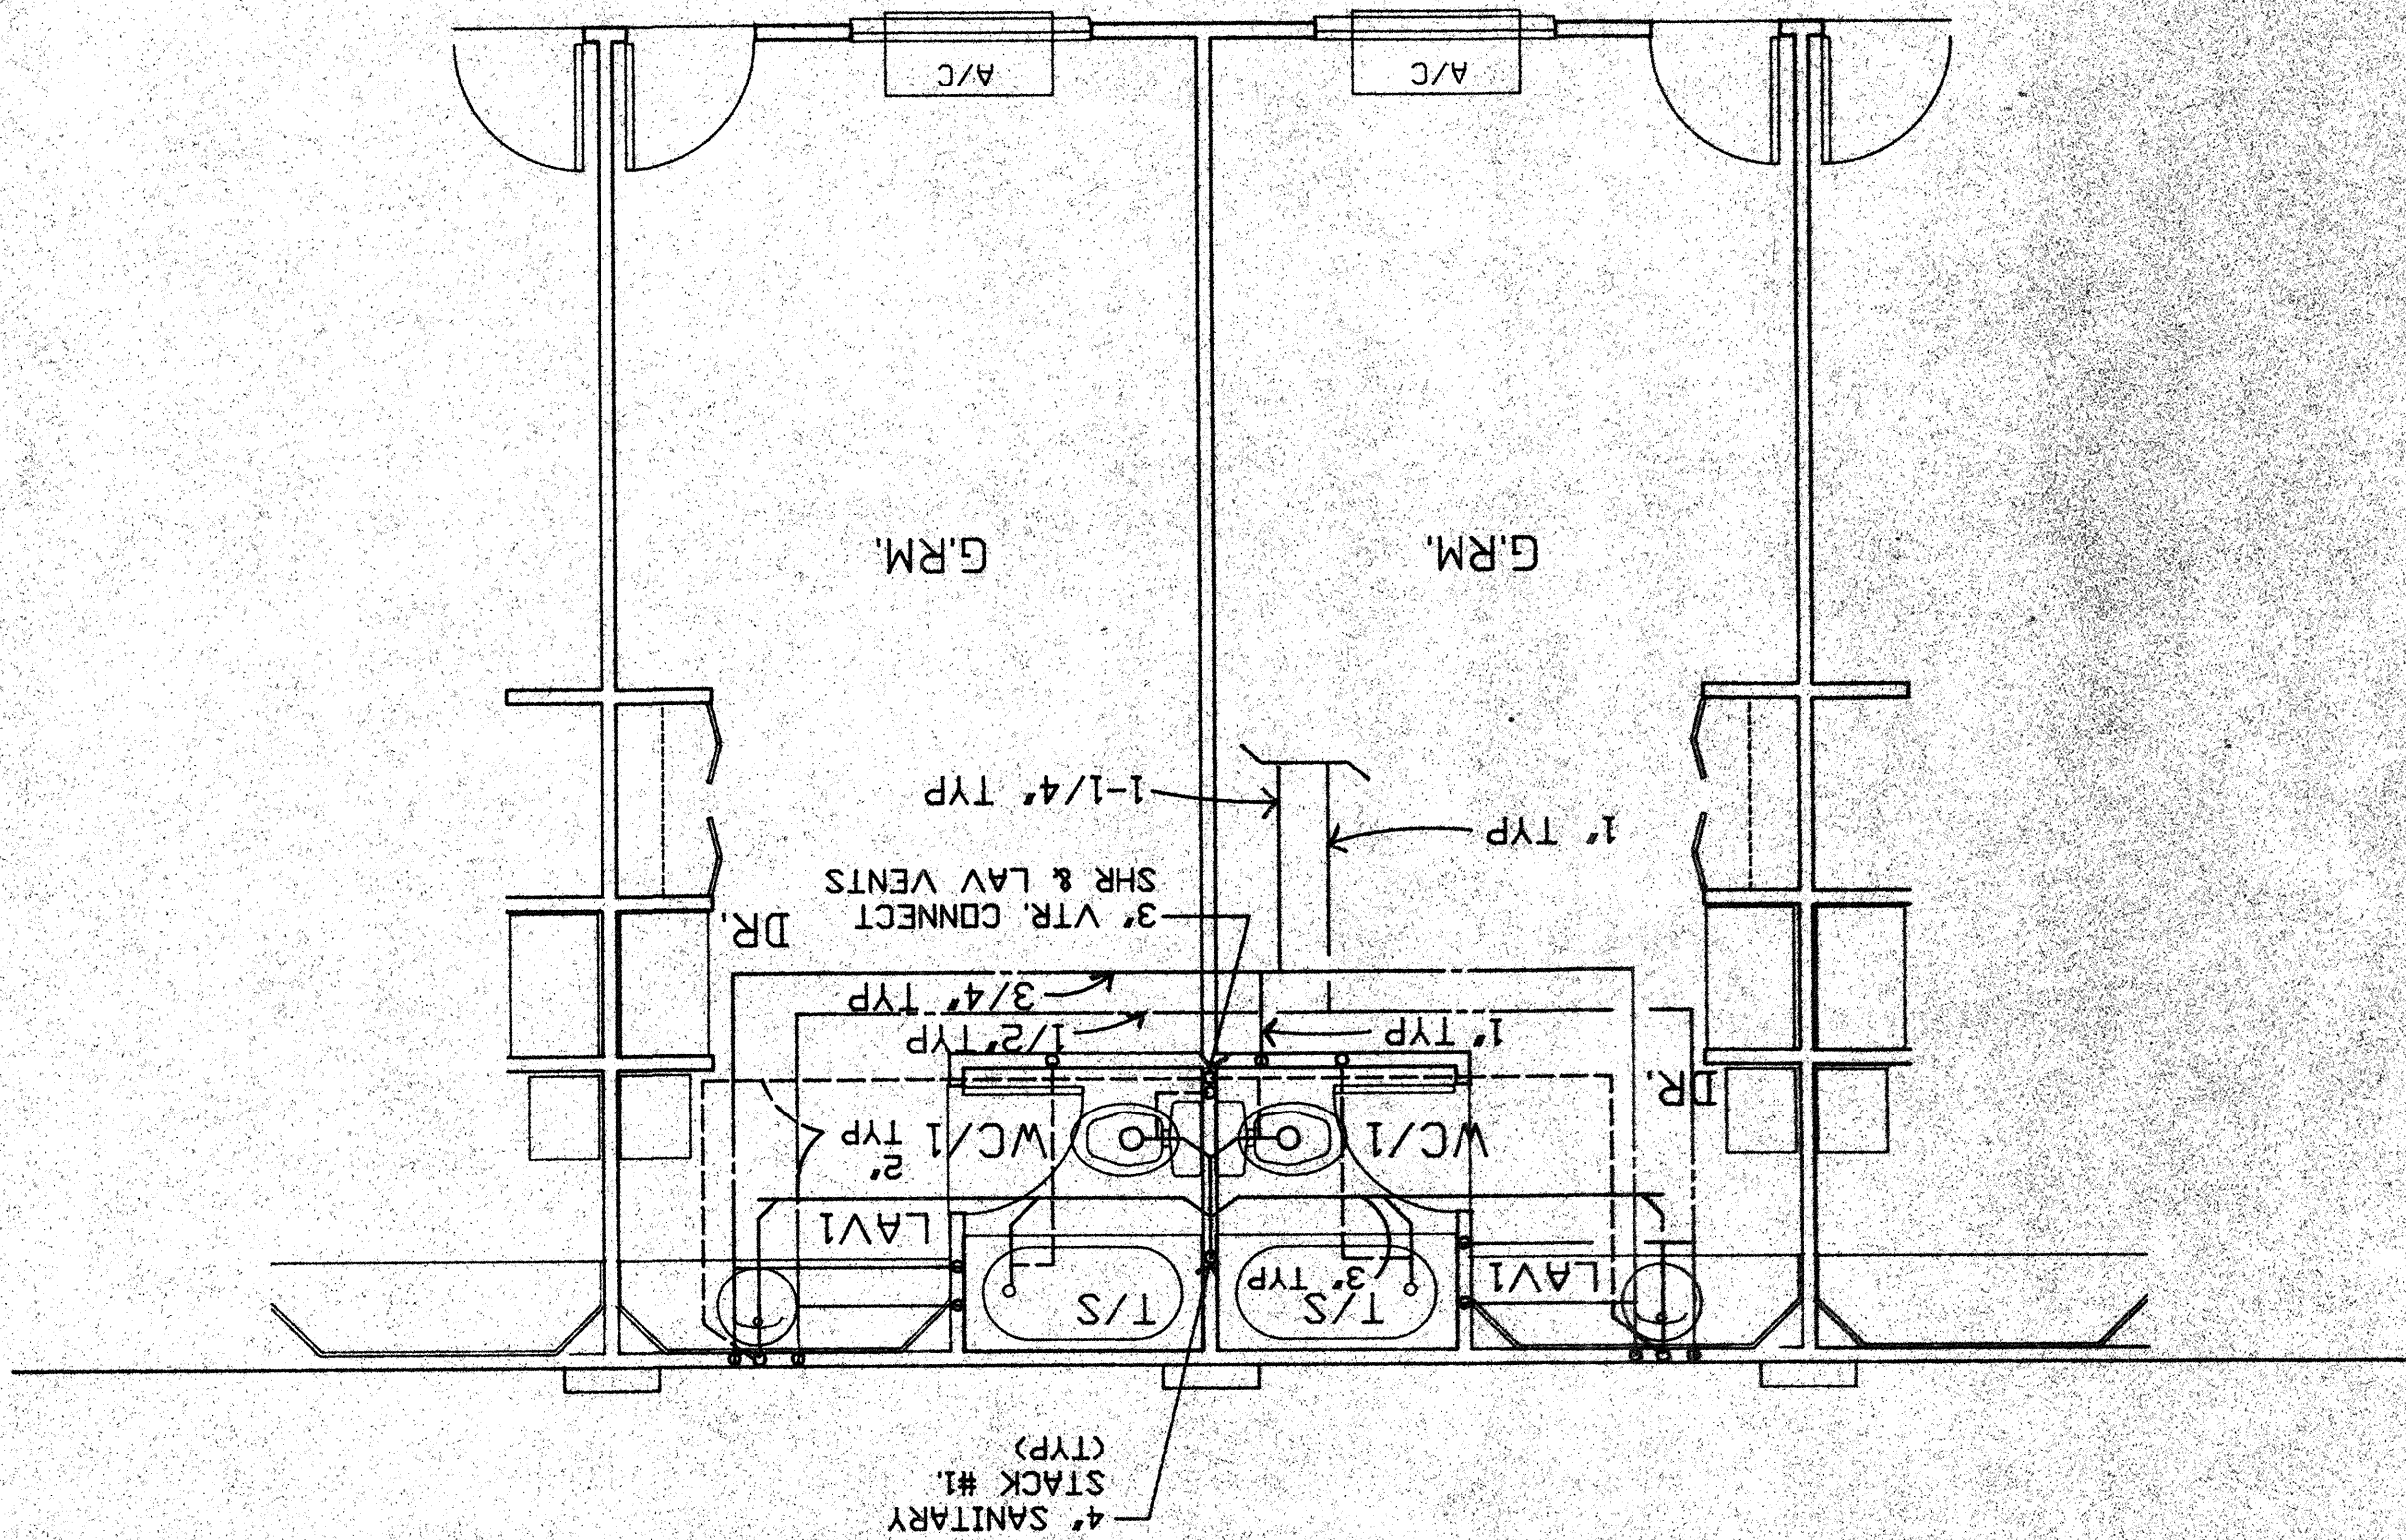


I HAVE REVIEWED THE CURRENT CALIFORNIA ENERGY CONSERVATION STANDARDS FOR RESIDENTIAL BUILDINGS. IN MY PROFESSIONAL JUDGEMENT, THE DESIGN ON THIS SET OF PLANS AND SPECIFICATIONS WILL CONFORM SUBSTANTIALLY WITH TITLE 24 SUBCHAPTER 7 & 8, SECTIONS 150 & 151.

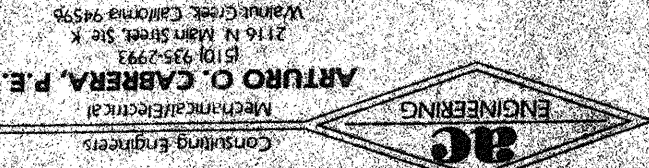

ITEM	QTY	BTUH	CFH	PIPE	REMARKS
WH/1	1	400,000	363	1-1/2"	200' FROM GAS METER TO MOST REMOTE GAS
WH/2	1	400,000	363	1-1/2"	TO MOST REMOTE GAS
CLOTHES DRYER #1	1	165,000	150	1-1/2"	APPLIANCE, ALSO PROVIDE QUAKE MASTER
CLOTHES DRYER #2	1	120,000	109	1"	SEISMIC GAS SHUT-OFF VALVE
SPA HEATER	1	325,000	295	1-1/2"	SEISMIC GAS SHUT-OFF VALVE
TOTAL		1281		3"	

TYPICAL PLUMBING PLAN - TYPE 2
HANDICAP UNITS

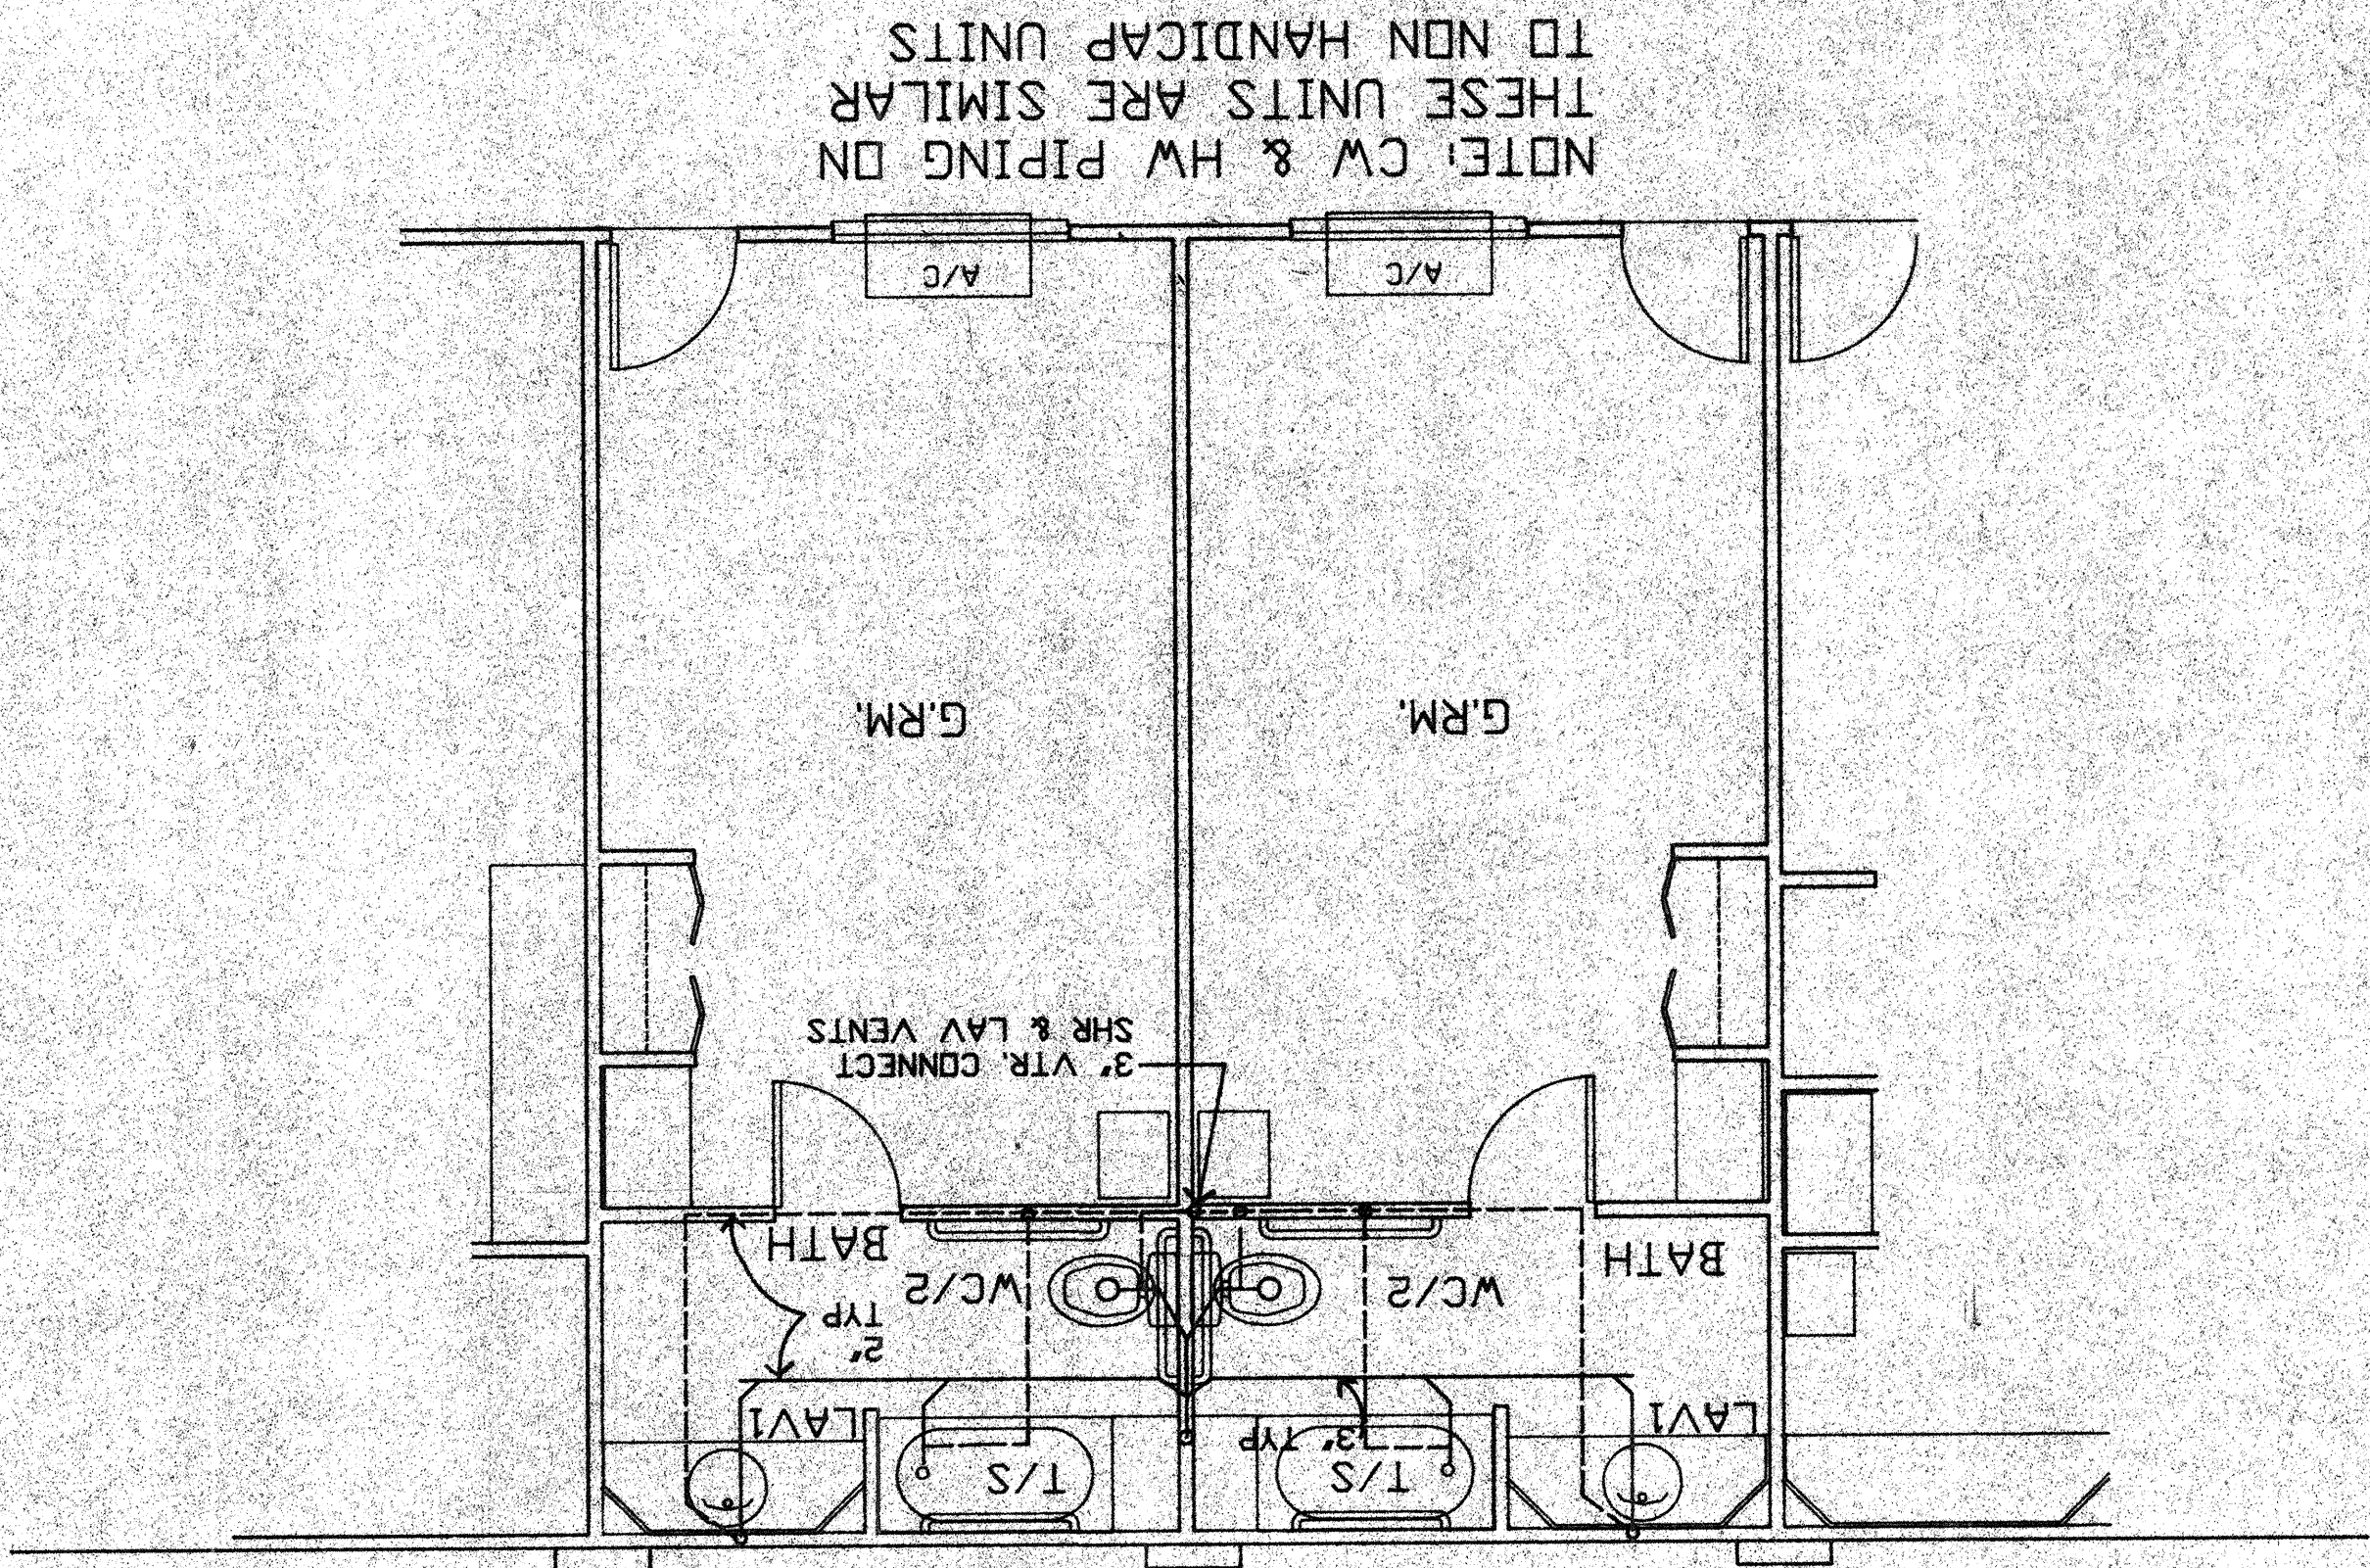

FILENAME	RCA-2B
JOB NO.	92002
DATE	SEP 15, 1992
SCALE	1/4"=1'
CHKD	A. CABRECA
DRAWN	A. CABRECA
SHEET NO.	P-4

PLANS
TYPICAL PLUMBING

PROJECT
PROPOSED 37-UNIT MOTEL
2834 EL CAMINO REAL
REDWOOD CITY, CA 94063

OWNER
H.L. PATEL
CONTACT: VIJAY PATEL
1133 FEEBLEWOOD WAY
SAN MATEO, CA 94403
TEL: (415) 570 6970

SKL ARCHITECTURE & PLANNING
3018 Willow Pass Road, Suite 206
Concord, California 94519
Phone 510 680 2711
Fax 510 680 2717

SHEET NOTES

LEGEND