

LEGEND

- SPECIAL OUTLET MATCH A/C PLUG
- SMOKE DETECTOR
- BUT SIGN IN GREEN LETTERS ON WHITE PAGE IN BATTERY PACK SUBTRON - WNR - ET-B-16

SHEET NOTES



SKL ARCHITECTURE & PLANNING
3018 Willow Pass Road Suite 206
Concord, California 94521
TEL : (415) 570 6970
FAX 510 680 2717


OWNER
H.L. PATEL
CONTACT: VIJAY PATEL
1133 PEBBLEWOOD WAY
SAN MATEO, CA 94403
TEL : (415) 570 6970

PROJECT
PROPOSED 37-UNIT MOTEL
2834 EL CAMINO REAL
REDWOOD CITY, CA 94063

SHEET TITLE

1ST FLOOR POWER
& LIGHTING PLAN



NORTH	BRVN	A. ARRILLO	SHEET NO.
	CHCD	A. CABRERA	E-1A
	SCALE	1/8"=1'-0"	DATE
		DCT. 7, 1998	JOB NO.
		9802	FILENAME
		RCALBE	DF

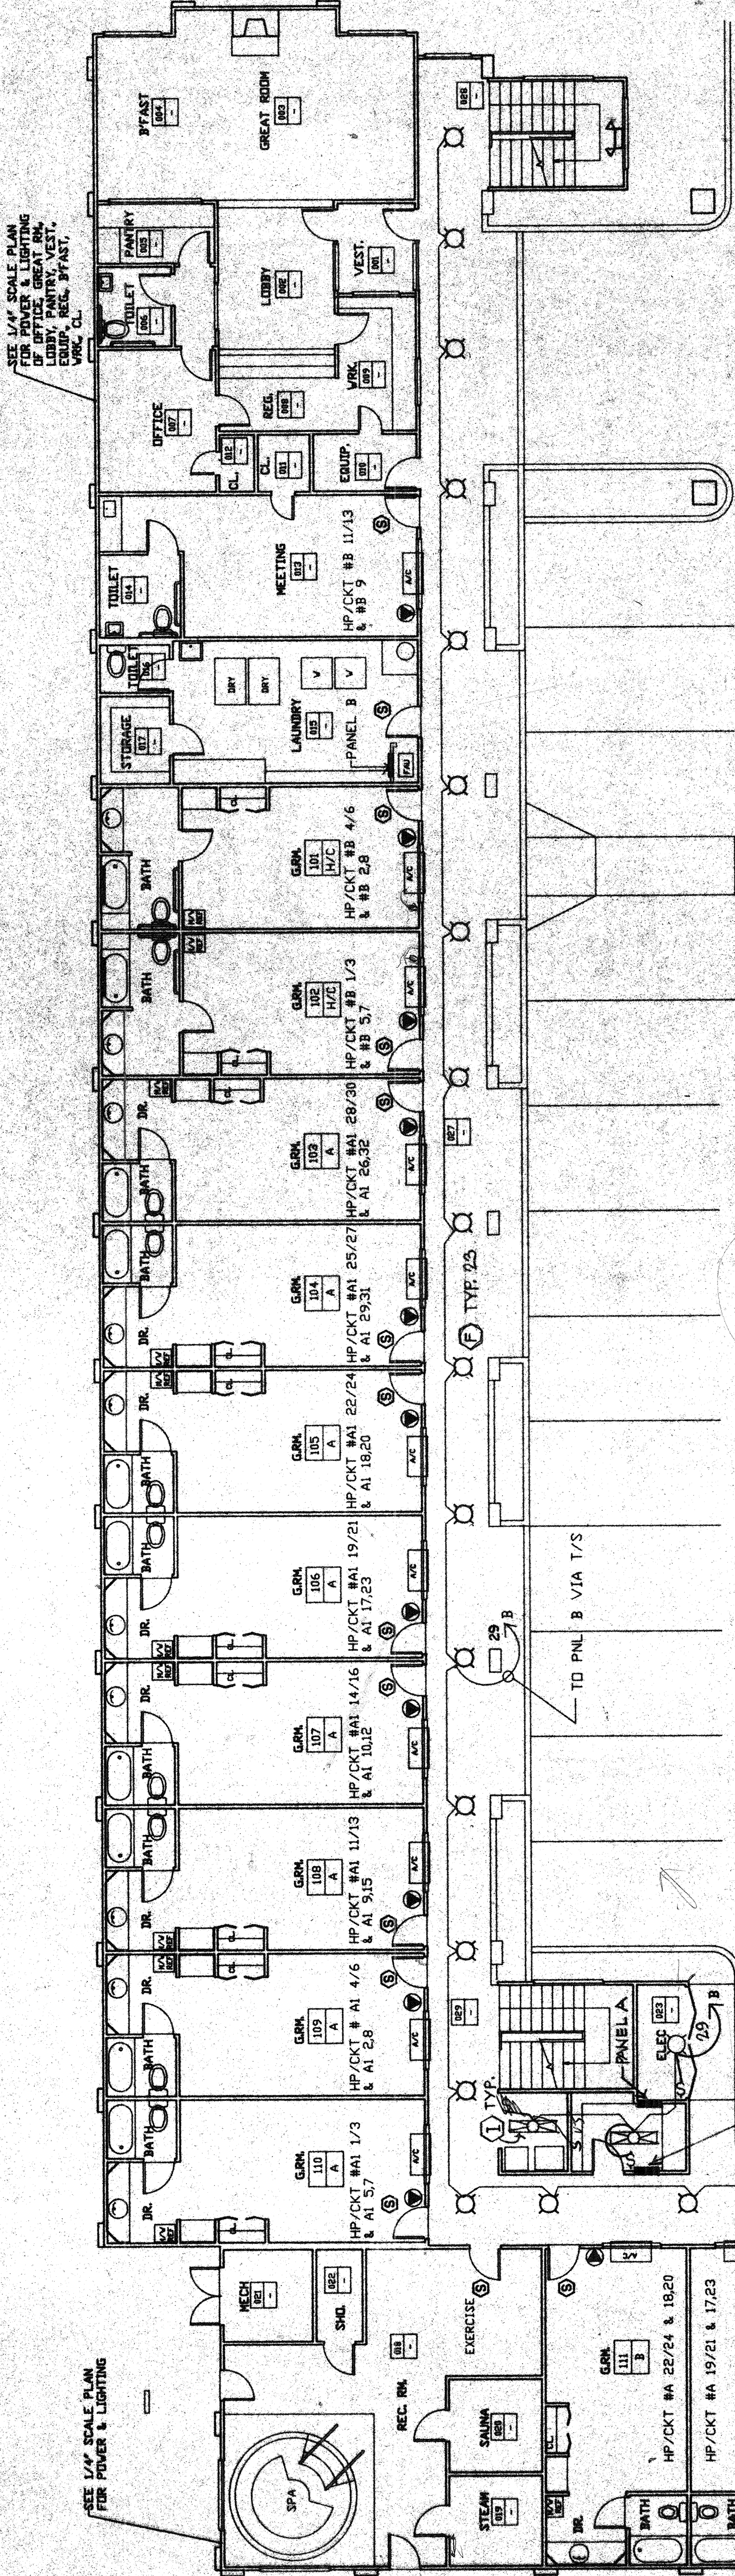

FIRST FLOOR PLAN
POWER AND LIGHTING

- INSTALL IN ACCORDANCE WITH MANUFACTURER'S INSTRUCTIONS AND IN COMPLIANCE WITH ALL APPLICABLE CODES AND ORDINANCES.
- LOCATE APPROPRIATE J-BOX 11'-0" ABOVE FINISHED GRADE.
- LOCATE POLE ON PILLASTER. ENSURE FINAL MOUNTING HEIGHT IS 10'-0" ABOVE FINISHED GRADE.
- OPTICAL CHAMBER ORIENTATION IS CRITICAL. ROTATE AS REQUIRED TO COMPLY WITH ORIENTATION INDICATED ON THE SITE LIGHTING PLAN.
- INSTALL 8'-8" (ON CENTER) ABOVE FINISHED GRADE.
- INSTALL ON WALL AT MAXIMUM AVAILABLE HEIGHT ABOVE FINISHED GRADE.
- INSTALL 8'-0" (ON CENTER) ABOVE FINISHED GRADE.
- AFTER-DARK AIMING IS REQUIRED TO ACHIEVE MAXIMUM LIGHT-WASH UNIFORMITY.
- SPECIFIED MANUFACTURER IS LOCATED AT: 2002A SOUTH GRAND AVENUE, SANTA ANA, CA 92782; TELEPHONE (714) 641-0310; FAX (714) 641-0944.

I HAVE REVIEWED THE CURRENT CALIFORNIA ENERGY CONSERVATION STANDARDS FOR RESIDENTIAL BUILDINGS IN MY PROFESSIONAL JUDGEMENT, THE DESIGN OF THIS SET OF PLANS AND SPECIFICATIONS COMPLIES WITH THE REQUIREMENTS OF THE CALIFORNIA ENERGY CODE, SECTIONS 150 & 151.

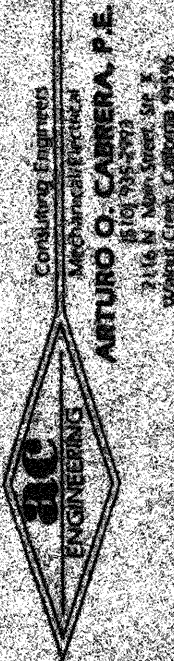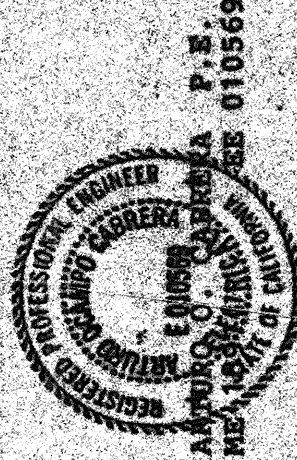

LIGHT FIXTURE SCHEDULE

MARK	SYMBOL	MANUFACTURER & MODEL NO.	LAMP	TYPE	REMARKS	NOTES
A	⊗	GARDONMGL-181-FM-100MM-120-HP	1	MH100/0/M		1,2 120
A1	⊗	GARDONMGL-181-3-100MM-120-HP	1	MH100/0/M		1,2 120
B	⊗	GARDONMGL-181-FM-100MM-120-HP-5.4-8-4E-HP	1	MH100/0/M		1,3 120
B1	⊗	GARDONMGL-181-3-100MM-120-HP-PRA-5.4-8-4E-HP	1	MH100/0/M		1,3 120
C	⊗	GARDONMGL-5.4-3-100MM-120-HP-PRA-5.4-12-4E-HP	1	MH100/0/M		1,3 120
D	⊗	HALO #0H 211-44/FLUSH DIFFUSER GLASS LENS	1	PL-S 13		1, 17
E	⊗	MULTIEX30-3PL 13-BLK-120V	3	PL-S13/27		1,8 51
F	⊗	GHRP1P07/120/HF-RMA100CL (various)	1	PL-C13M/27		1 17
G	⊗	THOMAS&K-2224-4	2	F40/CU		1 34
H	⊗	HUBBELL#M1C-70H-351 (ROOF LIGHTS)	1	MH70/0/M		1,8 92
I	⊗	LITHONIAM5240A-120-ES	2	F40/CU		3 68
J	⊗	SEAGULL #4911-15	2	PL13/27		1 27
K	⊗	BECAZ788P	2	PL-C 28W/27		1 70
L	⊗	LITHONIA F5840A-120-ES	4	F40/CU		3 106
M	⊗	HUBBELL #H21403M-35W/817/HPS-143V	1	35W/HPS		1 40
N	⊗	LITHONIAM1CA-140A-120-ES	1	F40/CU		3 34
O	⊗	HUBBELL #EUPGR-6H-120/EXIT LIGHT			INCLUDED	1
P	⊗	HUBBELL #EUPGR-5015/HPS-0A-CMP	1	250 WIR		1 250
Q	⊗	EMERSON LIGHT IN BATTERY PACK HUBBELL #EUPGR-5015/HPS-0A-CMP	2			1
R	⊗	HUBBELL #B46-6-120V-1/4-4W	1	150W/R40		1 150

NOTE: SEE 1/4" SCALE PLANS FOR DETAIL POWER AND LIGHTING PLANS FOR TYPICAL UNITS.