



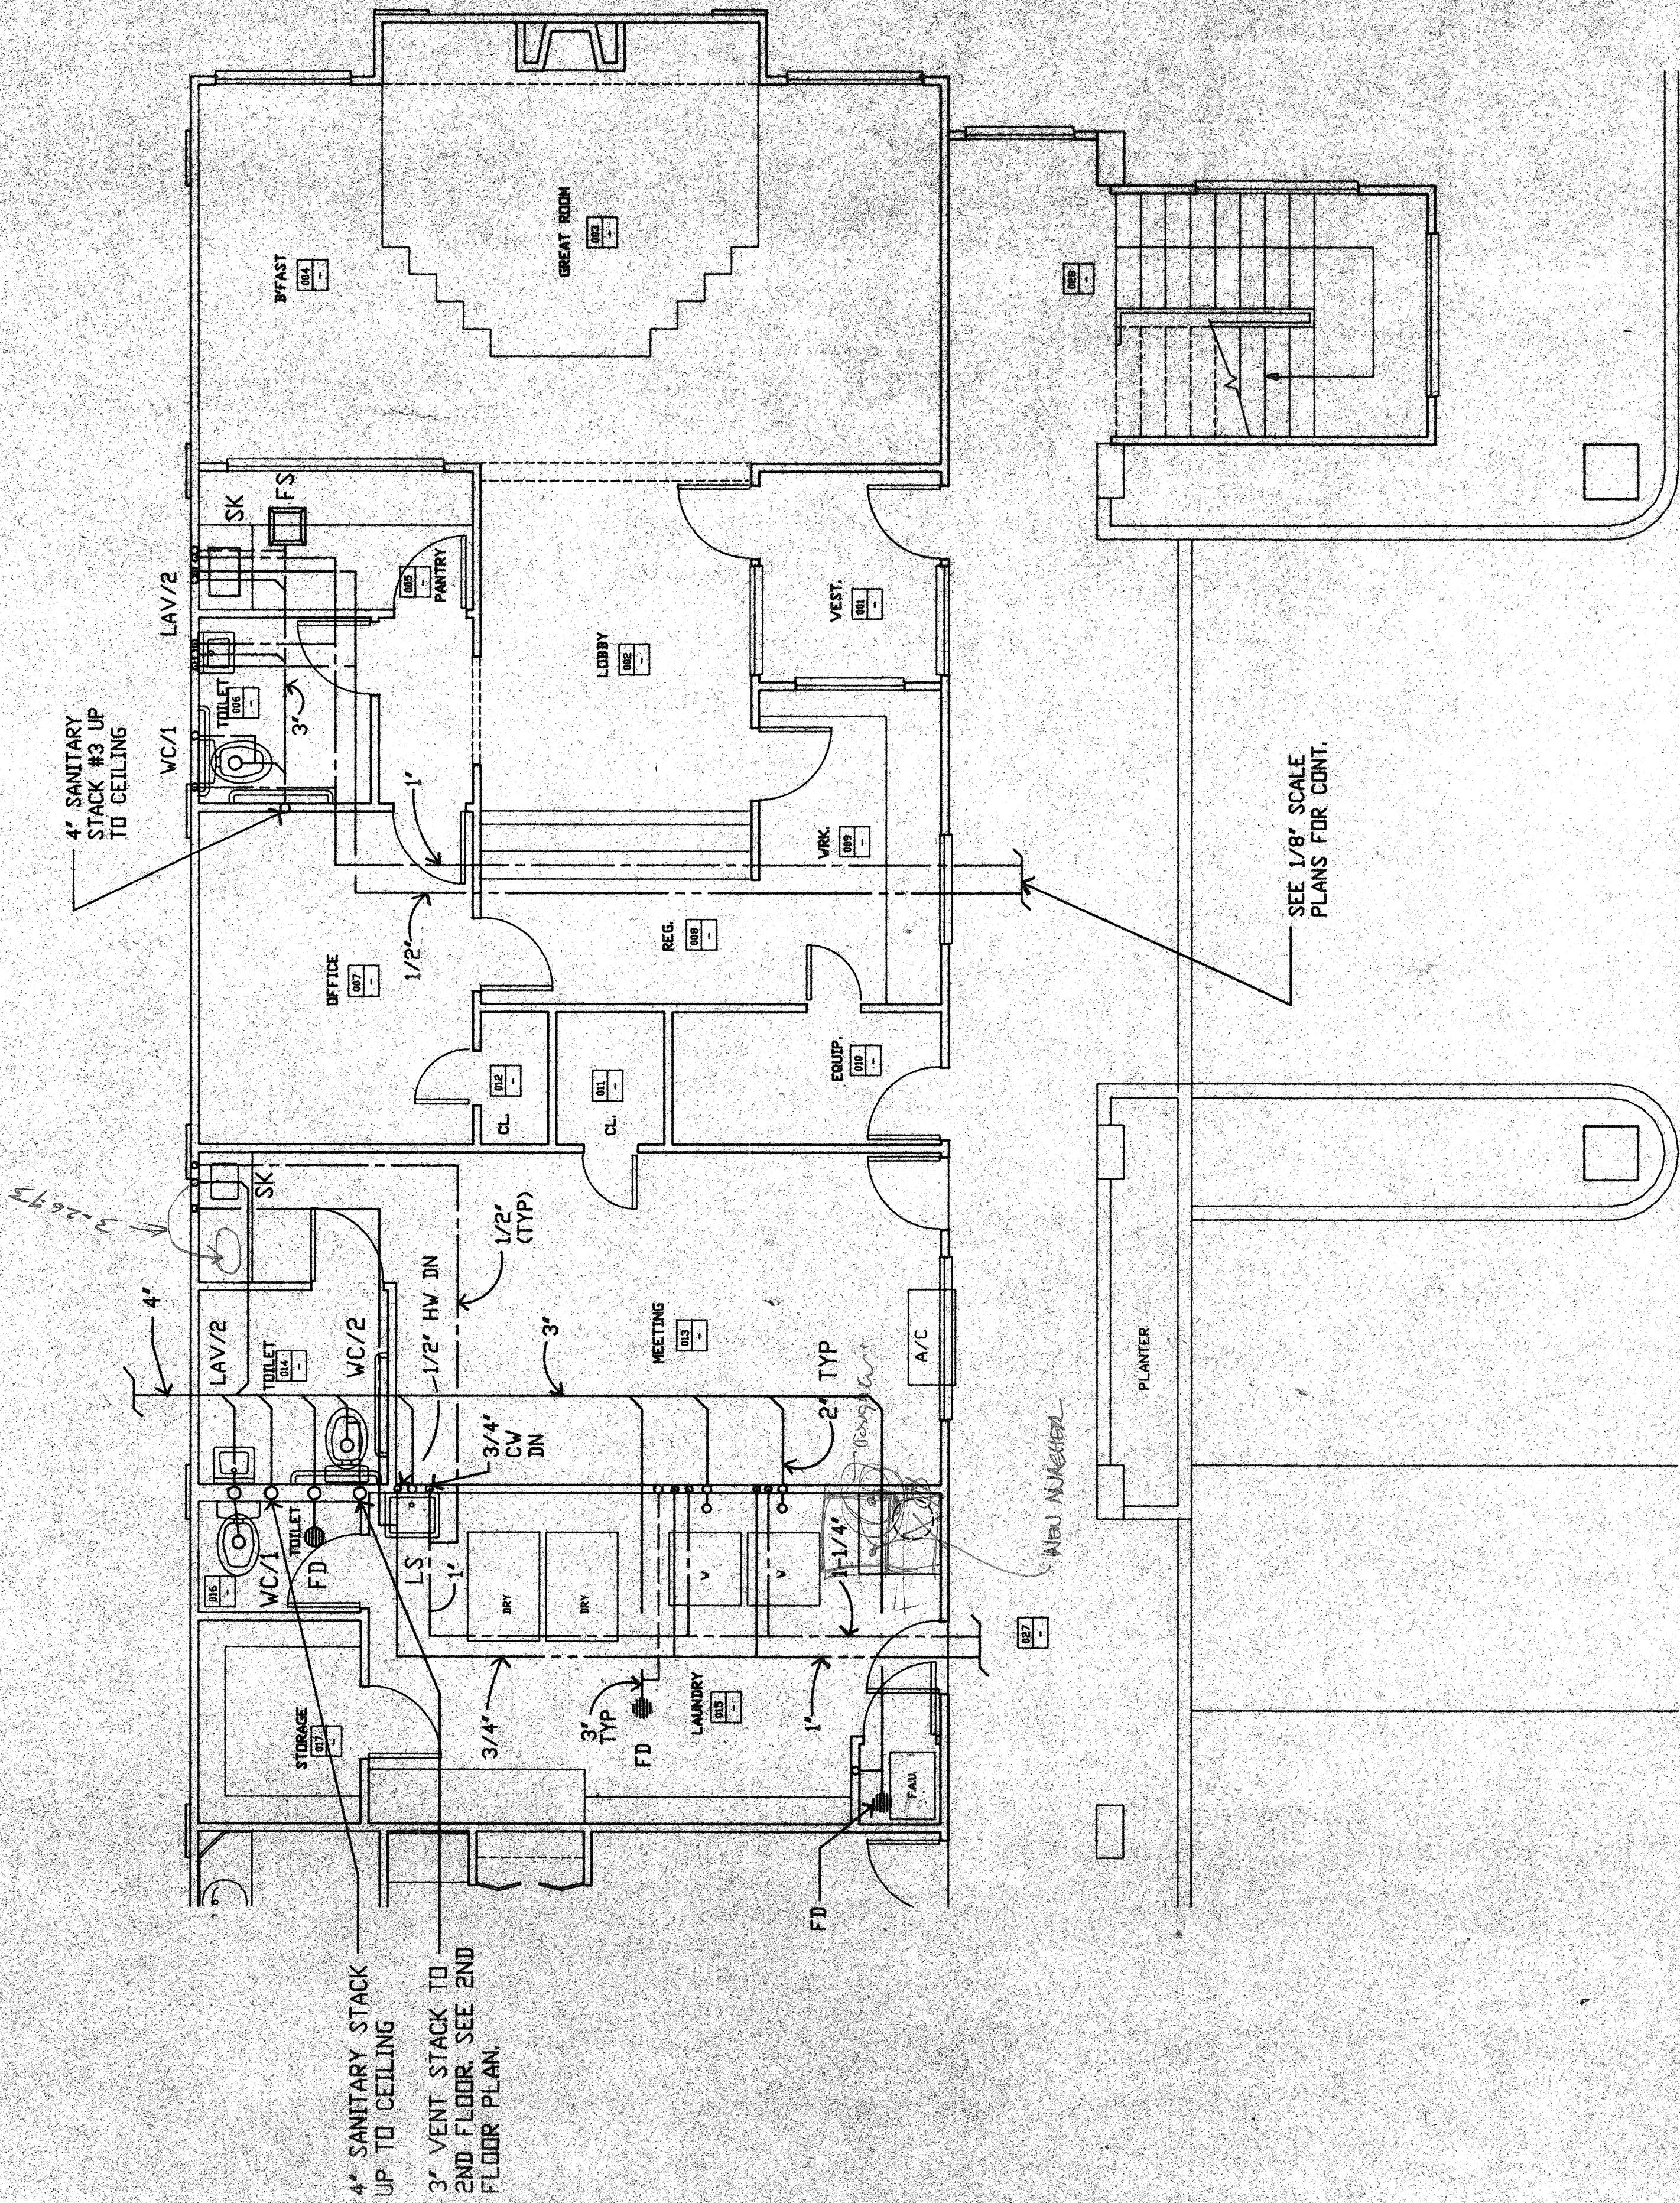

1 FIRST FLOOR-FRONT OFFICE
PLUMBING PLAN

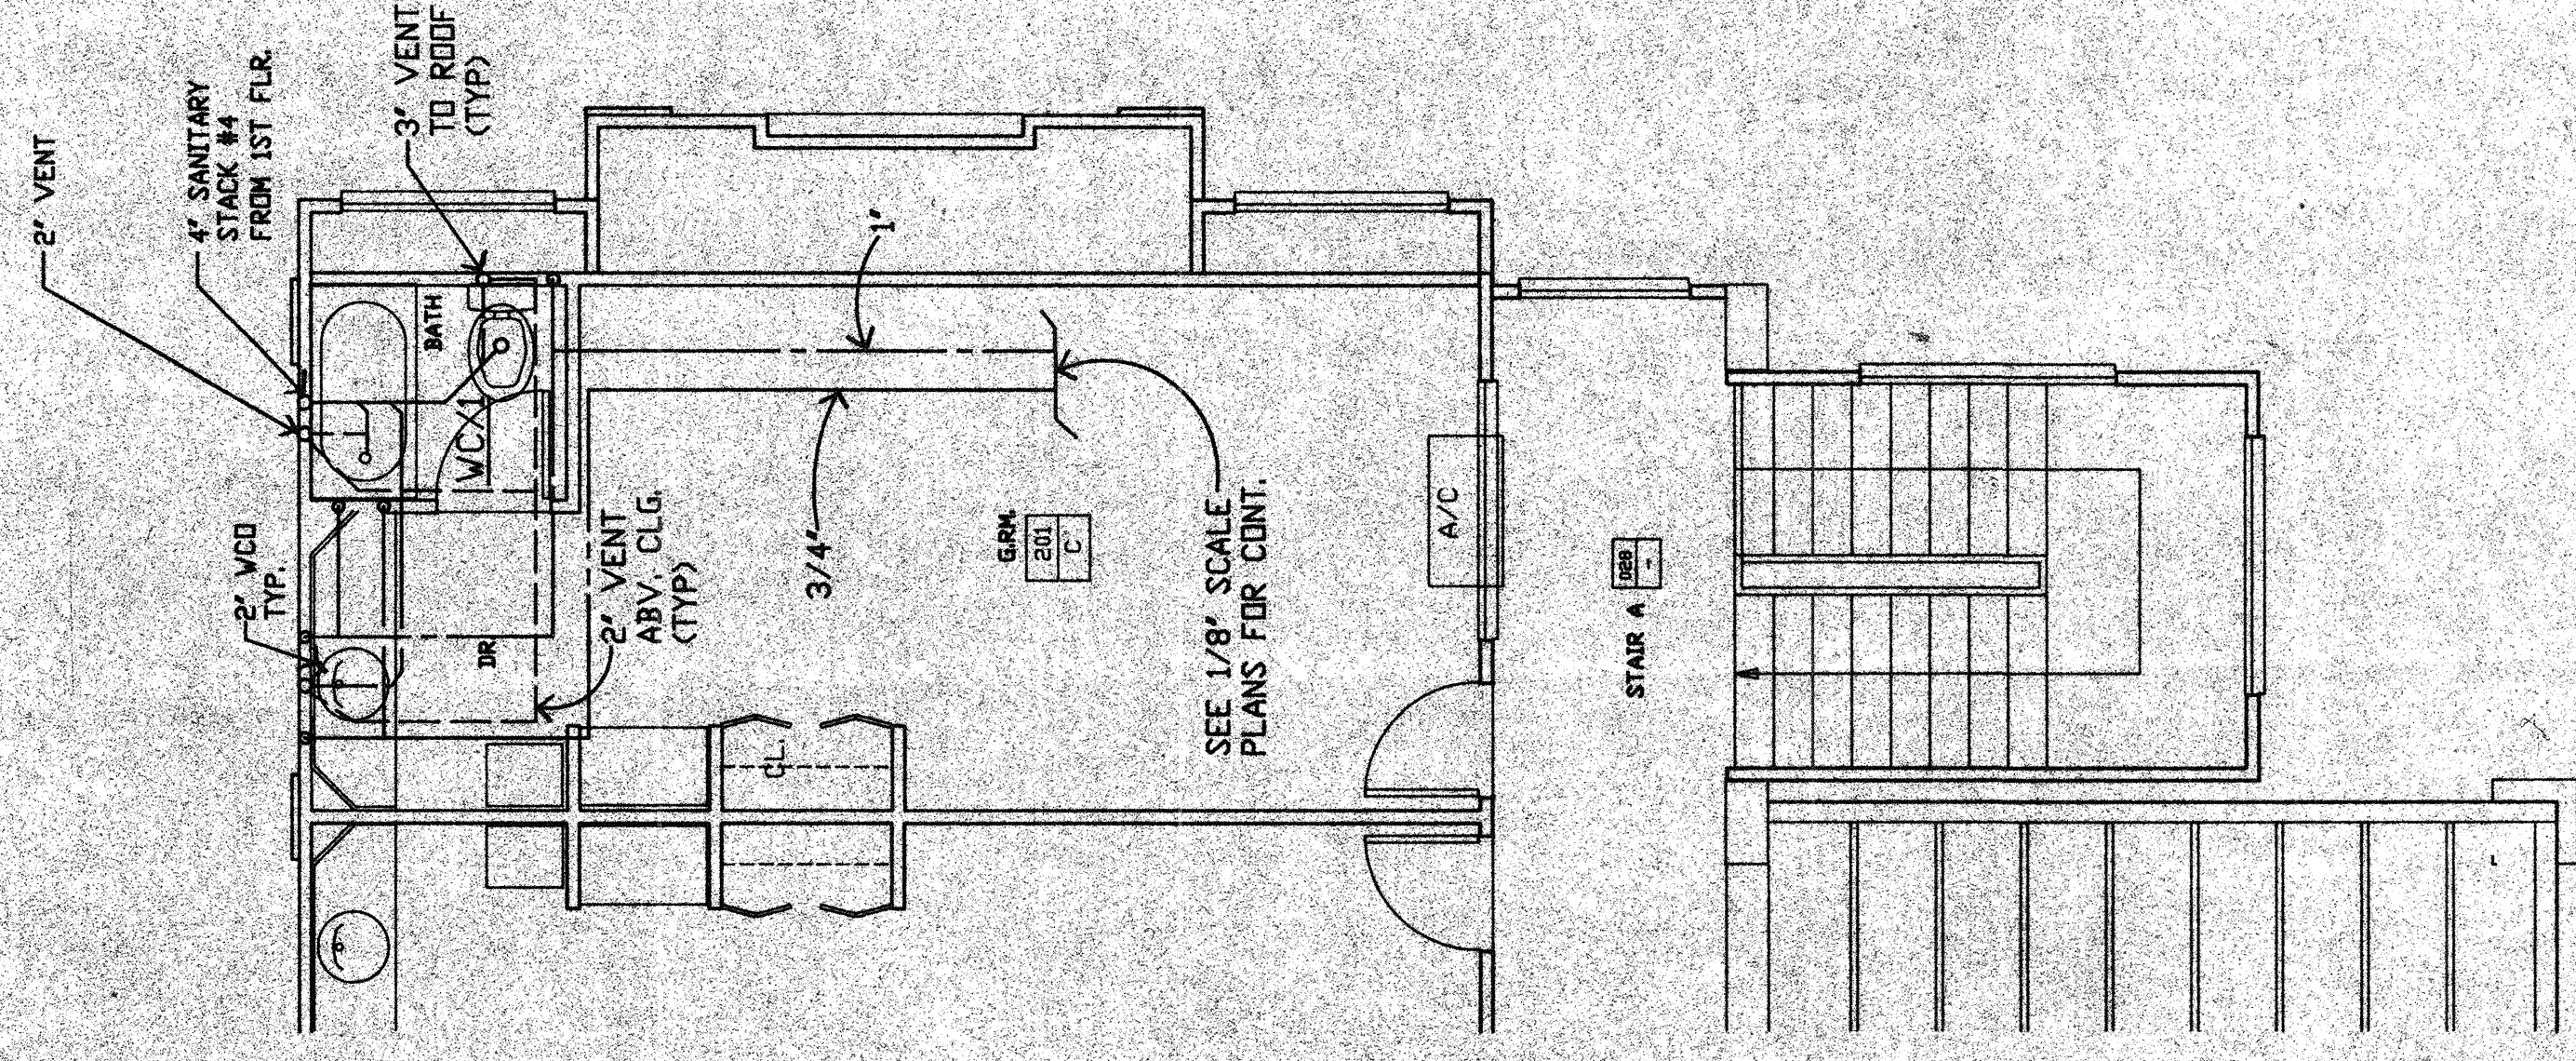

2 SECOND FLOOR - NORTH END
PLUMBING PLAN

LEGEND

SHEET NOTES



SKL ARCHITECTURE & PLANNING
3008 Willow Pass Road, Suite 206
Concord, California 94519
Phone: 510 680 2711
Fax: 510 680 2717

OWNER: HIL PATEL
CONTACT: VIJAY PATEL
1133 PEBBLEWOOD WAY
SAN MATEO, CA 94403
TEL: (415) 570 6970

PROJECT

PROPOSED 37-UNIT MOTEL
2834 EL CAMINO REAL
REDWOOD CITY, CA 94063

SHEET TITLE

DETAIL PLUMBING
PLANS

DRAWN	CHECKED	SCALE	DATE	JOB NO.	FILENAME	SHEET NO.	SHEET NO.
A. ARDILA	A. CABRERA	1/4"=1'-0"	SEP15/92	95002	RCA-B.3	P-6	DF

I HAVE REVIEWED THE CURRENT CALIFORNIA ENERGY CONSERVATION STANDARDS FOR RESIDENTIAL BUILDINGS. IN MY PROFESSIONAL JUDGEMENT, THE DESIGN ON THIS SET OF PLANS AND SPECIFICATIONS WILL CONFORM SUBSTANTIALLY WITH TITLE 24, SUBCHAPTER 7 & 8, SECTIONS 150 & 151.

